
 


SITE LOCATION

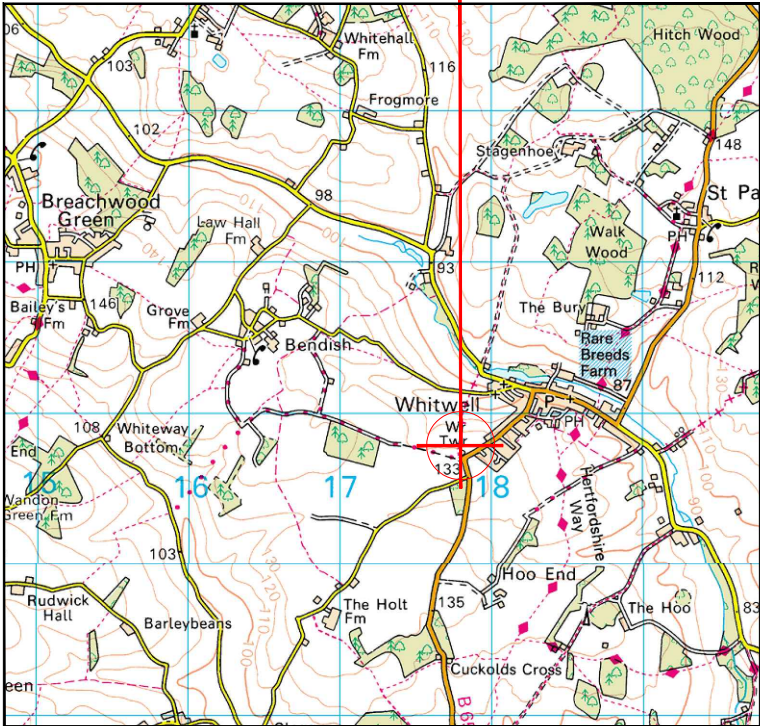


Reproduced by permission of Ordnance Survey on behalf of the Controller of His Majesty's Stationery Office All rights reserved. © Crown Copyright licence no. A152065A0001

SITE AREA PLAN



SITE PHOTOGRAPH

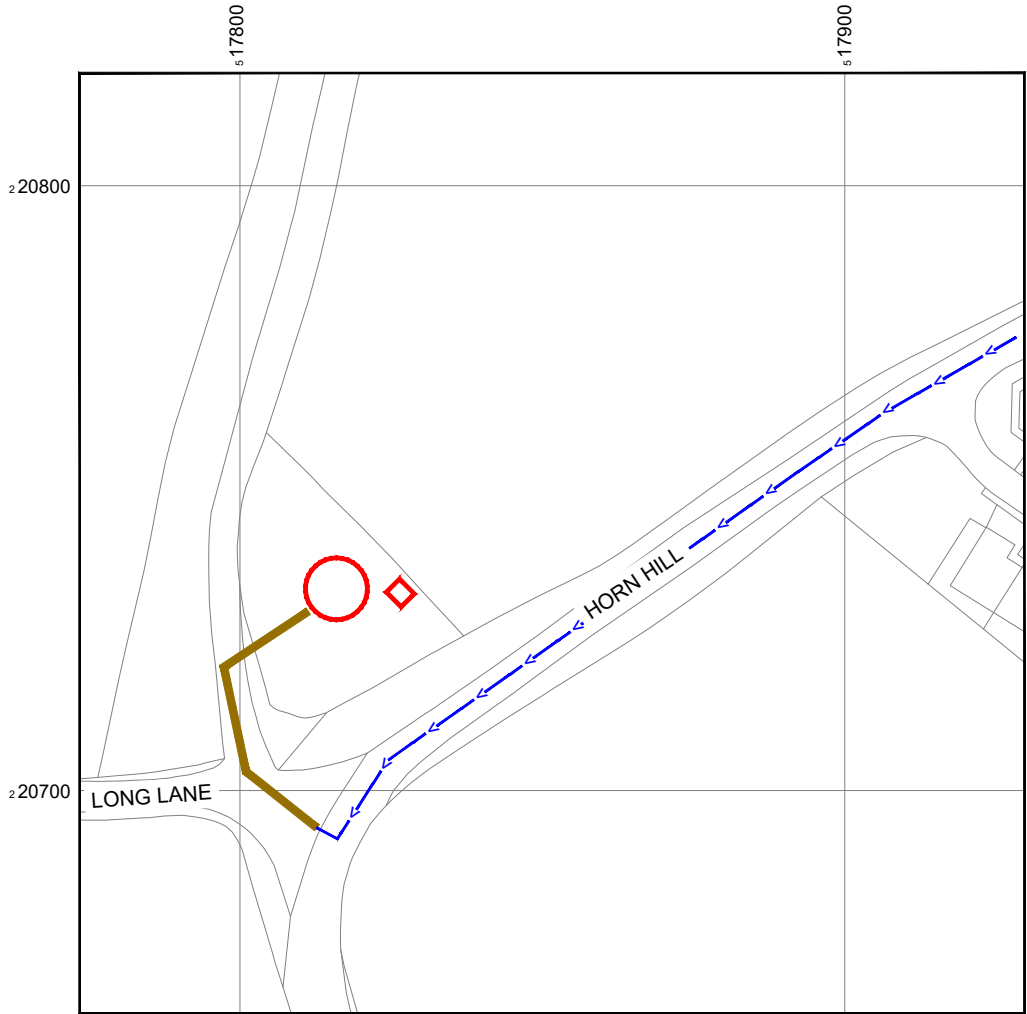


Reproduced by permission of Ordnance Survey on behalf of the Controller of His Majesty's Stationery Office All rights reserved. © Crown Copyright licence no. A152065A0001

NGR E: 517810 N: 220735

W3W: free.estate.later

 SITE LOCATION PLAN



NOTES:

1. ALL DIMENSIONS IN MM UNLESS OTHERWISE NOTED.

Demise:



Access Route To Site:



Access Route:



Directions: Leave the A1(M) at Junction 8 and head left on slip road for A602 towards Hitchin / Stevenage (North). At the roundabout take the 5th exit for Stevenage Road towards Little Wymondley / Todds Green. Turn left onto Chantry Lane. At the roundabout take the 1st exit. At the roundabout take the 2nd exit for Stevenage Road. Turn left onto B656 / London Road. Turn right onto B651. Turn left to stay on B651 / Horn Hill. Turn right onto Long Lane. The site is located on the RH side.

Master:	Project:	Purpose of Issue:	Issue:
M001	3UK 4G Symmetry	Detailed Design	A1
Date:	09.09.2025	Revision / Upgrade Description:	
Drawn:	EMF	Detailed Design	
Checked:	JS		
Approved:	GG		



Hutchison 3G UK Limited
Green Park, 450 Longwater Avenue
Reading, RG30 3UR
Tel: 01628 765 000
Fax: 01628 765 001

H3G Base Station Information line:
0845 6043000
Available 8am-8pm Monday to Friday


Design Consultant:



WHP Telecoms
Unit 1 Maple Park,
Low Fields Avenue, Leeds
LS12 6HH

Tel: 01133023550
e-mail: info@whptelecoms.com

Site Name:	WHITWELL WATER TOWER		
Site ID:	1205756		
Address:	WATER TOWER, HORN HILL WHITWELL HITCHIN HERTFORDSHIRE SG4 8AT		
Title:	002 SITE LOCATION PLAN		
Project:	3UK 4G SYMMETRY		
Purpose of Issue:	DETAILED DESIGN		
EE Cell ID:	MBNL Cell ID:	H3G Cell ID:	
16810	NHE054	SG0382	
File name:			
NHE054_16810_SG0382_H3G_4G SYM_DDD_A1			

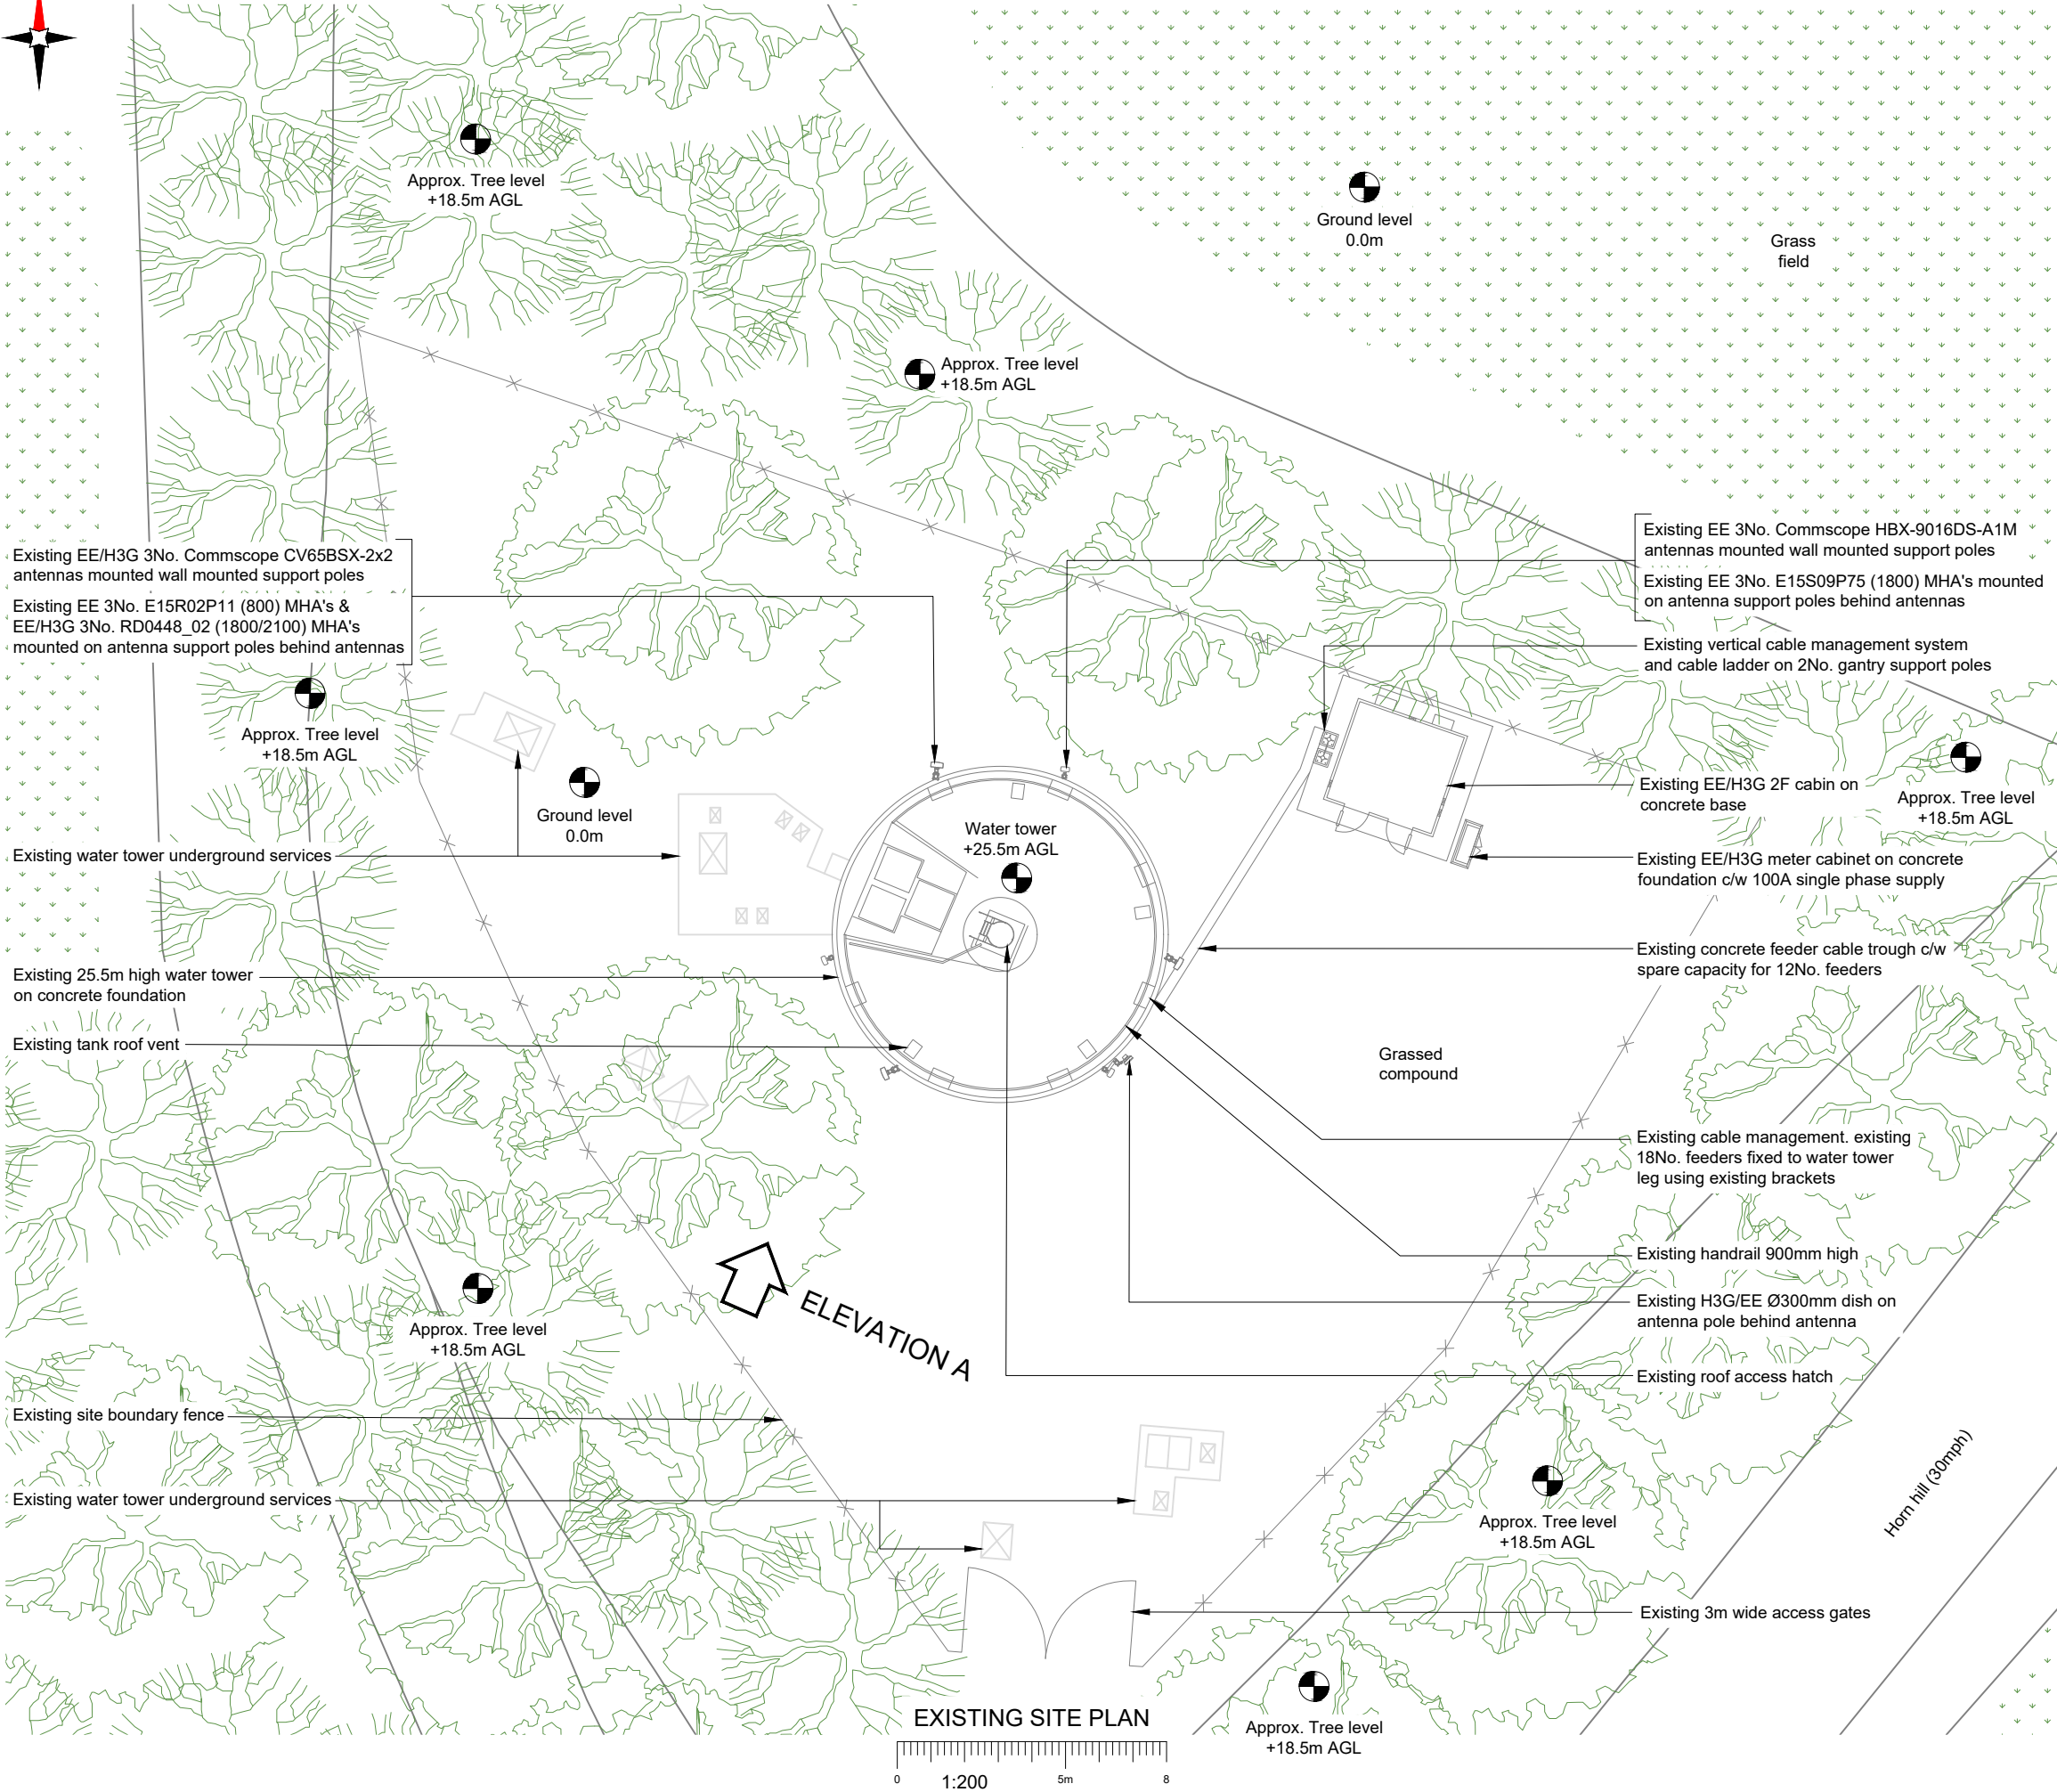

NOTES:
1. ALL DIMENSIONS IN MM UNLESS OTHERWISE NOTED.

Master:	Project:	Purpose of Issue:	Issue:
M001	3UK 4G Symmetry	Detailed Design	A1

Date:	09.09.2025	Revision / Upgrade Description:
Drawn:	EMF	Detailed Design
Checked:	JS	
Approved:	GG	

Hutchison 3G UK Limited
Green Park, 450 Longwater Avenue
Reading, RG30 3UR
Tel: 01628 765 000
Fax: 01628 765 001

H3G Base Station Information line:
0845 6043000
Available 8am-8pm Monday to Friday

Design Consultant:

WHP Telecoms
Unit 1 Maple Park,
Low Fields Avenue, Leeds
LS12 6HH

Tel: 01133023550
e-mail: info@whptelecoms.com

Site Name:

WHITWELL WATER TOWER

Site ID:

1205756

Address:

**WATER TOWER, HORN HILL
WHITWELL
HITCHIN
HERTFORDSHIRE
SG4 8AT**

Title:

100 EXISTING SITE PLAN

Project:

3UK 4G SYMMETRY


Purpose of Issue:

DETAILED DESIGN

EE Cell ID:	MBNL Cell ID:	H3G Cell ID:
16810	NHE054	SG0382

File name:

NHE054_16810_SG0382_H3G_4G SYM_DDD_A1

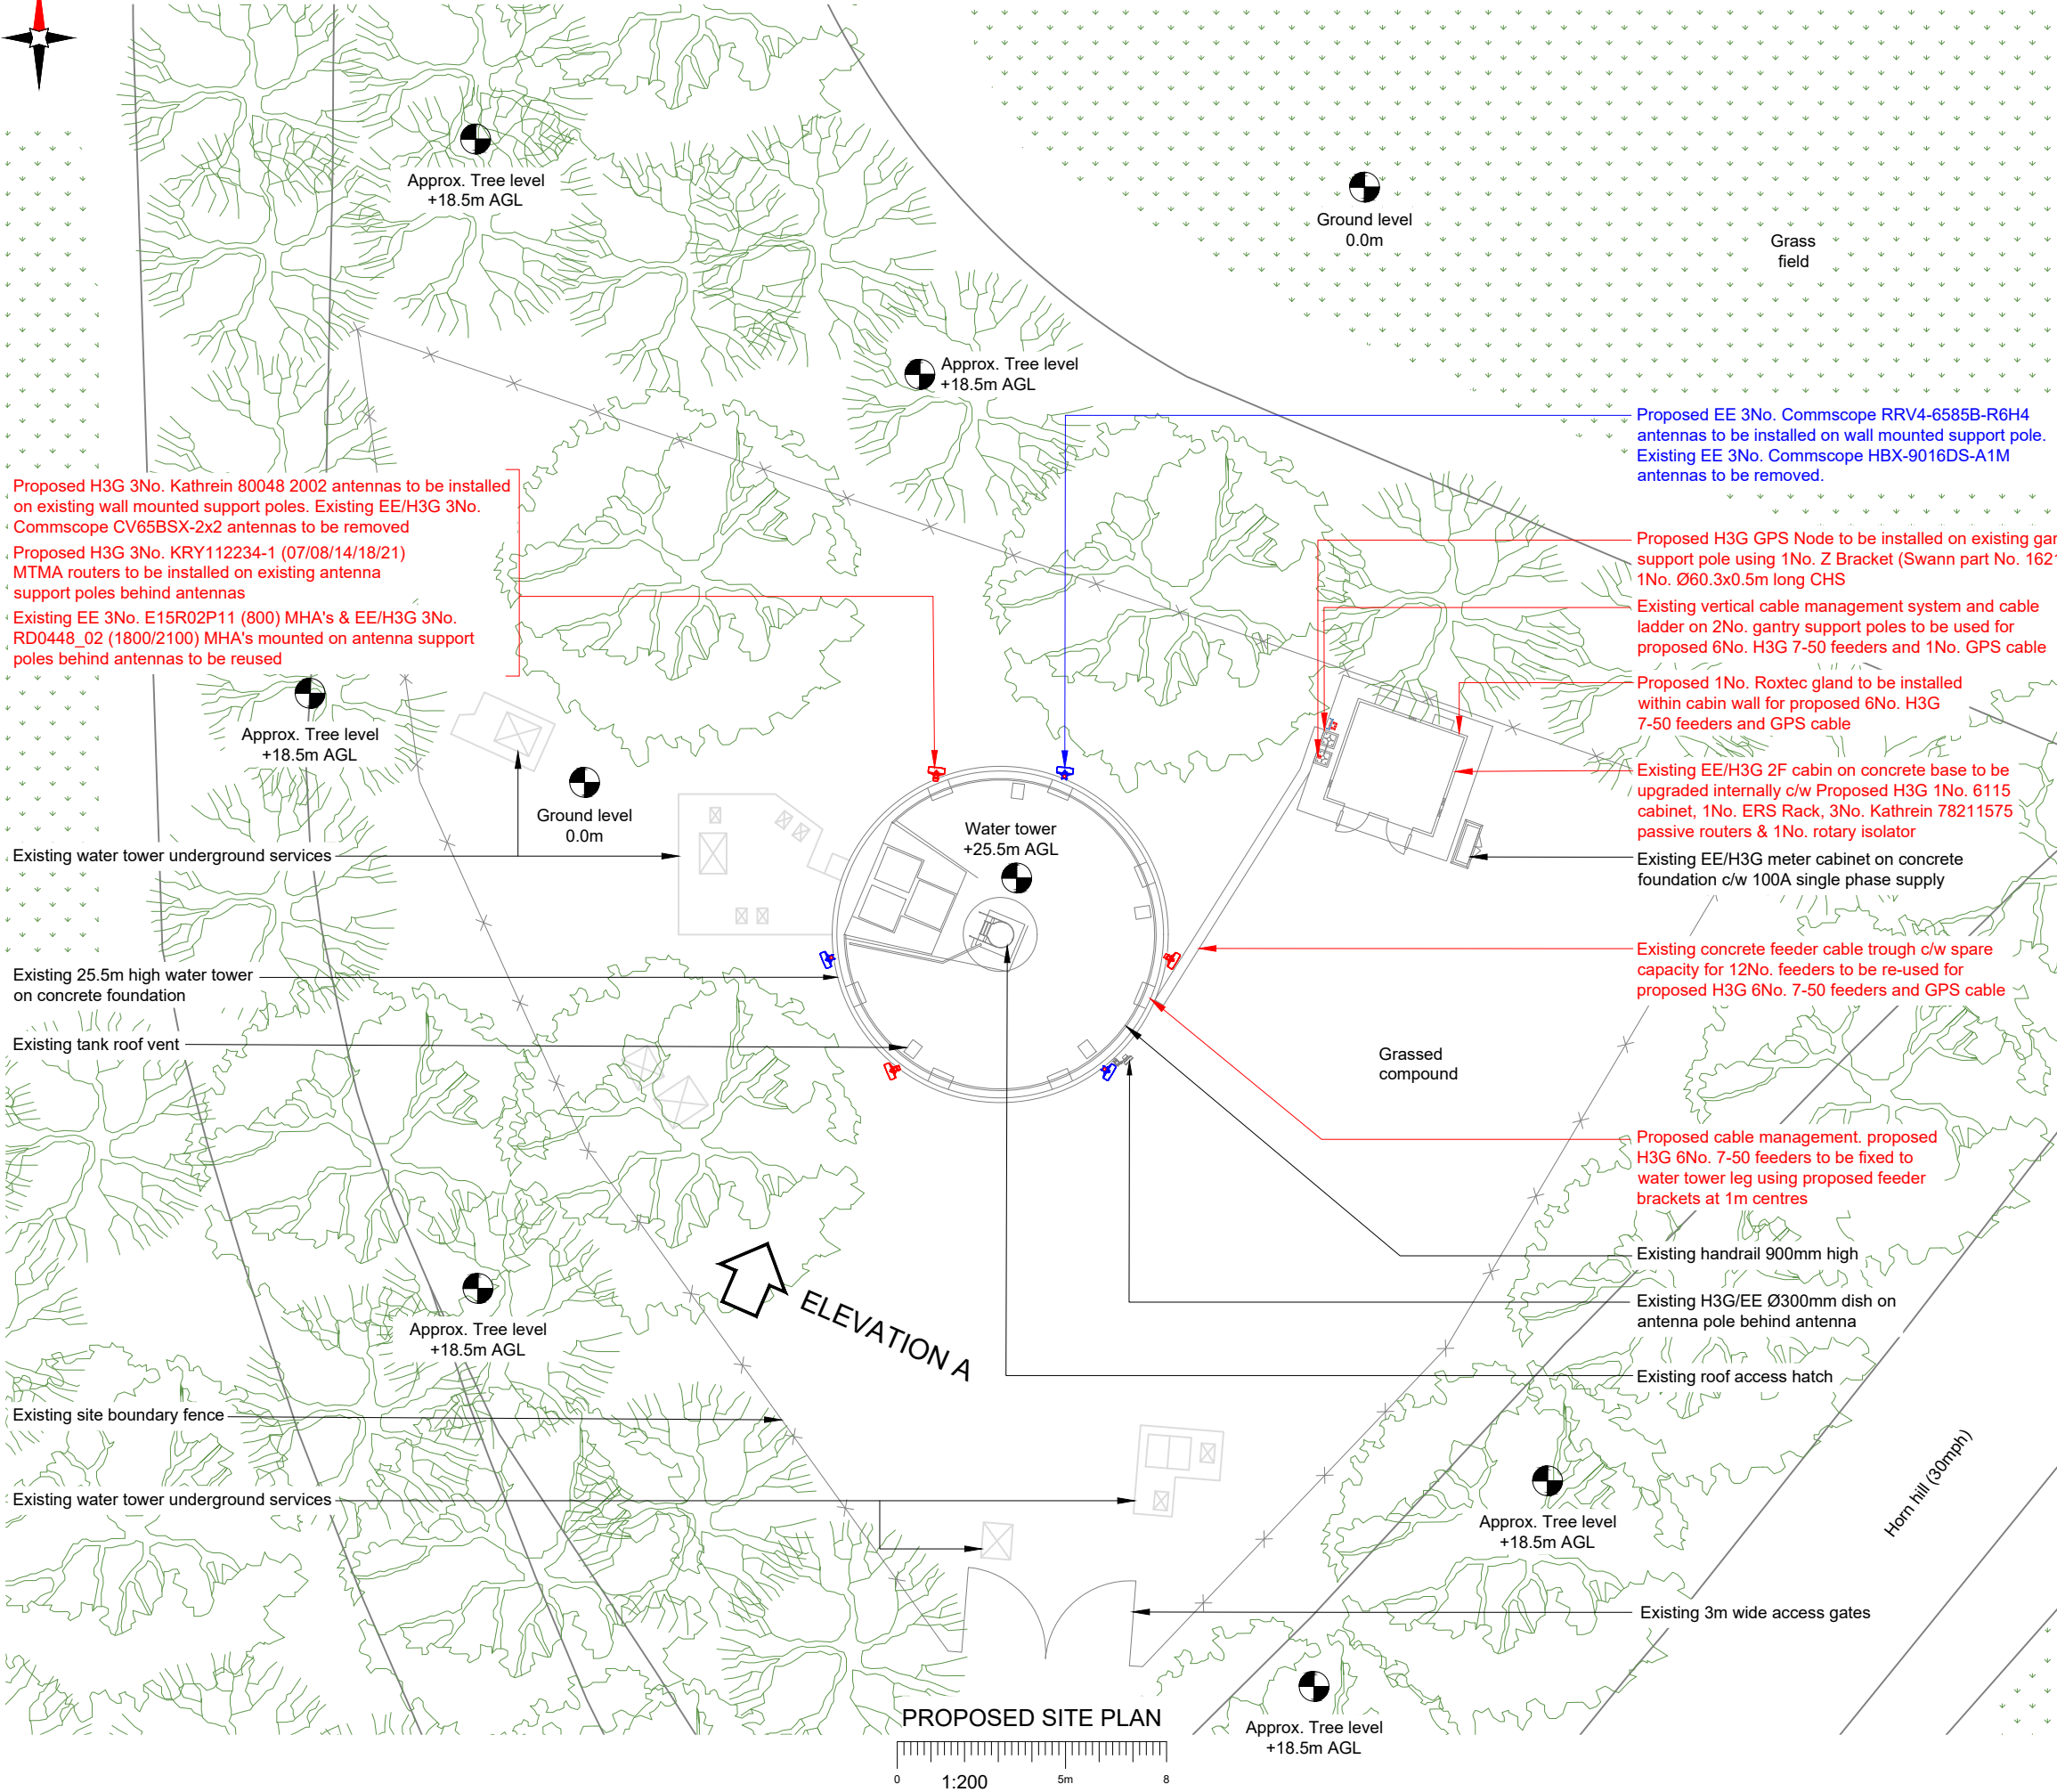

NOTES:

1. ALL DIMENSIONS IN MM UNLESS OTHERWISE NOTED.

NOTE:EXISTING U2100 EQUIPMENT AND FEEDERS ARE TO BE DECOMMISSIONED AS PART OF THE 3UK SYMMETRY UPGRADE, FOLLOWING THE U2100 SUNSET

Master:	Project:		Purpose of Issue:	Issue:
M001	3UK 4G Symmetry		Detailed Design	A1
Date:	09.09.2025	Revision / Upgrade Description:		
Drawn:	EMF	Detailed Design		
Checked:	JS			
Approved:	GG			

Hutchison 3G UK Limited
Green Park, 450 Longwater Avenue
Reading, RG30 3UR
Tel: 01628 765 000
Fax: 01628 765 001


H3G Base Station Information line:
0845 6043000
Available 8am-8pm Monday to Friday

Design Consultant:


WHP Telecoms
Unit 1 Maple Park,
Low Fields Avenue, Leeds
LS12 6HH

Tel: 01133023550
e-mail: info@whptelecoms.com

Site Name:		
WHITWELL WATER TOWER		
Site ID:		
1205756		
Address:		
WATER TOWER, HORN HILL WHITWELL HITCHIN HERTFORDSHIRE SG4 8AT		
Title:		
150 PROPOSED SITE PLAN		
Project:		
3UK 4G SYMMETRY		
Purpose of Issue:		
DETAILED DESIGN		
EE Cell ID:	MBNL Cell ID:	H3G Cell ID:
16810	NHE054	SG0382
File name:		
NHE054_16810_SG0382_H3G_4G SYM_DDD_A1		

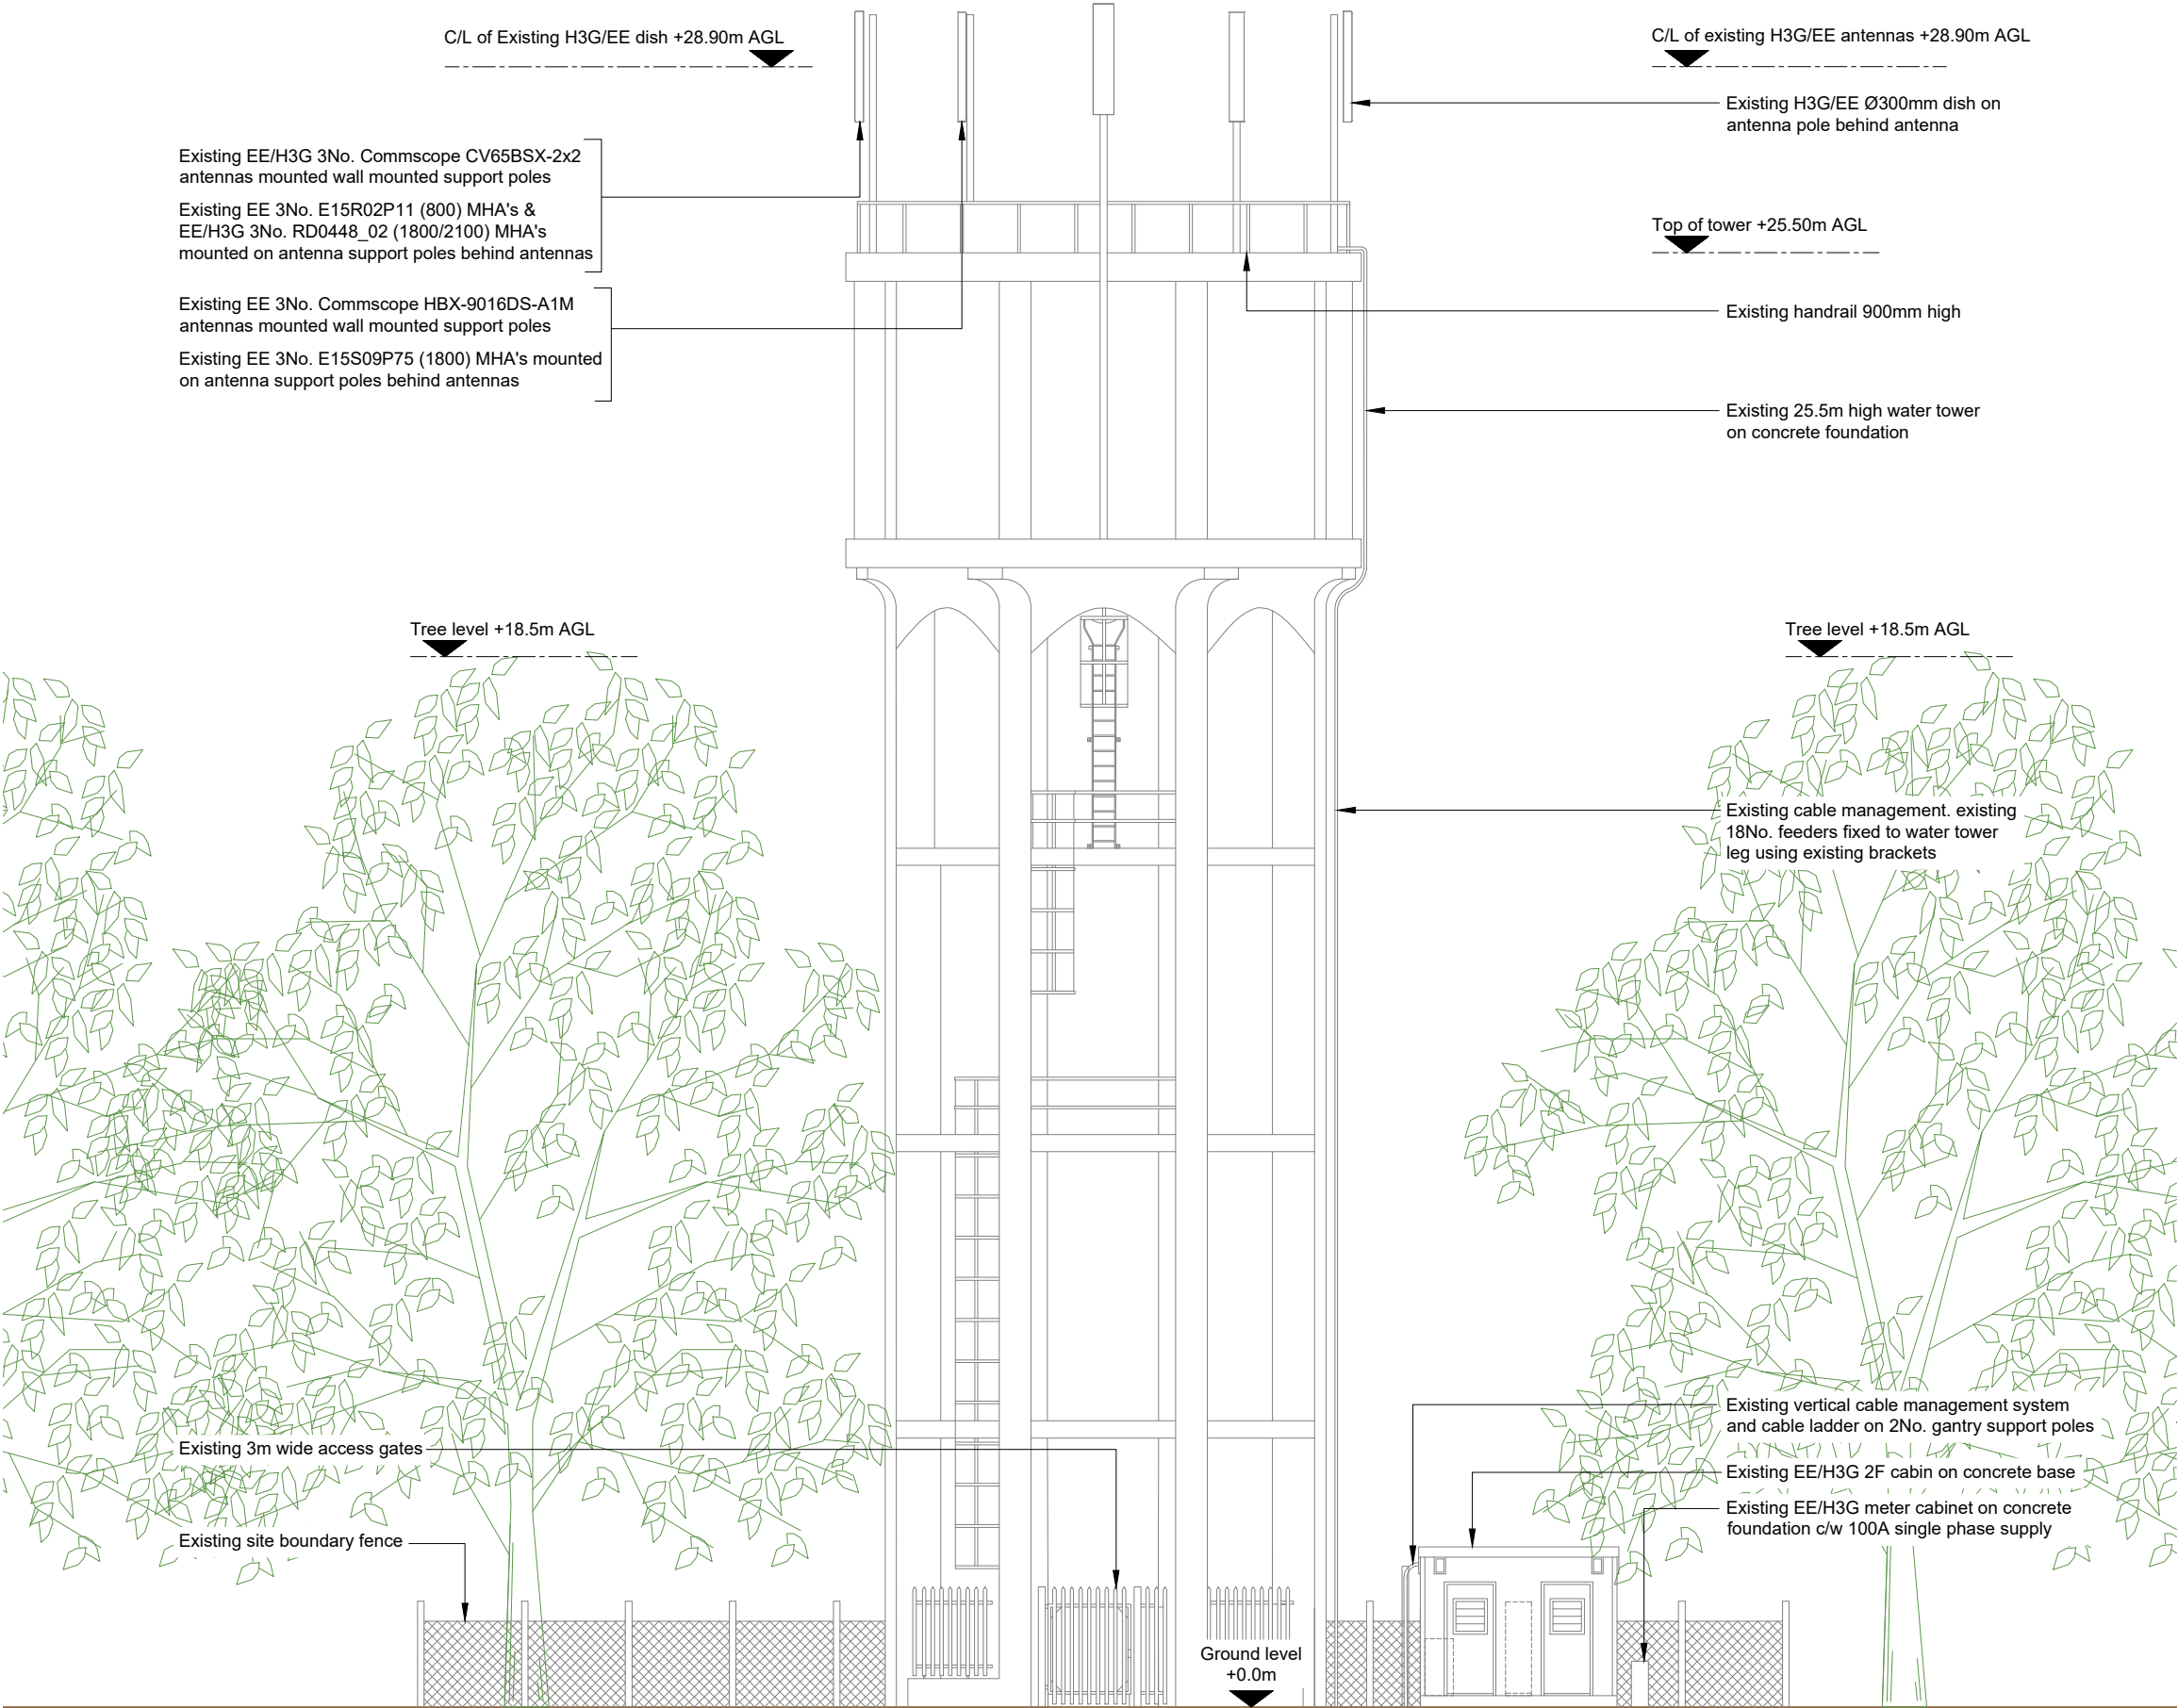

EXISTING SITE ELEVATION A

 

- NOTES:
- ALL DIMENSIONS IN MM UNLESS OTHERWISE NOTED.

Master:	Project:		Purpose of Issue:	Issue:
M001	3UK 4G Symmetry		Detailed Design	A1
Date:	09.09.2025	Revision / Upgrade Description:		
Drawn:	EMF	Detailed Design		
Checked:	JS			
Approved:	GG			



Hutchison 3G UK Limited
Green Park, 450 Longwater Avenue
Reading, RG30 3UR
Tel: 01628 765 000
Fax: 01628 765 001

H3G Base Station Information line:
0845 6043000
Available 8am-8pm Monday to Friday

Design Consultant:



WHP Telecoms
Unit 1 Maple Park,
Low Fields Avenue, Leeds
LS12 6HH

Tel: 01133023550
e-mail: info@whptelecoms.com

Site Name:
WHITWELL WATER TOWER

Site ID:
1205756

Address:
WATER TOWER, HORN HILL
WHITWELL
HITCHIN
HERTFORDSHIRE
SG4 8AT

Title:
200 EXISTING SITE ELEVATION


Project:
3UK 4G SYMMETRY

Purpose of Issue:
DETAILED DESIGN


EE Cell ID:	MBNL Cell ID:	H3G Cell ID:
16810	NHE054	SG0382

File name:
NHE054_16810_SG0382_H3G_4G SYM_DDD_A1

100mm
50mm
10mm

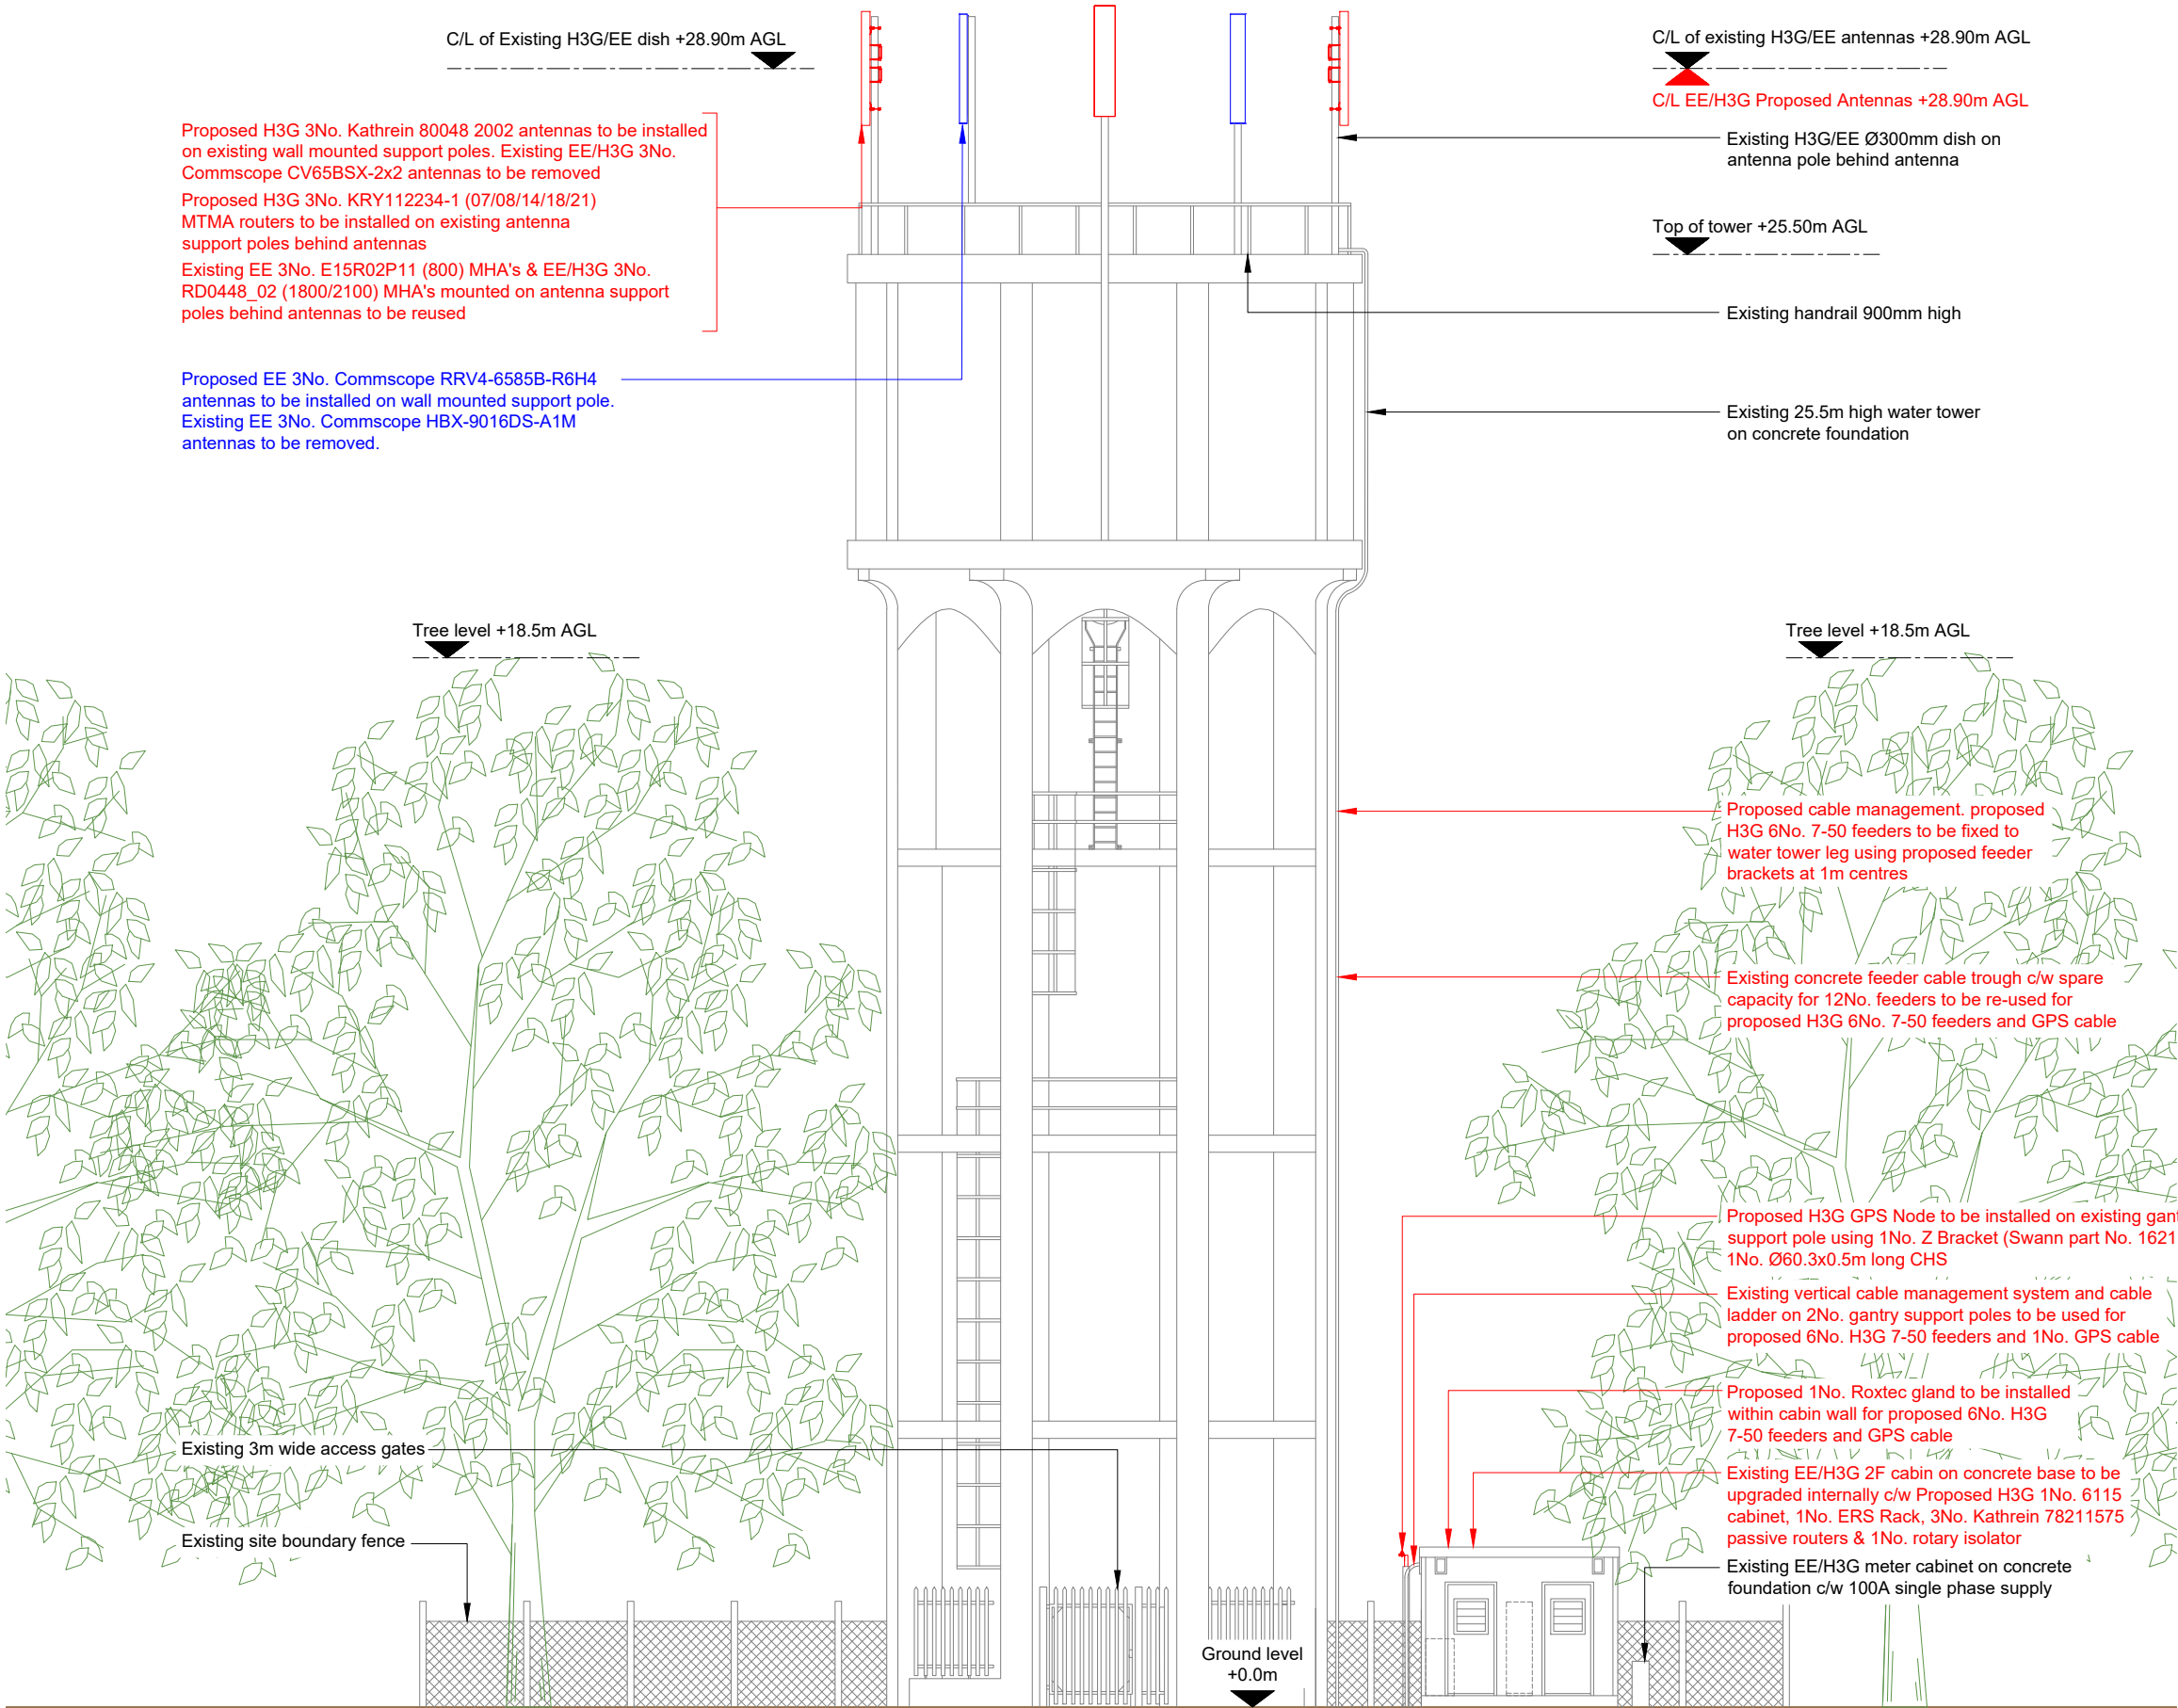

PROPOSED SITE ELEVATION A

 

- NOTES:
- ALL DIMENSIONS IN MM UNLESS OTHERWISE NOTED.

Master:	Project:	Purpose of Issue:	Issue:
M001	3UK 4G Symmetry	Detailed Design	A1
Date:	09.09.2025	Revision / Upgrade Description:	
Drawn:	EMF	Detailed Design	
Checked:	JS		
Approved:	GG		



Hutchison 3G UK Limited
Green Park, 450 Longwater Avenue
Reading, RG30 3UR
Tel: 01628 765 000
Fax: 01628 765 001

H3G Base Station Information line:
0845 6043000
Available 8am-8pm Monday to Friday

Design Consultant:



WHP Telecoms
Unit 1 Maple Park,
Low Fields Avenue, Leeds
LS12 6HH

Tel: 01133023550
e-mail: info@whptelecoms.com

Site Name:
WHITWELL WATER TOWER

Site ID:
1205756

Address:
WATER TOWER, HORN HILL
WHITWELL
HITCHIN
HERTFORDSHIRE
SG4 8AT

Title:
250 PROPOSED SITE ELEVATION

Project:
3UK 4G SYMMETRY

Purpose of Issue:
DETAILED DESIGN

EE Cell ID:	MBNL Cell ID:	H3G Cell ID:
16810	NHE054	SG0382

File name:
NHE054_16810_SG0382_H3G_4G SYM_DDD_A1