


Dimensions are not to be scaled from this drawing

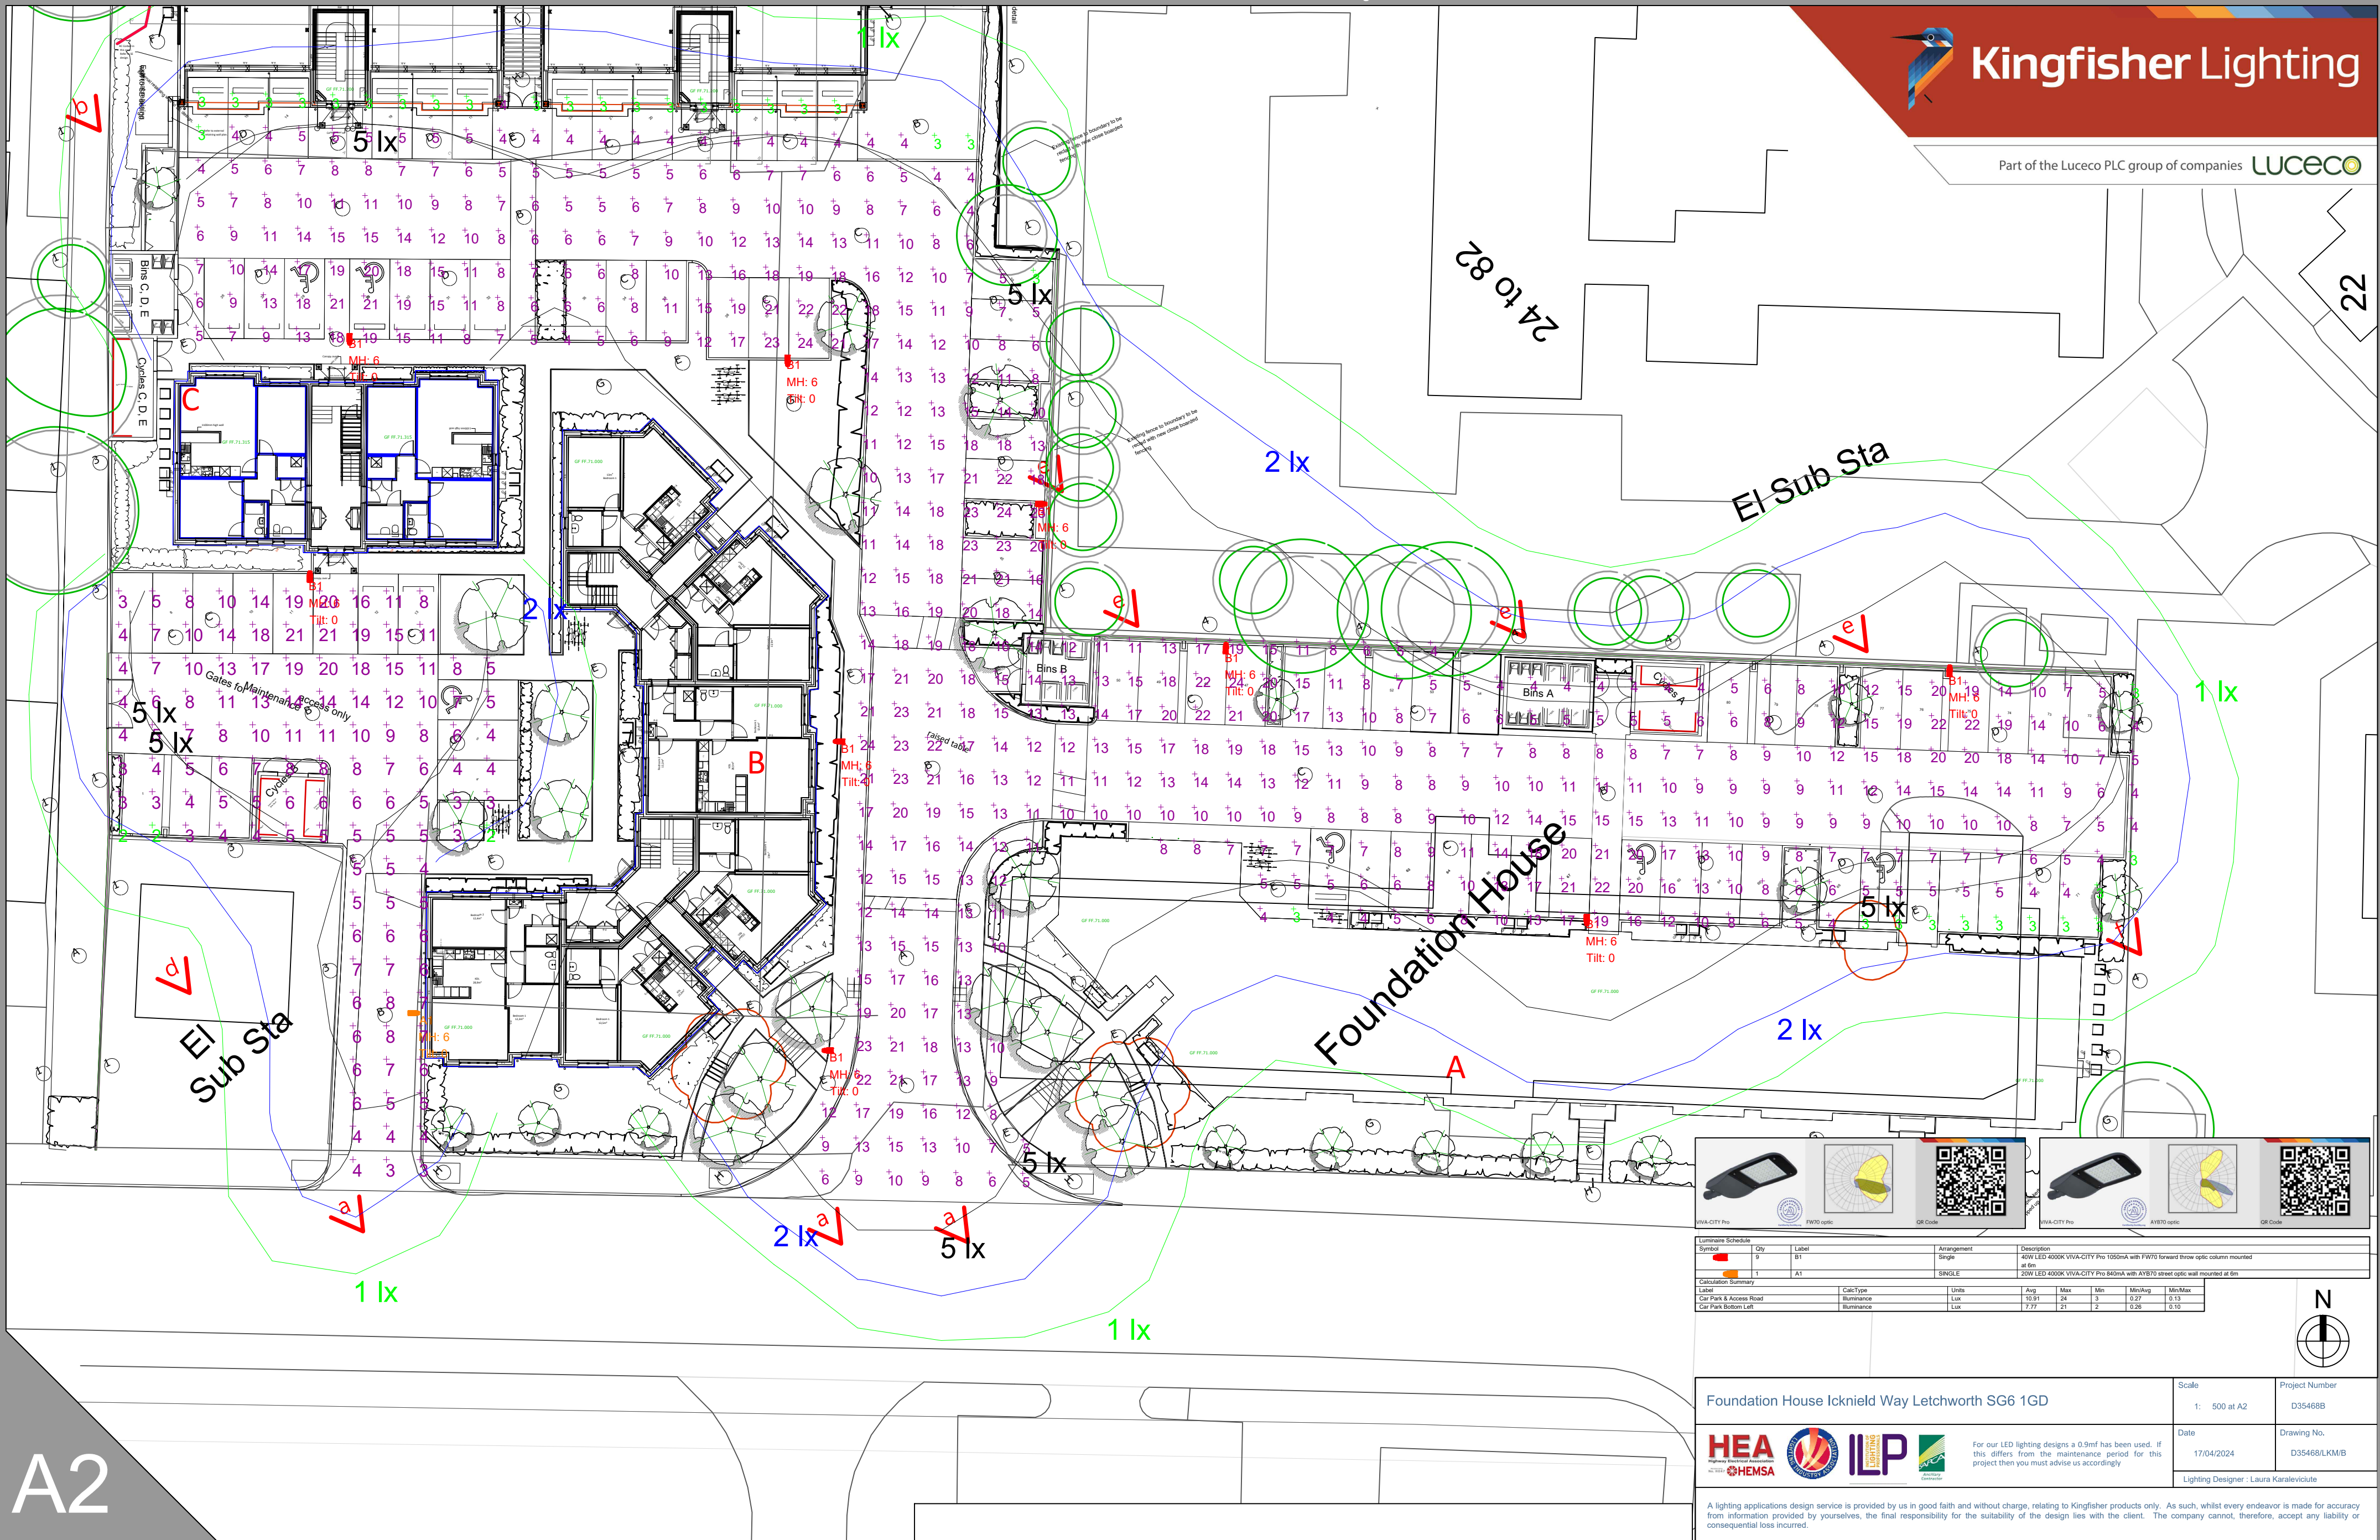


Kingfisher Lighting

Part of the Luceco PLC group of companies **LUCECO**



Luminaire Schedule		City		Label		Arrangement		Description	
Symbol		9	B1			Single		40W LED 4000K VIVA-CITY Pro 1000mA with FW70 forward throw optic column mounted at 6m	
Label		1	A1			SINGLE		20W LED 4000K VIVA-CITY Pro 500mA with AYB70 street optic wall mounted at 6m	
Calculation Summary		CalcType		Units		Avg		Max	
Car Park & Access Road	Illuminance	Lux				10.91	24	3	0.27
Car Park Bottom Left	Illuminance	Lux				7.77	21	2	0.26

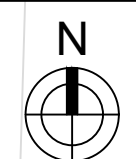

Foundation House Icknield Way Letchworth SG6 1GD		Scale	Project Number
		1: 500 at A2	D35468B
		Date	Drawing No.
		17/04/2024	D35468LKM/B
		Lighting Designer : Laura Karaleviciute	



For our LED lighting designs a 0.9mf has been used. If this differs from the maintenance period for this project then you must advise us accordingly.

A lighting applications design service is provided by us in good faith and without charge, relating to Kingfisher products only. As such, whilst every endeavor is made for accuracy from information provided by yourselves, the final responsibility for the suitability of the design lies with the client. The company cannot, therefore, accept any liability or consequential loss incurred.