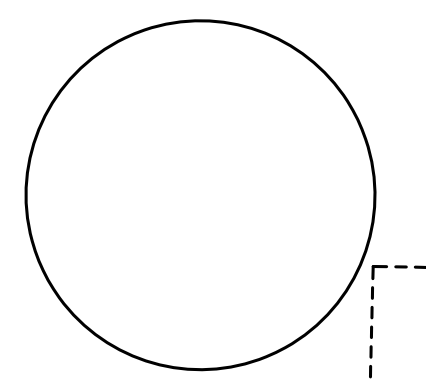
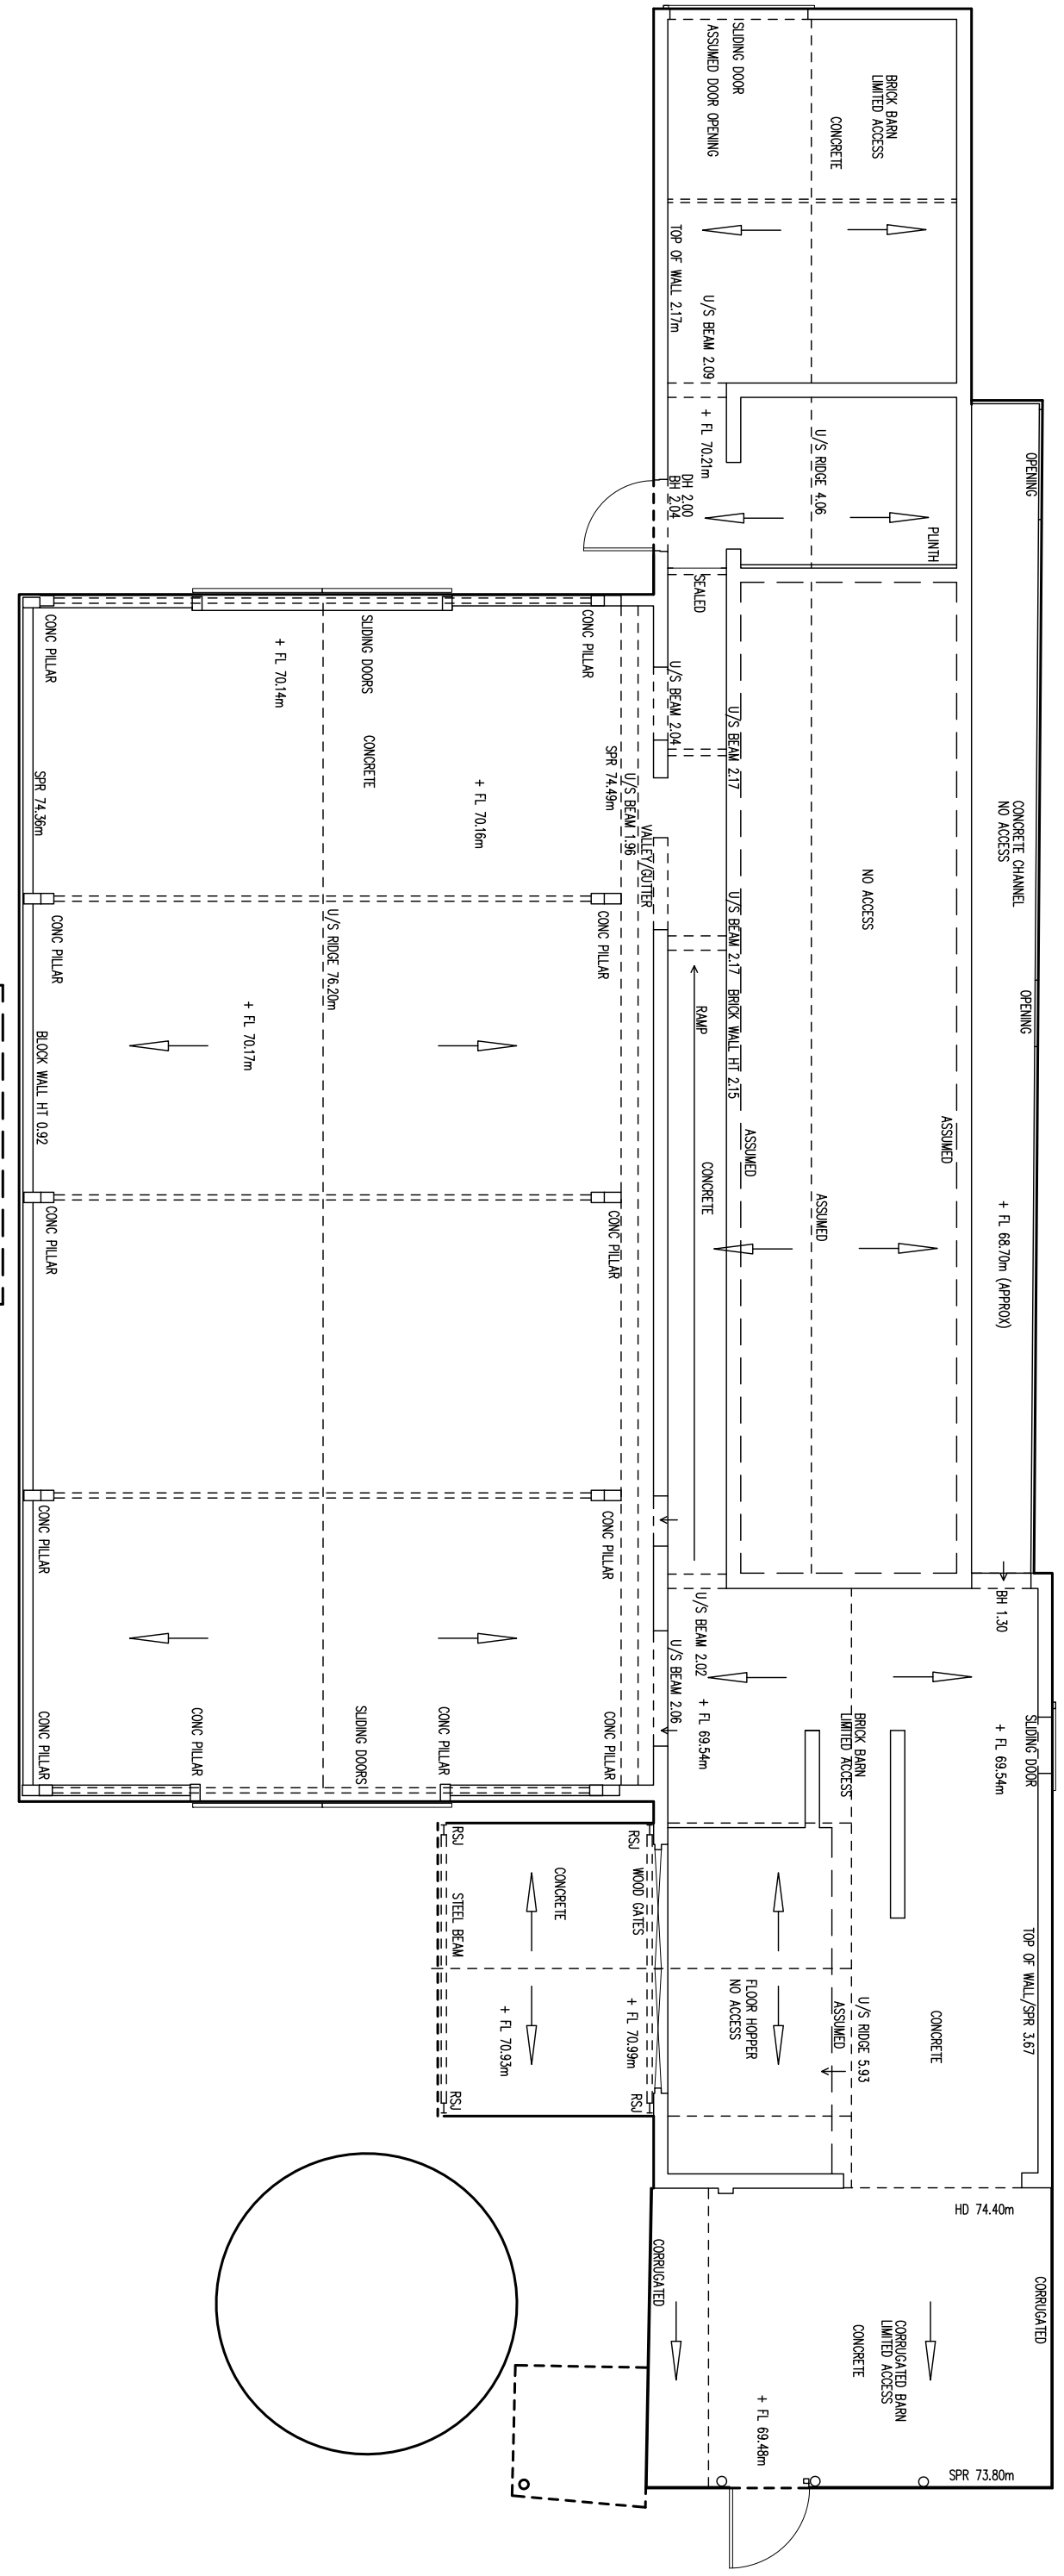
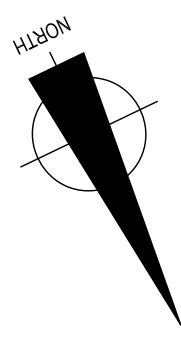
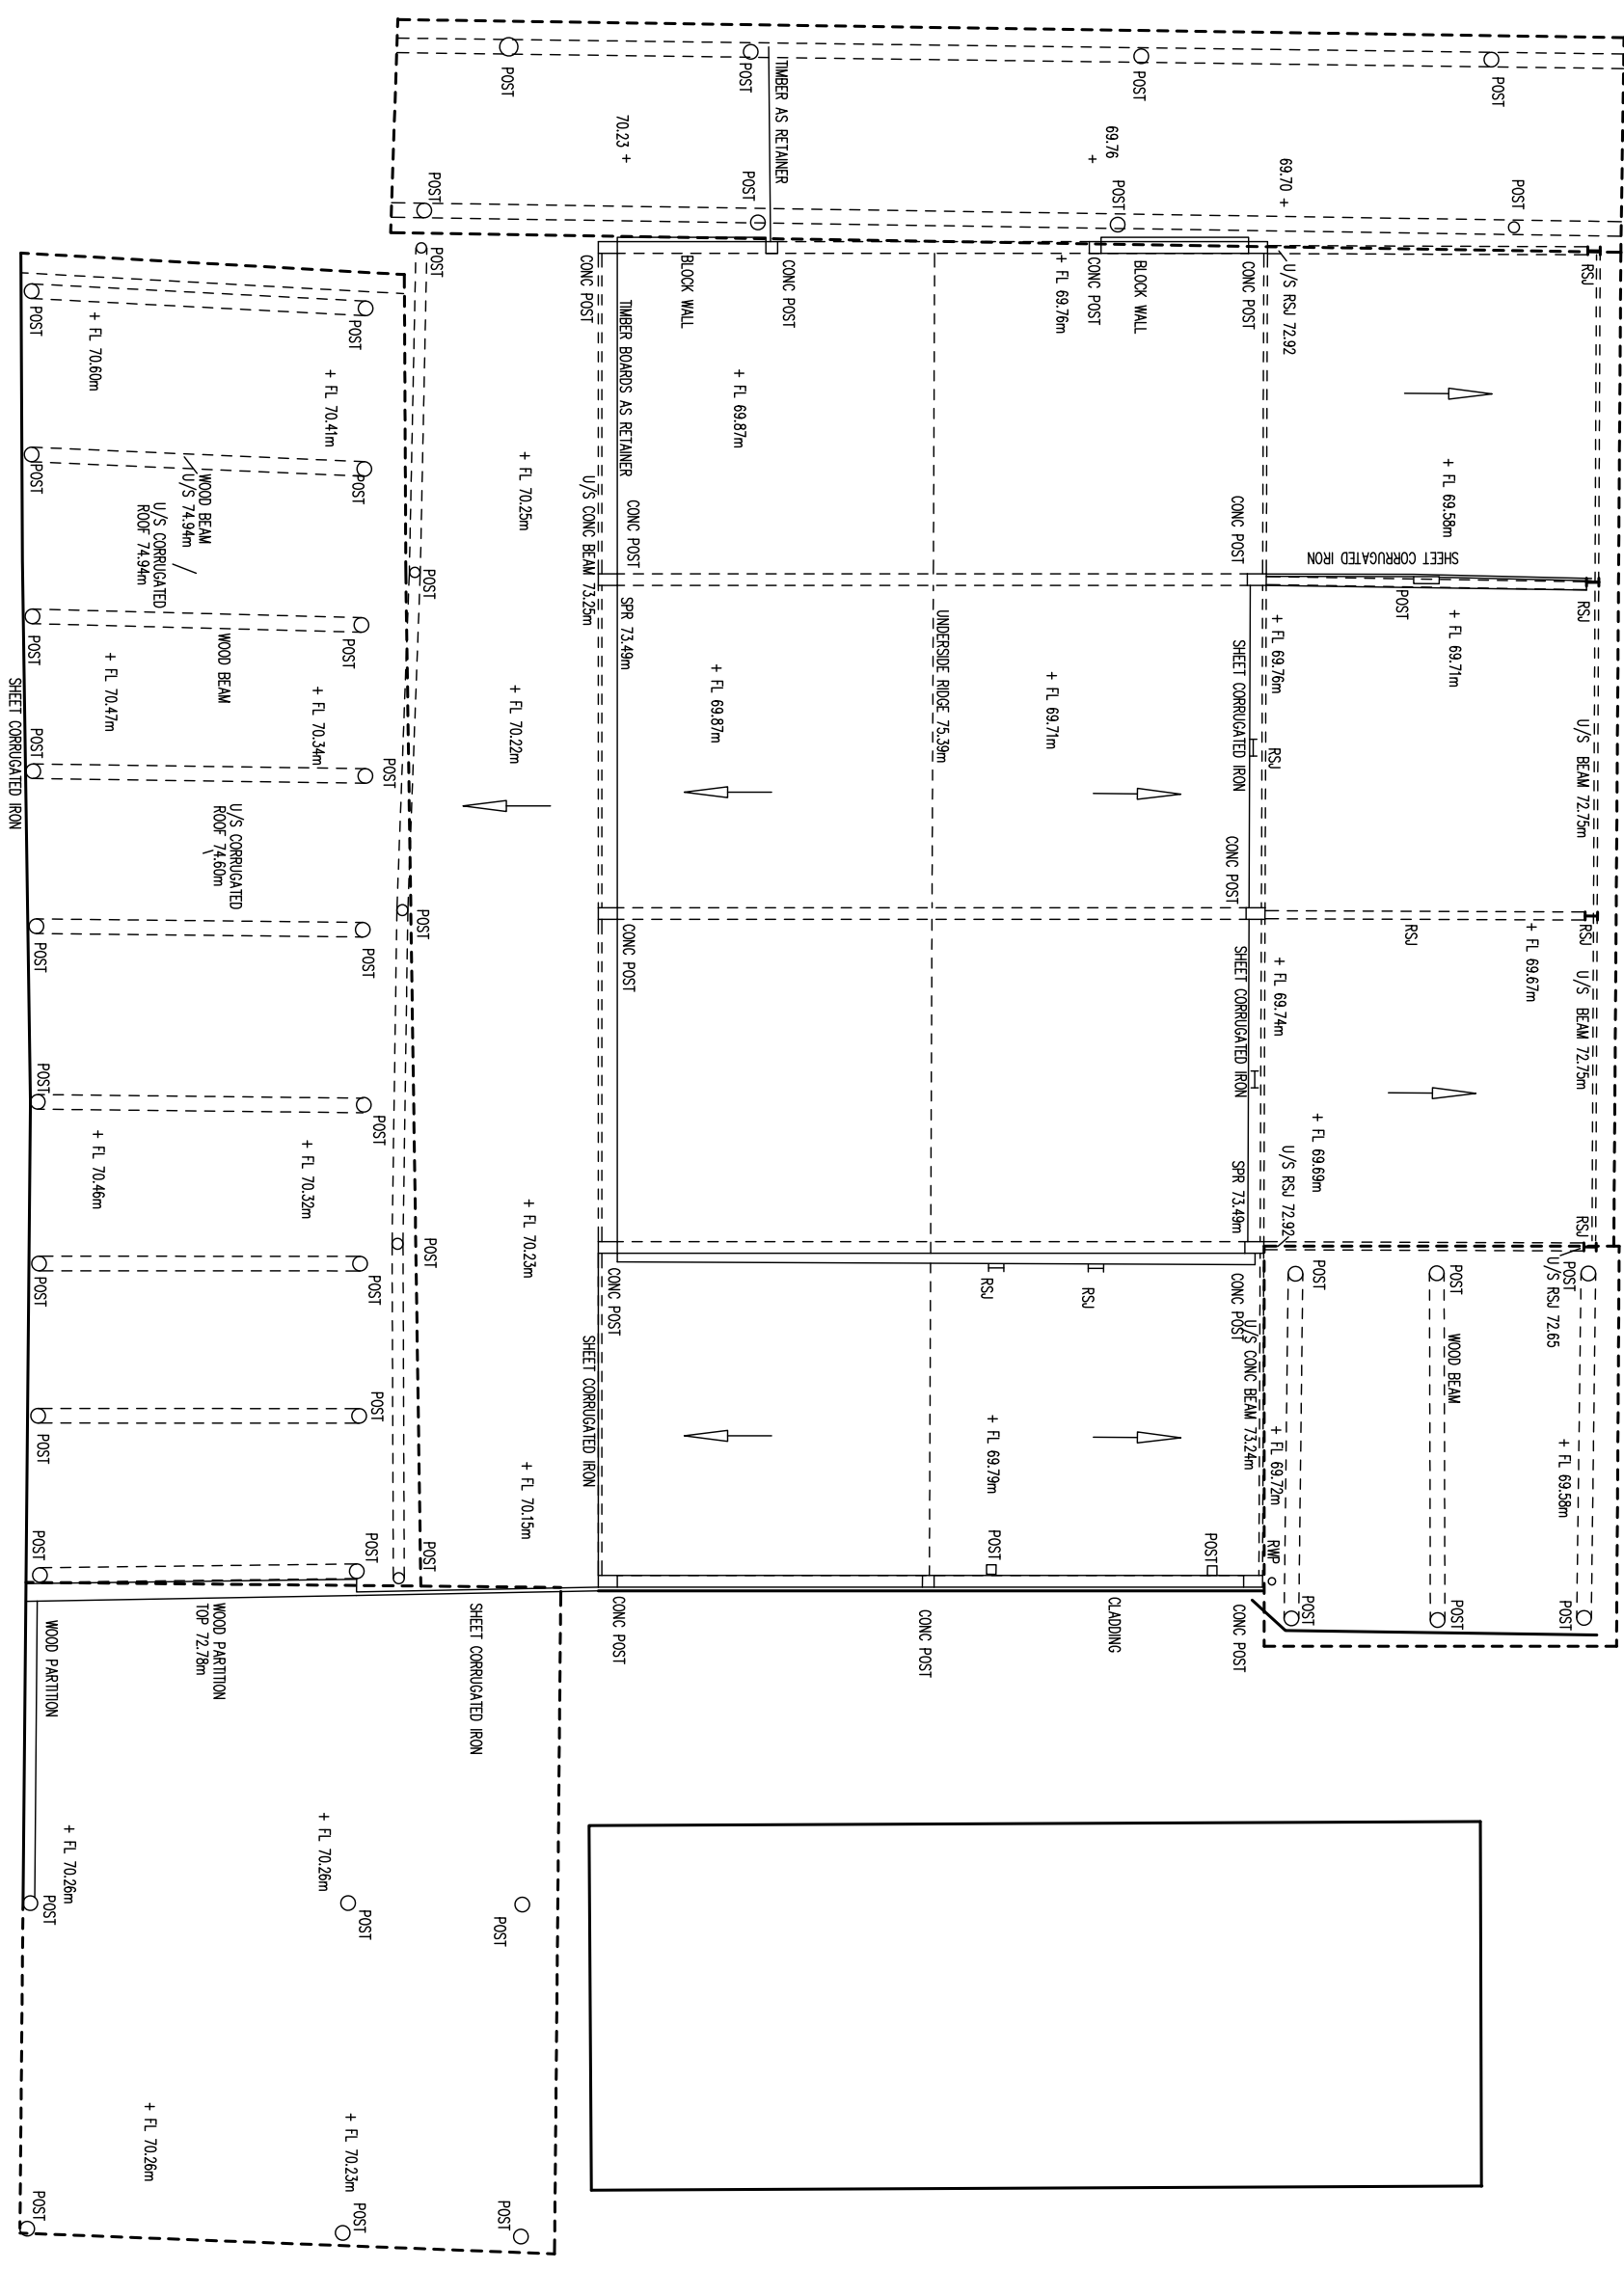
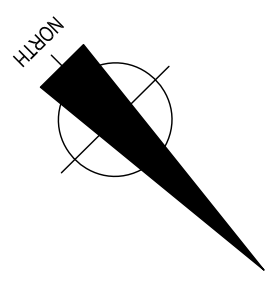
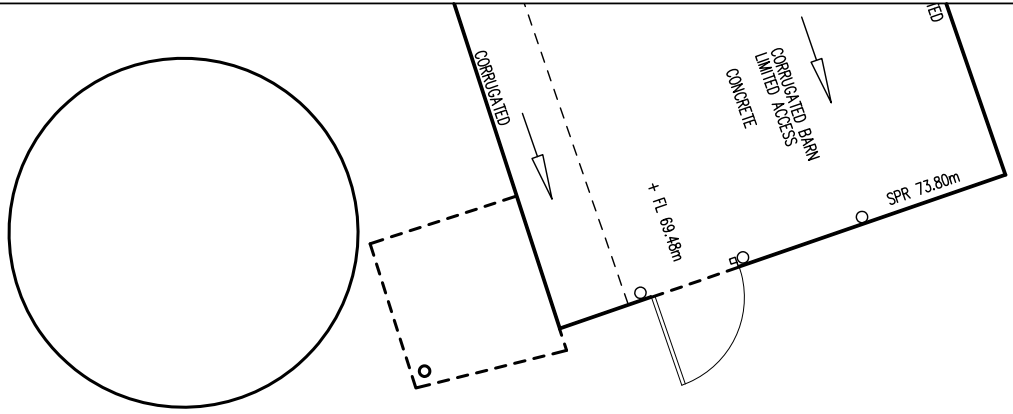


- LEGEND**
- Telephone Socket
 - Electric Mail Socket
 - TV Aerial Socket
 - Fire Alarm Break Glass
 - Fire Alarm Sounder
 - Fire Extinguisher
 - Smoke Detector
 - Illuminated Fire Exit Sign
 - Single Supply Socket
 - Double Supply Socket
 - Single Core Light Switch
 - Pulsed Switch
 - Radiator
 - Key symbol for Direction of Sloping Ceilings
 - Key symbol - Up Direction of Steps, Floors etc
 - Key symbol for Floor To Ceiling Heights
 - Walls & Solid Detail
 - Change in floor Construction etc
 - "Hidden Detail" Under Steps etc
 - Overhead Beams, Roof Lights etc
 - +FTL 1.00
 - Finished floor level value
 - SILL 1.00
 - Height of window sill and window head from FL
 - HEAD 2.00

NOTES

SURVEY TIED INTO NATIONAL GRID OSTN42 AND OSGM42 DATUM FOR HEIGHT USING GPS EQUIPMENT UTILIZING THE TRIMBLE VRS NOW SYSTEM FOR REAL TIME KINEMATIC (RTK) CORRECTIONS NATIONAL GRID SCALE FACTOR HAS NOT BEEN APPLIED TO THE SURVEY UNLESS SPECIFIED

DRAINAGE AND SERVICE INFORMATION SHOWN ON THIS SURVEY HAS BEEN OBTAINED BY VISUAL INSPECTION ONLY, ALTHOUGH ALL POSSIBLE CARE HAS BEEN TAKEN TO ENSURE THAT DETAILS SHOWN ARE CORRECT, WE ARE UNABLE TO ACCEPT ANY RESPONSIBILITY FOR COSTS ARISING OUT OF ANY ERRORS OR OMISSIONS. COPYRIGHT: THIS DRAWING MAY NOT BE REPRODUCED IN ANY FORM WHATSOEVER WITHOUT THE CONSENT OF C J SURVEYS LTD.

C J SURVEYS LTD

LAND | BUILDING | ENGINEERING
PROFESSIONAL MEASURED SURVEYS

Tel: 01628 591031 Mobile: 07945 779545
Web: www.cjsurveys.co.uk Email: mail@cjsurveys.co.uk

CLIENT: WILL TAYLOR
C/O BBR DESIGN

DATE: OCT 2023
DRAWN: M/CJ
SHEET SIZE SCALE: A1 1:100
DRAWING NO. 10923/FP1

PROJECT: FLOOR PLAN
CHARLTON BARNS, CHARLTON, HITCHIN