


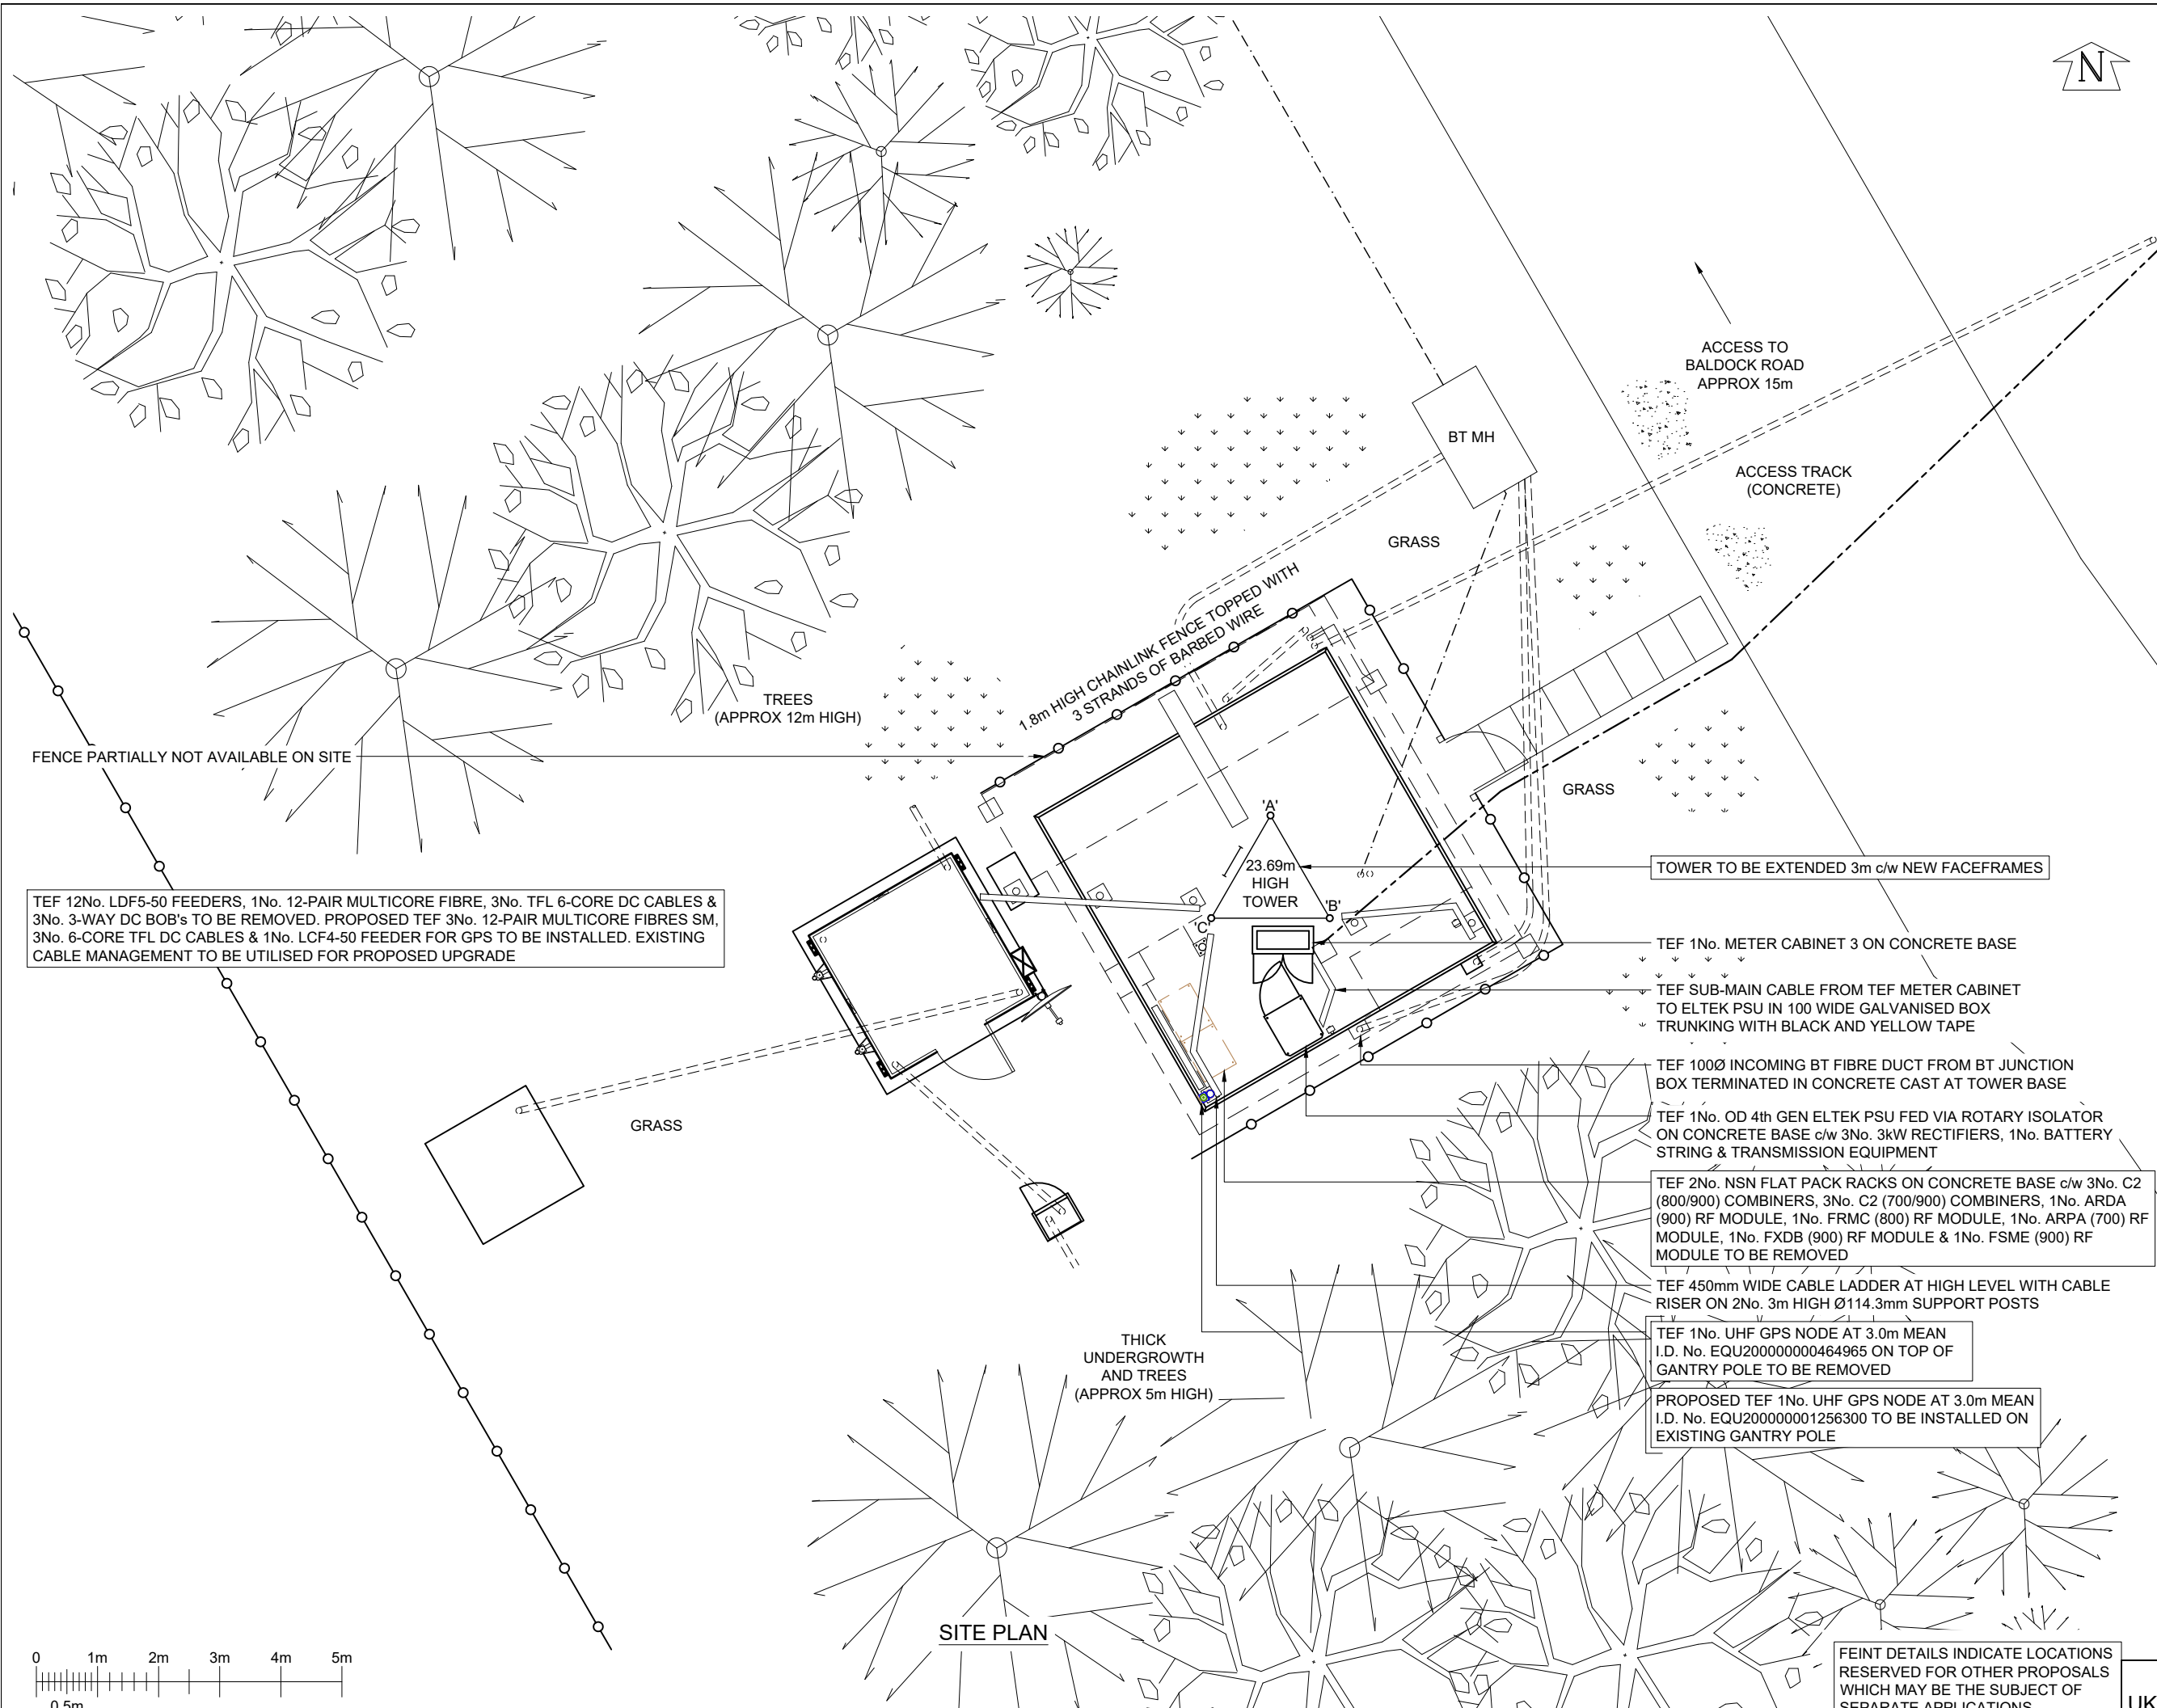

©2020 Cellnex
All rights reserved. No part of this publication may be reproduced, stored in a retrieval system or transmitted in any form or by any means (Electronic, Mechanical, Photocopying, Recording or otherwise), without the prior written consent of the Company.

NOTES

PROX 5 NOTE:
PRO X5 COMPLETED ON 13/02/2026
AND DEEMS THAT THE SITE
ACHIEVES ICNIRP COMPLIANCE
RF CODE: O2H(5+0)v4
EMF CODE: 10_VM_4.9_CX_CB_F_0

CELLNEX RFST NOTE:
N/A

THIS DESIGN COMPLIES WITH
CELLNEX ICNIRP STANDARD
UK-DE PRO-0020


REGION SPLIT	EAST_MORAN			
SITEFLO PROJ No.	200010601			
PROJECT No.	COL.MOD.UK.0009057			
CSR	2410			
TEFID	2410			
15	COL.MOD.UK.0009057 PLANNING	01-04-26	ULC	ULC
14	COM-0023268 AS BUILT	09/01/24	GBC	MIT
13	COM-0023268 PLANNING	16/01/23	GBC	GBC
12	N/A MASTER UPDATE (ASTRA 4A)	22/02/21	PS	SH
11	141742 AS BUILT	10/09/19	PS	LBG
ISS	REVISION	DATE	DRN	APP

cellnex
driving telecom connectivity

CELLNEX UK
R+, 4TH FLOOR, 2 BLAGRAVE STREET, READING, RG1 1AZ
Tel. 020 4526 8553

SITE No	UK-HT-006783	
LEITCHWORTH (E)		
EASTERN ELECTRICITY SUB STN		
BALDOCK ROAD		
LEITCHWORTH		
HERTFORDSHIRE		
SG6 1WU		
NGR	TL 23614 32936	
OS GRID	523614 , 232936	
TITLE	SITE PLAN PROPOSED VMO2 LTD	
SCALE	1:100	
DRAWN	DJ	19/11/09
APPROVED	ULC	01-04-26
DRG No.	Sheet 1 of 1	Rev
UKHT006783-03-100-MD015	15	

A3

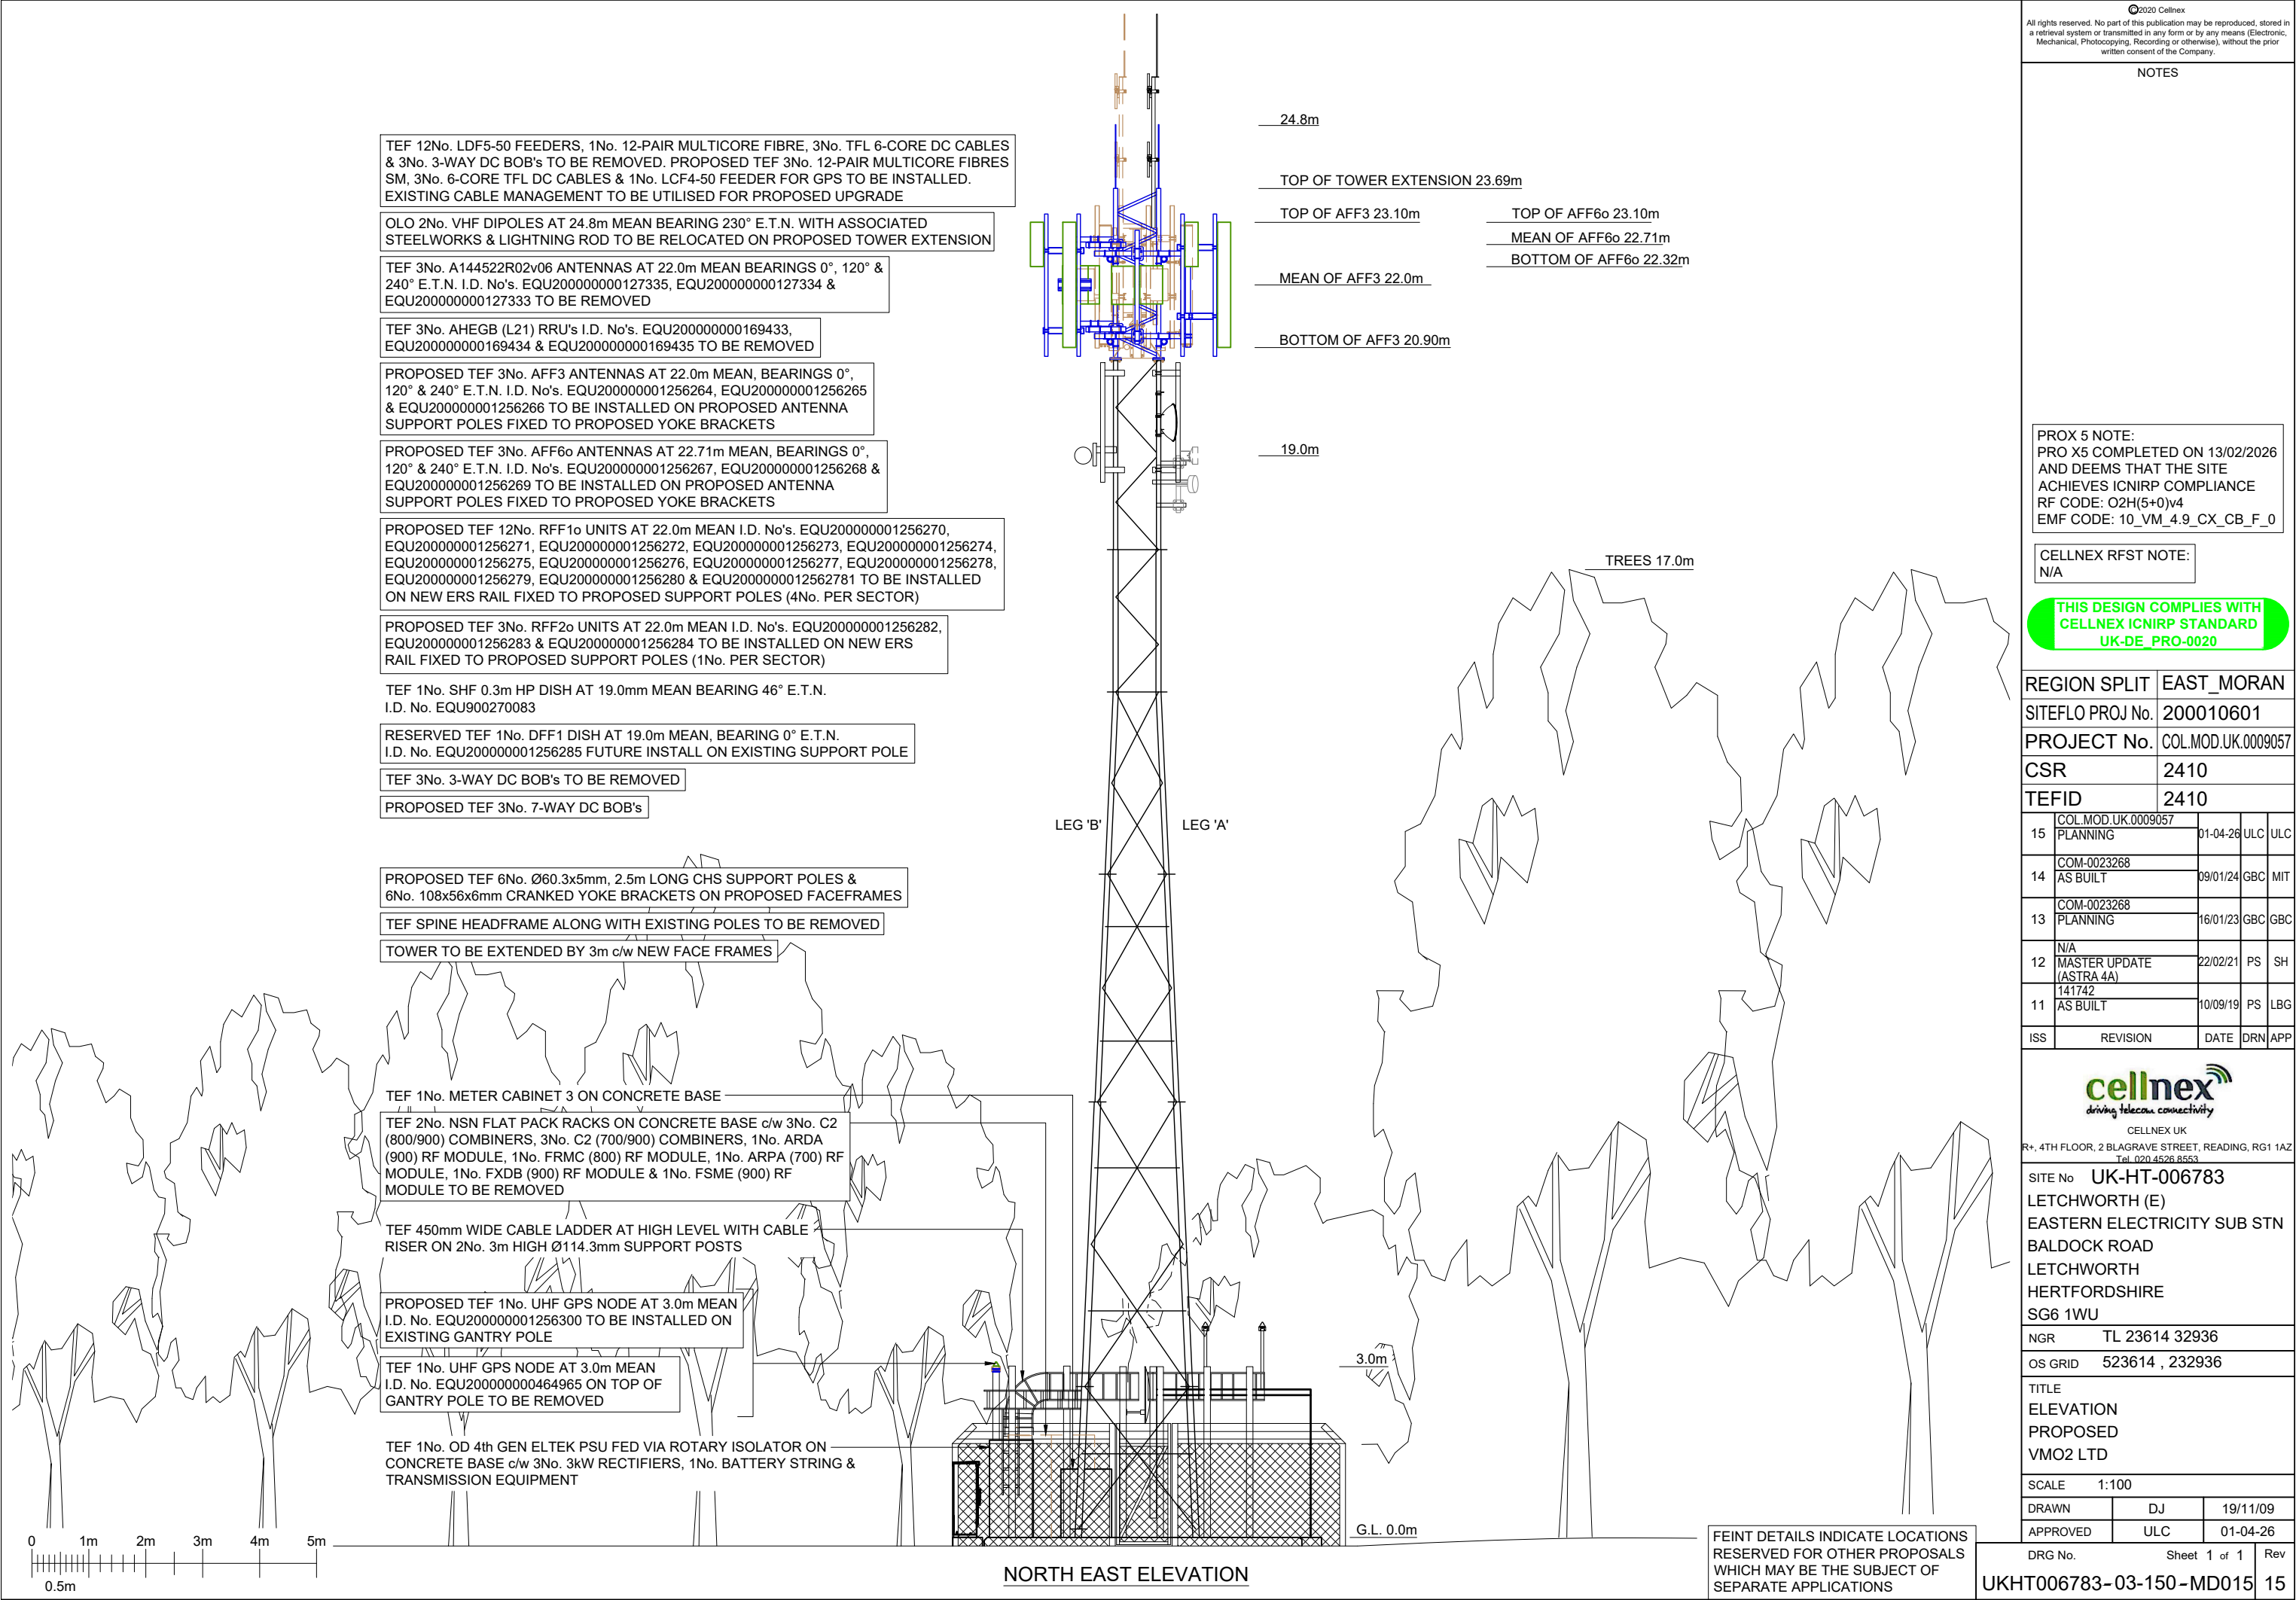

©2020 Cellnex
All rights reserved. No part of this publication may be reproduced, stored in a retrieval system or transmitted in any form or by any means (Electronic, Mechanical, Photocopying, Recording or otherwise), without the prior written consent of the Company.

NOTES

PROX 5 NOTE:
PRO X5 COMPLETED ON 13/02/2026
AND DEEMS THAT THE SITE
ACHIEVES ICNIRP COMPLIANCE
RF CODE: O2H(5+0)v4
EMF CODE: 10_VM_4.9_CX_CB_F_0

CELLNEX RFST NOTE:
N/A

THIS DESIGN COMPLIES WITH
CELLNEX ICNIRP STANDARD
UK-DE PRO-0020

REGION SPLIT		EAST_MORAN			
SITEFLO PROJ No.		200010601			
PROJECT No.		COL.MOD.UK.0009057			
CSR		2410			
TEFID		2410			
15	COL.MOD.UK.0009057 PLANNING	01-04-26	ULC	ULC	
14	COM-0023268 AS BUILT	09/01/24	GBC	MIT	
13	COM-0023268 PLANNING	16/01/23	GBC	GBC	
12	N/A MASTER UPDATE (ASTRA 4A)	22/02/21	PS	SH	
11	141742 AS BUILT	10/09/19	PS	LBG	
ISS	REVISION	DATE	DRN	APP	



driving telecom connectivity

CELLNEX UK

R+, 4TH FLOOR, 2 BLA GRAVE STREET, READING, RG1 1AZ
Tel. 020 4526 8553

SITE No			UK-HT-006783		
LETCWORTH (E)					
EASTERN ELECTRICITY SUB STN					
BALDOCK ROAD					
LETCWORTH					
HERTFORDSHIRE					
SG6 1WU					
NGR		TL 23614 32936			
OS GRID		523614 , 232936			
TITLE					
ELEVATION					
PROPOSED					
VMO2 LTD					
SCALE		1:100			
DRAWN		DJ		19/11/09	
APPROVED		ULC		01-04-26	

DRG No.		Sheet 1 of 1		Rev
UKHT006783-03-150-MD015				15