


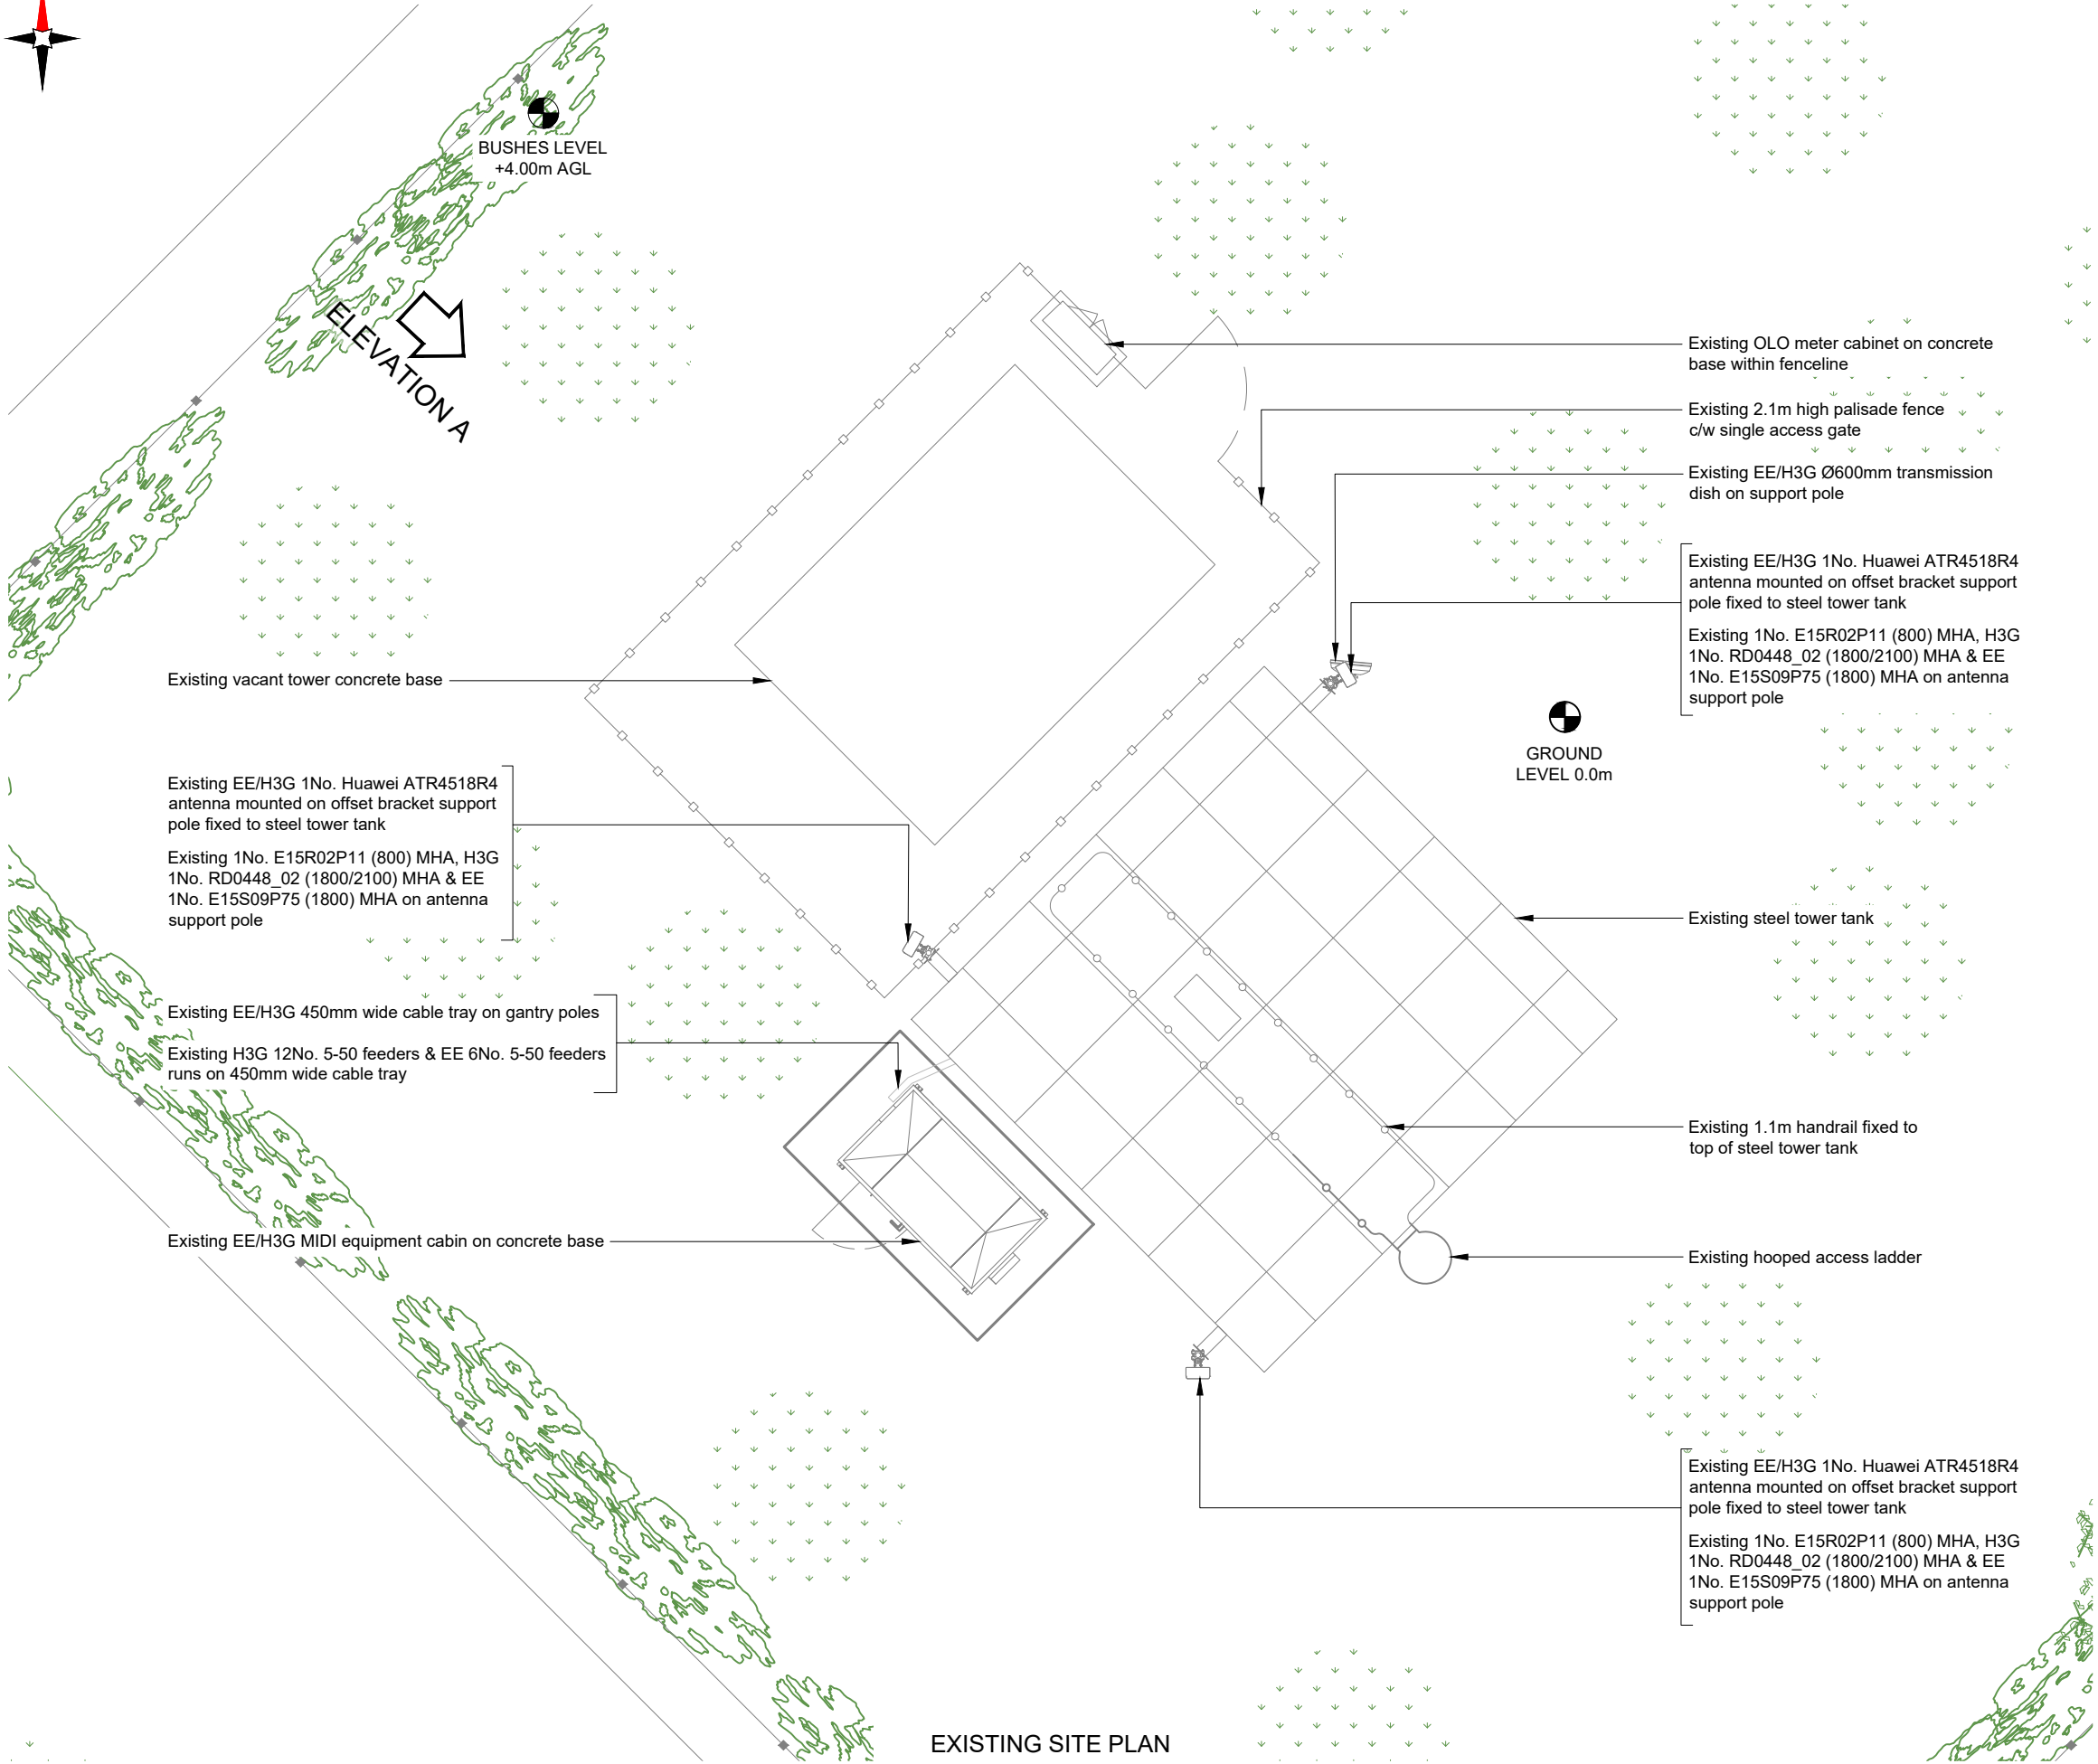

NOTES:

1. ALL DIMENSIONS IN MM UNLESS OTHERWISE NOTED.

Master:	Project:	Purpose of Issue:	Issue:
M001	Vendor Swap	Planning	A
Date:	10/06/2025	Revision / Upgrade Description:	
Drawn:	EMF	First Issue	
Checked:	KS		
Approved:	HG		



Everything Everywhere
One Braham Street
London
E1 8EE
Tel: 020 7356 5000



UK Offices:
2 Broughton Way, Widnes, UK WA8 8YX
1 West Regent Street, Glasgow, UK G2 1RW
Tel: +353 45 901 030
Web: www.ktl.ie

Site Name: PIRTON WATER TOWER

Site ID: 773532

Address: PIRTON WATER TOWER
PRIORS HILL
PIRTON HITCHIN
HERTFORDSHIRE
SG5 3QH

Title: 100 EXISTING SITE PLAN

Project: VENDOR SWAP

Purpose of Issue: GENERAL ARRANGEMENT

EE Cell ID:	MBNL Cell ID:	H3G Cell ID:
61052	NHE010	SG0219

File name: NHE010_61052_SG0219_EE_VS_GAD_A