


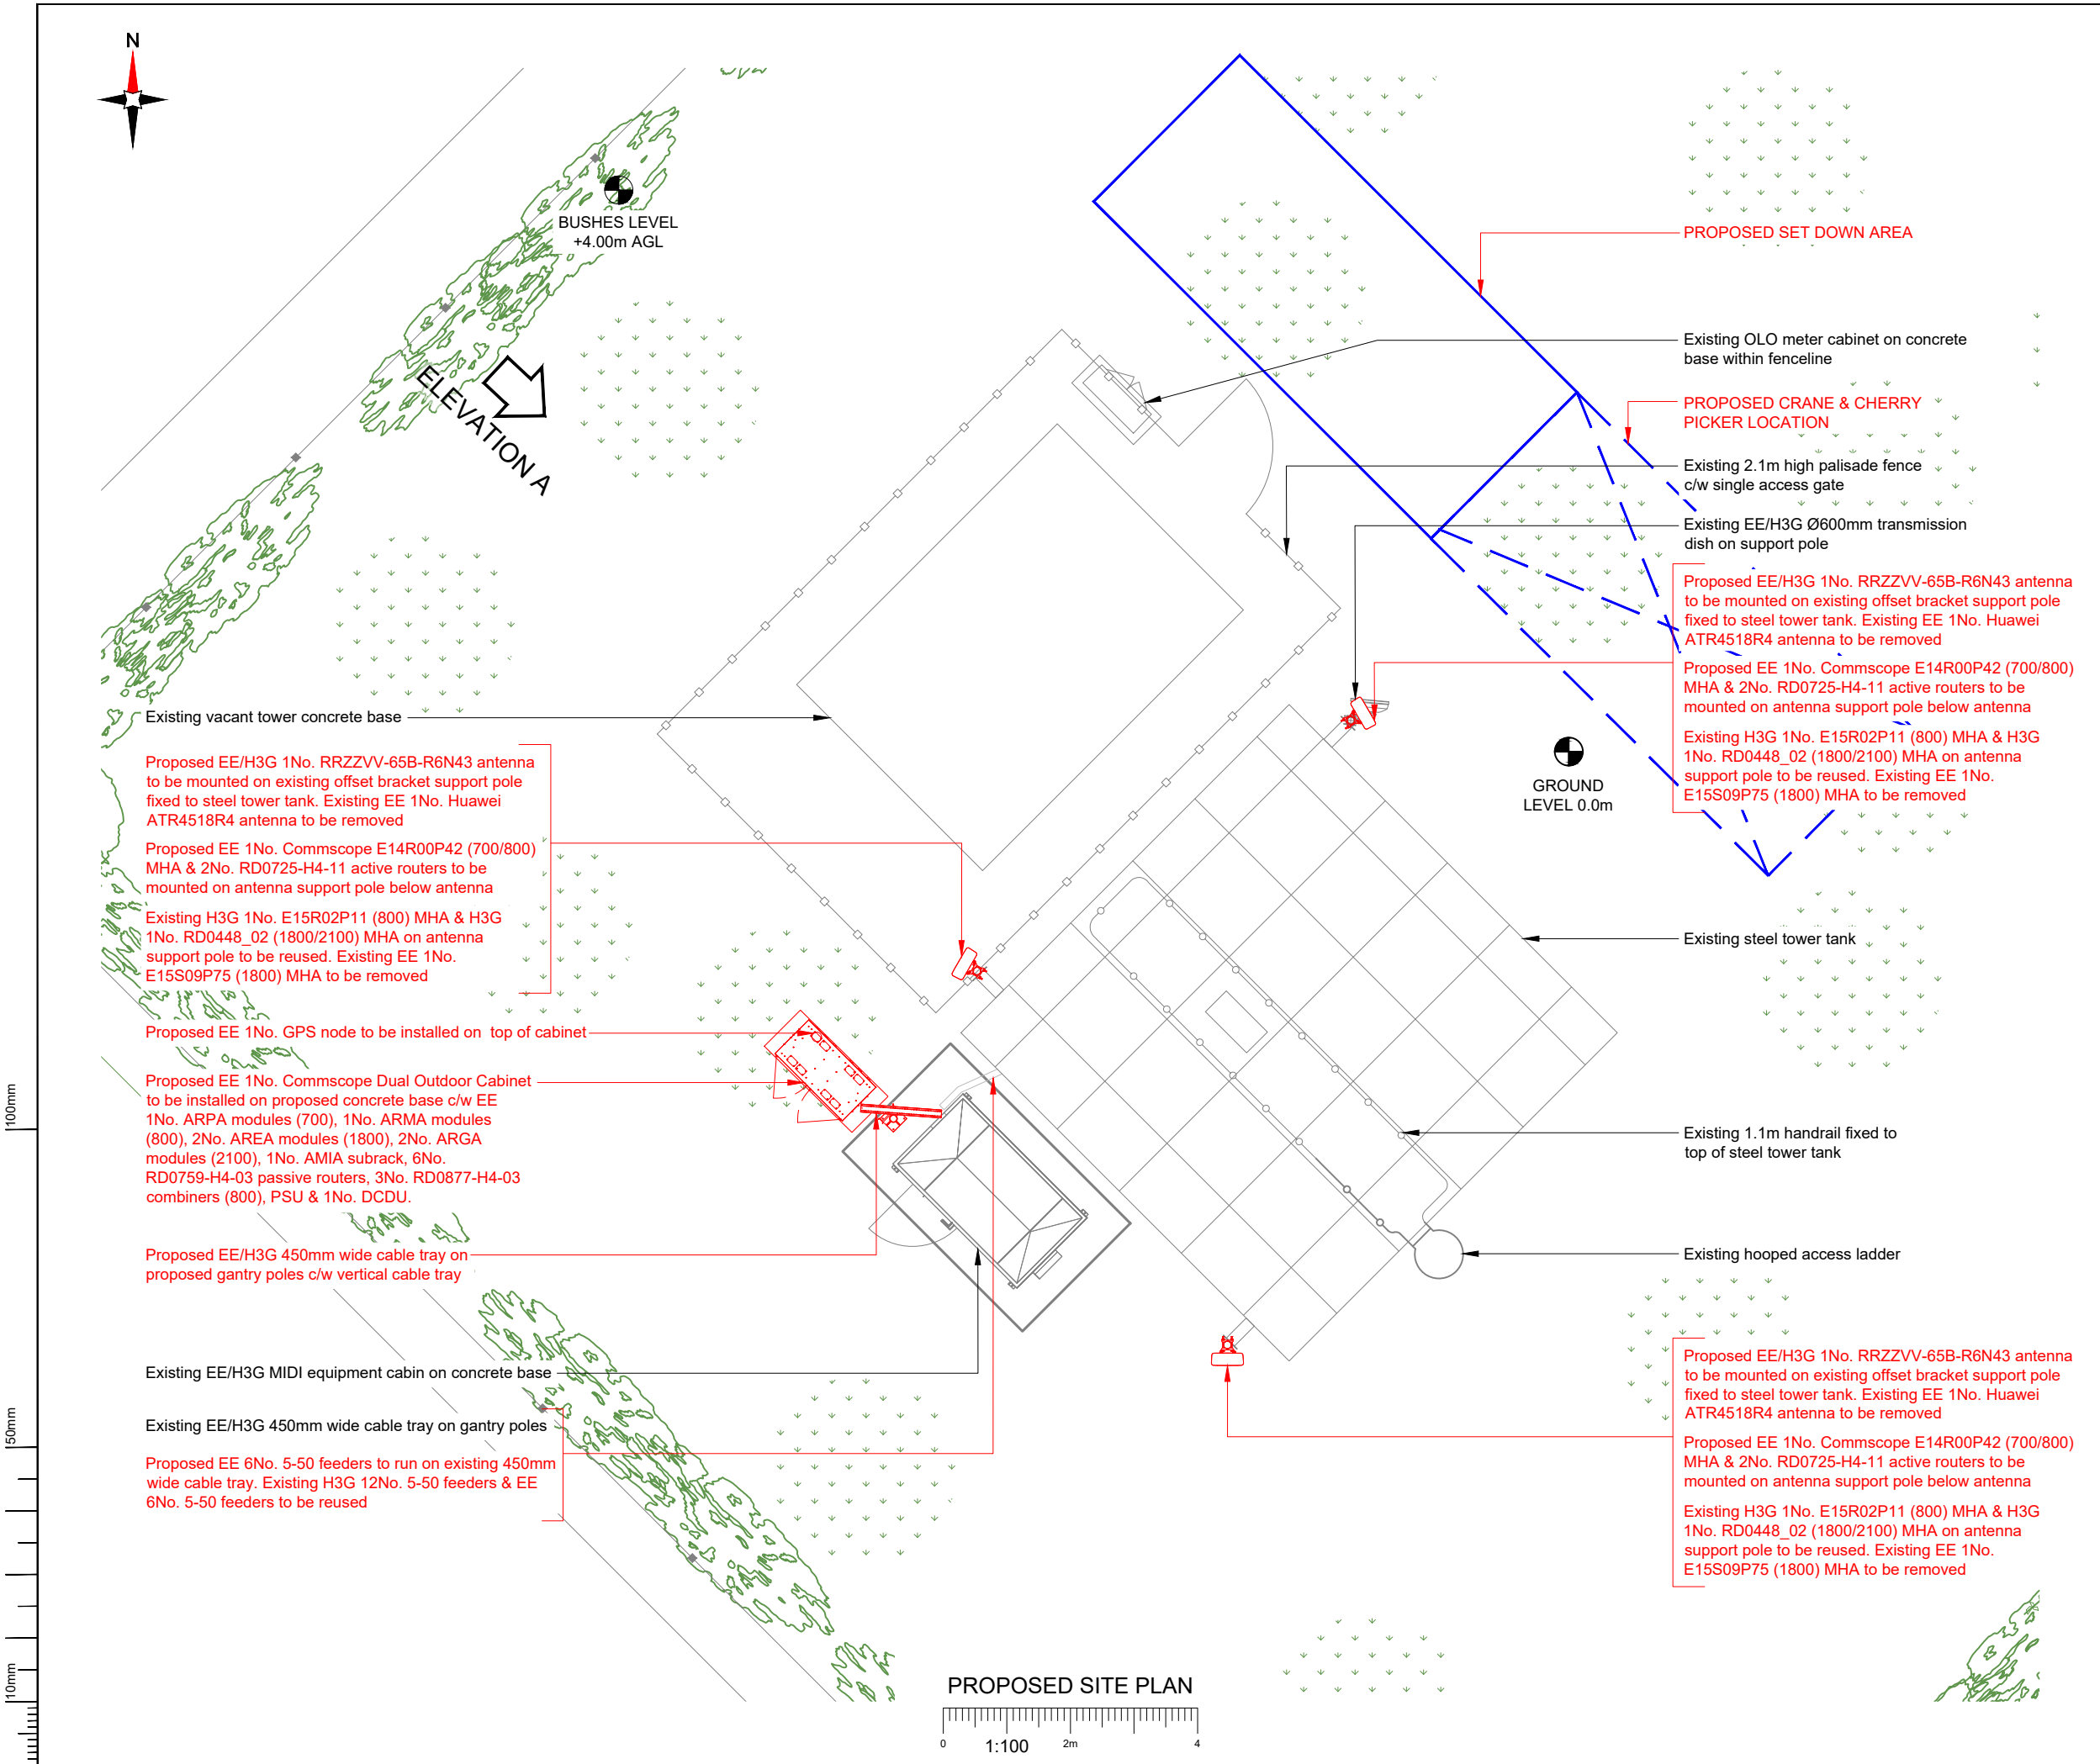

- NOTES:
- ALL DIMENSIONS IN MM UNLESS OTHERWISE NOTED.

Master:	Project:		Purpose of Issue:	Issue:
M001	Vendor Swap		Planning	A
Date:	10/06/2025	Revision / Upgrade Description:		
Drawn:	EMF	First Issue		
Checked:	KS			
Approved:	HG			



Everything Everywhere
One Braham Street
London
E1 8EE
Tel: 020 7356 5000



UK Offices:
2 Broughton Way, Widnes, UK WA8 8YX
1 West Regent Street, Glasgow, UK G2 1RW
Tel: +353 45 901 030
Web: www.ktl.ie

Site Name:	PIRTON WATER TOWER		
Site ID:	773532		
Address:	PIRTON WATER TOWER PRIORS HILL PIRTON HITCHIN HERTFORDSHIRE SG5 3QH		
Title:	150 PROPOSED SITE PLAN		
Project:	VENDOR SWAP		
Purpose of Issue:	GENERAL ARRANGEMENT		
EE Cell ID:	61052	MBNL Cell ID:	NHE010
H3G Cell ID:			SG0219
File name:	NHE010_61052_SG0219_EE_VS_GAD_A		