


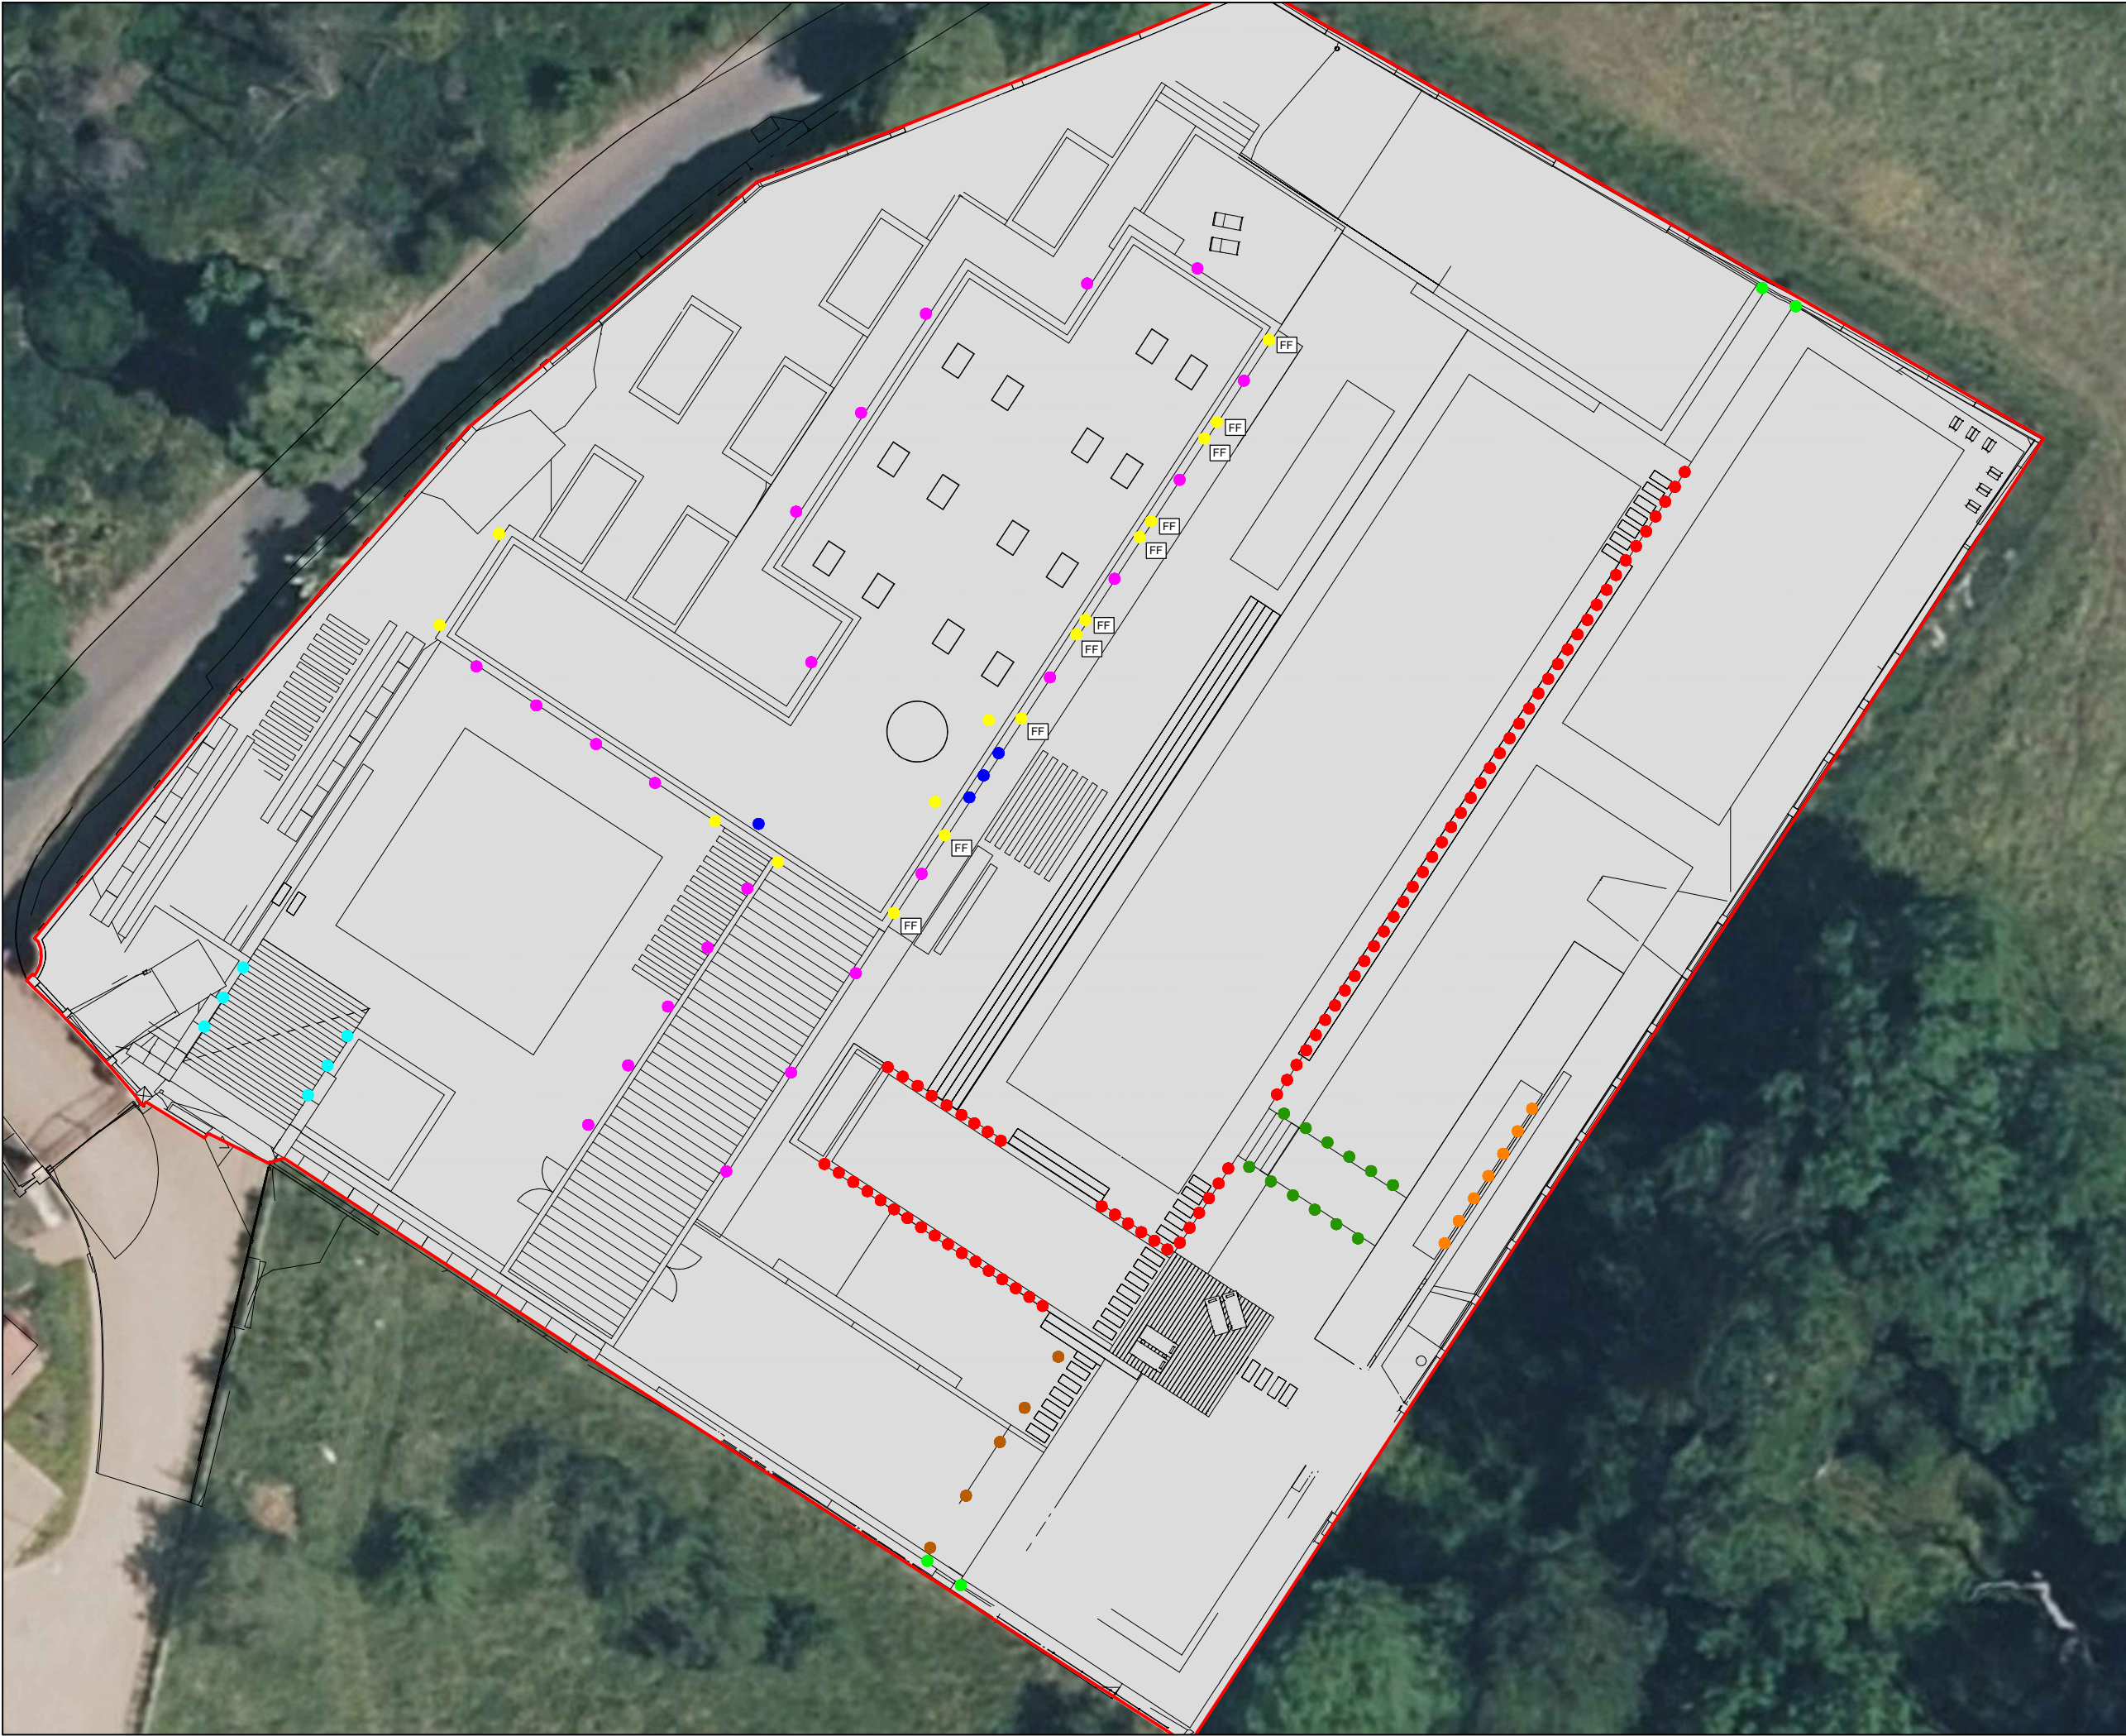

Notes:			
1. This drawing is confidential and may not be reproduced, manufactured or exploited in whole or part without written consent.			
2. Dimensions are not to be scaled from this drawing.			
3. Official issues of this drawing are in paper or pdf format only. Dwg files are for reference only.			
4. This drawing is for environmental planning purposes only and shall not be used for any other purpose.			
LUMINAIRE SCHEDULE			
BEGA 22203 K3 BEGA 22215 K3 BEGA 22228 K3 BEGA 22649 K3 BEGA 24250 K3 BEGA 33238 K3 BEGA 33285 K3 BEGA 77276 K3 BEGA 77735 K3			
FF denotes first floor level			
Rev	Date	Details	Drawn
Project		Walled Garden House	
Assessed Scheme of Lighting			
Strenger Ltd			
Date	Scale	Drawn	
JUL 24	NTS	DC	
Drawing No. SK-03			
Status	FOR ENV' PLANNING		
Checked	OC	Print	A3