
 


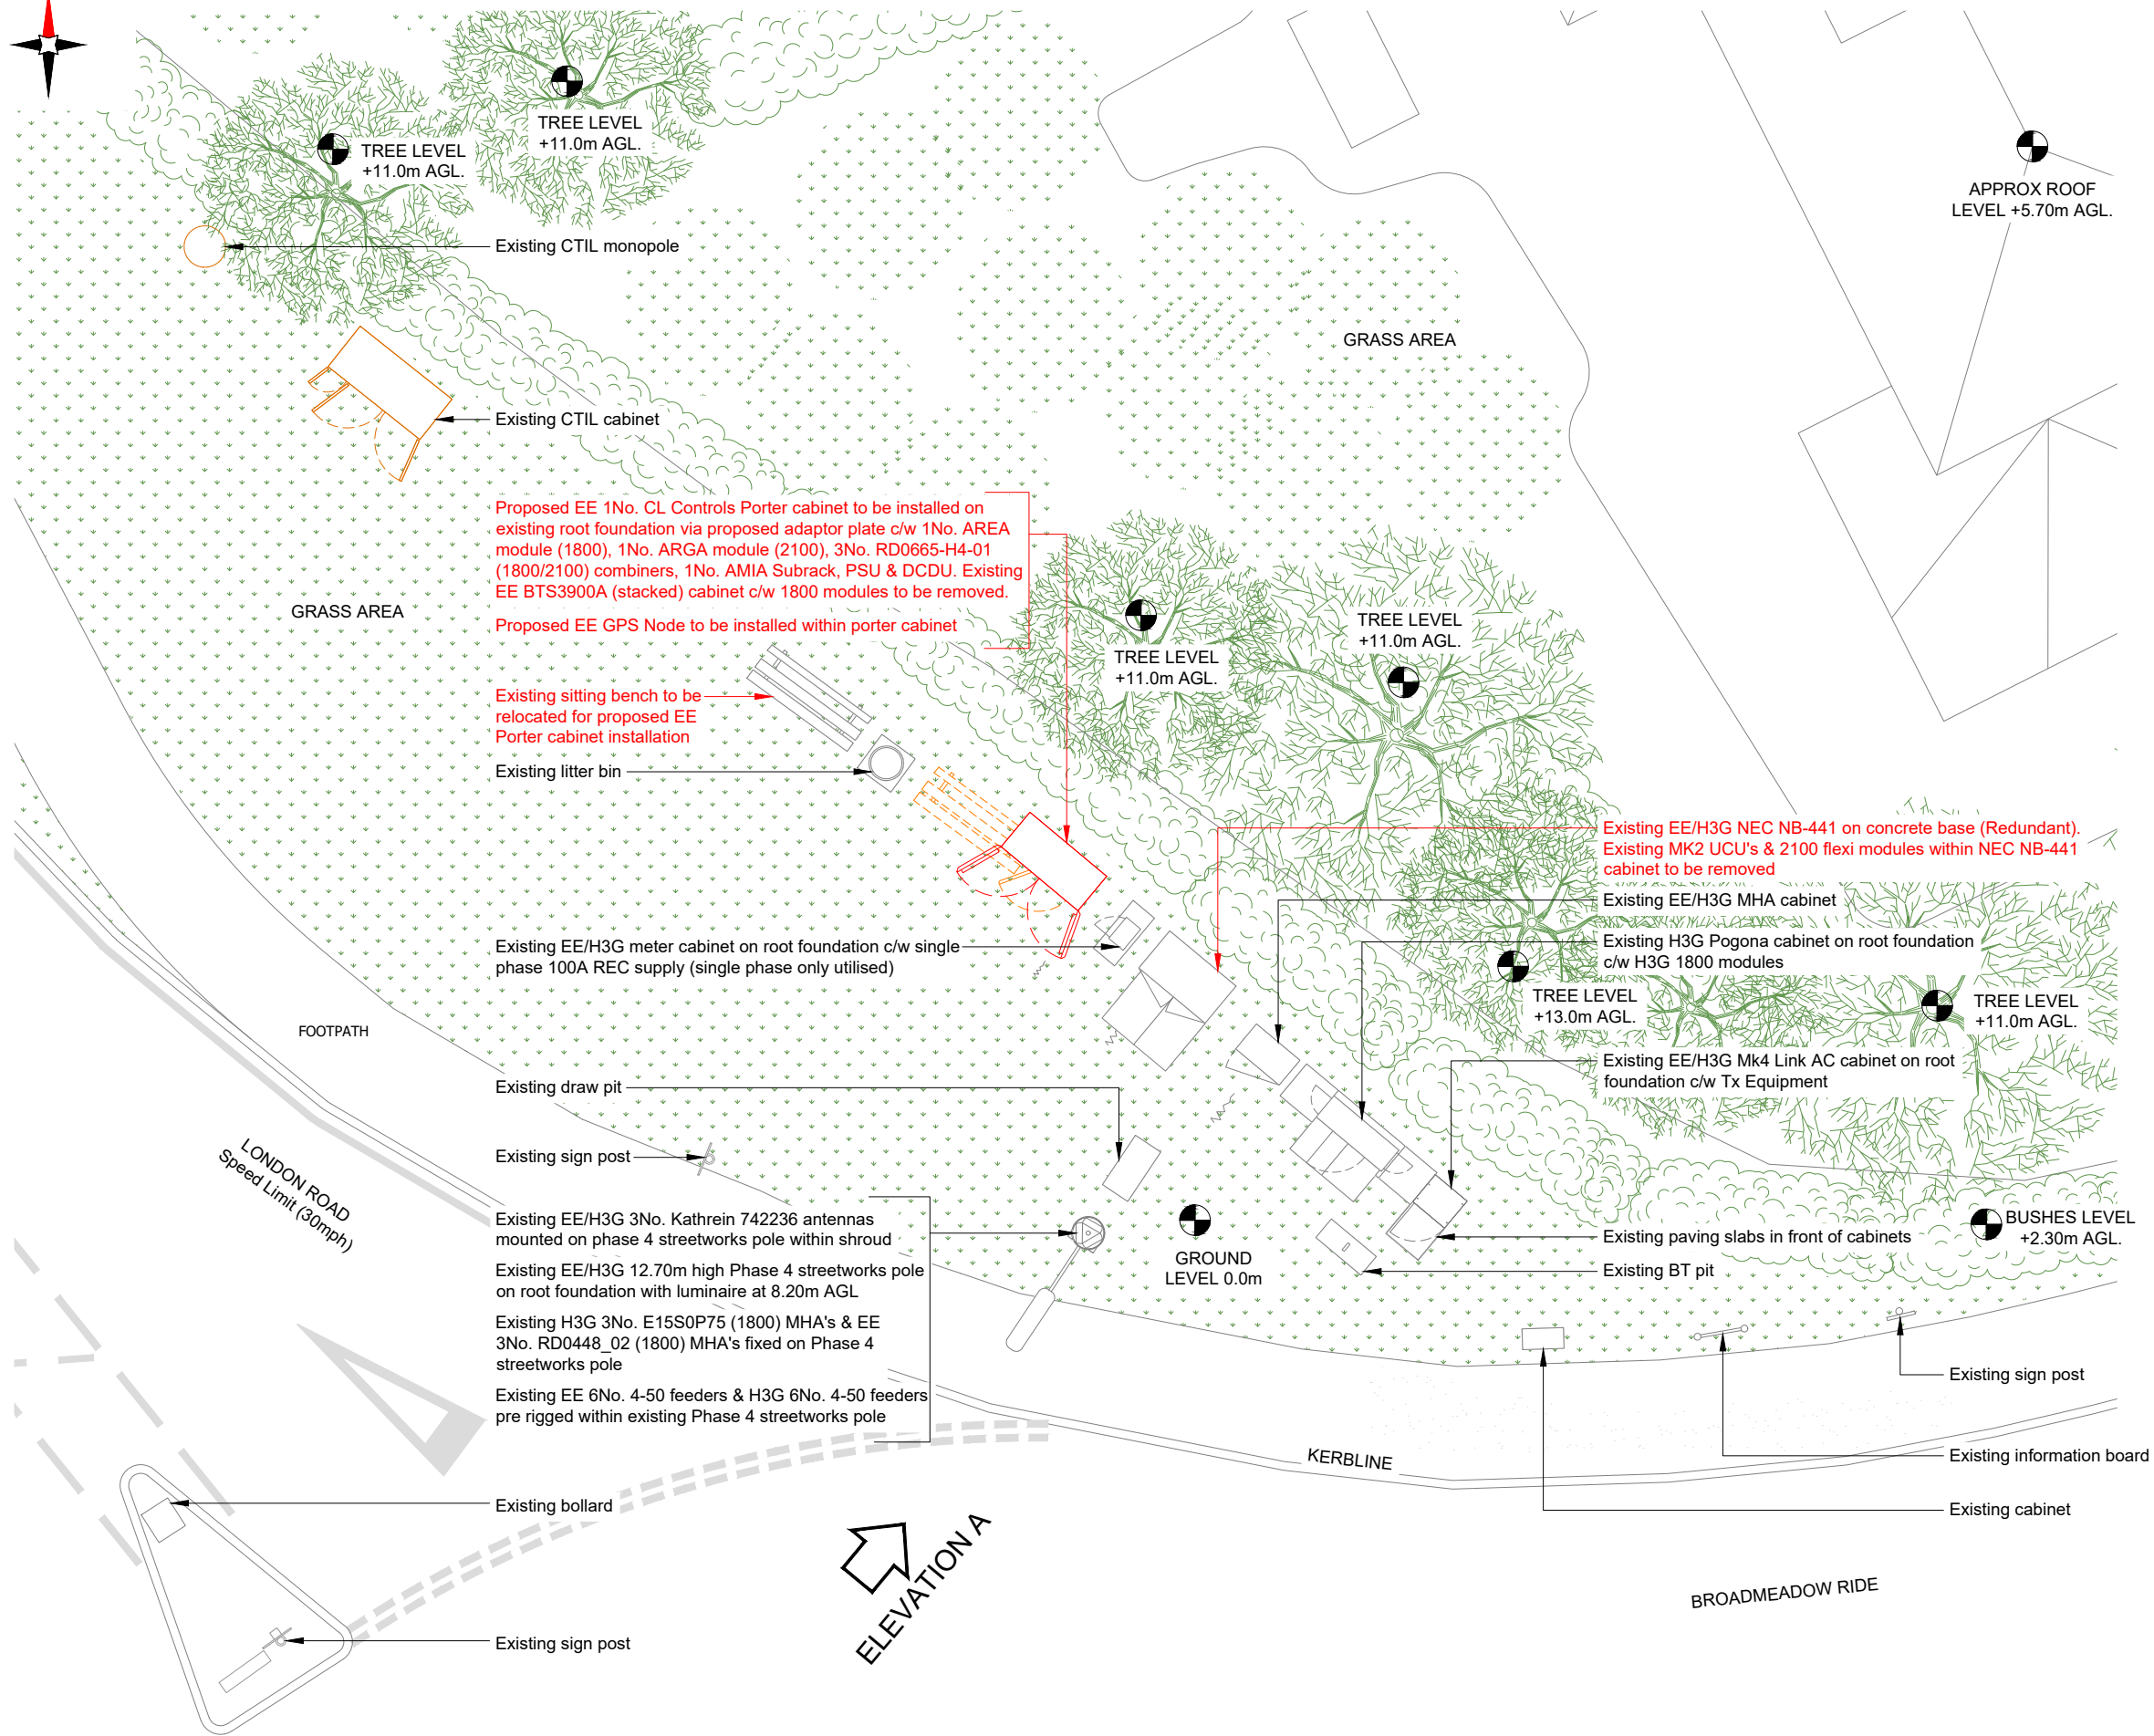

PROPOSED SITE PLAN



NOTE:
All existing feeder cables to be re-used. Subject to testing.

Master: MBNL / EE / H3G:		Project:	Purpose of Issue:	Issue:
M001	MBNL	Vendor Swap	Planning	A
Date: 27/11/2024		Revision / Upgrade Description: First Issue		
Drawn: SRM				
Checked: KS				
Approved: HG				



Hatfield Business Park
Hatfield
Hertfordshire
AL10 9BW

Tel: 01707 315000
Fax: 01707 319001

Design & Principal Consultant:



UK Office:
UBC Building, 1310 Solihull Parkway,
Birmingham Business Park, B37 7YU

Tel: +44 (0)1908 377 766
Email: info@ktl.ie

Site Name:

BROADMEADOW RISE STREETWORKS SWAPOUT

Site ID:

1108184

Address:

BROADMEADOW RISE STREETWORKS
LAMPOST NO.179
BROADMEADOW RISE
HITCHIN
SG4 7SS

Title:

150 PROPOSED SITE PLAN

Project:

VENDOR SWAP

Purpose of Issue:	
-------------------	--

of Issue:

GENERAL ARRANGEMENT

EE Cell ID: 26272	MBNL Cell ID: NHE040	3UK Cell ID: SG0039
-----------------------------	--------------------------------	-------------------------------

Master Drawing No:

1108184_NHE040_26272_SG0039_M001

Issue: