



Schedule					
Symbol	Label	Quantity	Catalog Number	Description	Wattage
	A1	5	DSX1.4.LA224.AY (TZ)	D-Series 1 - Area luminaire on 8m Column	145
	B1s	2	DSX1.4.LA224.FWE.(DSX1.60LED.BLS) (TZ)	D-Series 1 - Area luminaire with back light shield on 8m Column	145
	CW	5	DSX0.4.LA184.FWE (TZ)	D-Series 0 - Area luminaire on Wall Bracket at 130 8m AFFL	
	D	2	WAP.1.LA094.HA	WALLPACK at 6m AFFL	81
	E	3	WAP.1.LA064.FW	WALLPACK at 8m AFFL	50
	F	10	TBHF.POL.1.7026AR4030GL	7026 - POLAR 1 30W MOD. AR 4000K at 5m30 Zero Tilt	
	G	23	DWL.1.LA014.HN.W007	Denver ID Wall at 3m AFFL	6.5
	H	2	DWL.1.LA024.AY.W011	Denver ID Wall at 3m AFFL	10.3

Statistics					
Description	Symbol	Avg	Min	Min/Avg	
Shared Access Road (Landlords) 20/0.40Uo	+	20 lux	8 lux	0.40	
Unit 1 Car Park - 10/0.25Uo	+	14 lux	7 lux	0.50	
Unit 1 Cycles	+	7 lux	5 lux	0.71	
Unit 1 Dock Doors	+	58 lux	21 lux	0.36	
Unit 1 Dock Doors - 50/0.40Uo	+	50 lux	21 lux	0.42	
Unit 1 Rear Walkway - 10/0.40Uo	+	12 lux	8 lux	0.67	
Unit 1 Service Yard - 20/0.40Uo	+	27 lux	11 lux	0.41	
Unit 2 Car Park - 10/0.25Uo	+	11 lux	6 lux	0.55	
Unit 2 Cycles	+	7 lux	7 lux	1.00	
Unit 2 Dock Doors - 50/0.40Uo	+	50 lux	20 lux	0.40	
Unit 2 Rear Walkway - 10/0.40Uo	+	10 lux	7 lux	0.70	
Unit 2 Service Yard - 20/0.40Uo	+	23 lux	10 lux	0.43	
Unit 3 Car Park - 10/0.25Uo	+	11 lux	3 lux	0.27	
Unit 3 Cycles	+	11 lux	10 lux	0.91	
Unit 3 Dock Doors - 50/0.40Uo	+	72 lux	30 lux	0.42	
Unit 3 Rear Walkway - 10/0.40Uo	+	10 lux	8 lux	0.80	
Unit 3 Service Yard - 20/0.40Uo	+	20 lux	8 lux	0.40	
Unit 3 Yard Access - 20/0.40Uo	+	20 lux	10 lux	0.50	
Unit 3 Yard Car Park - 10/0.25Uo	+	14 lux	8 lux	0.57	

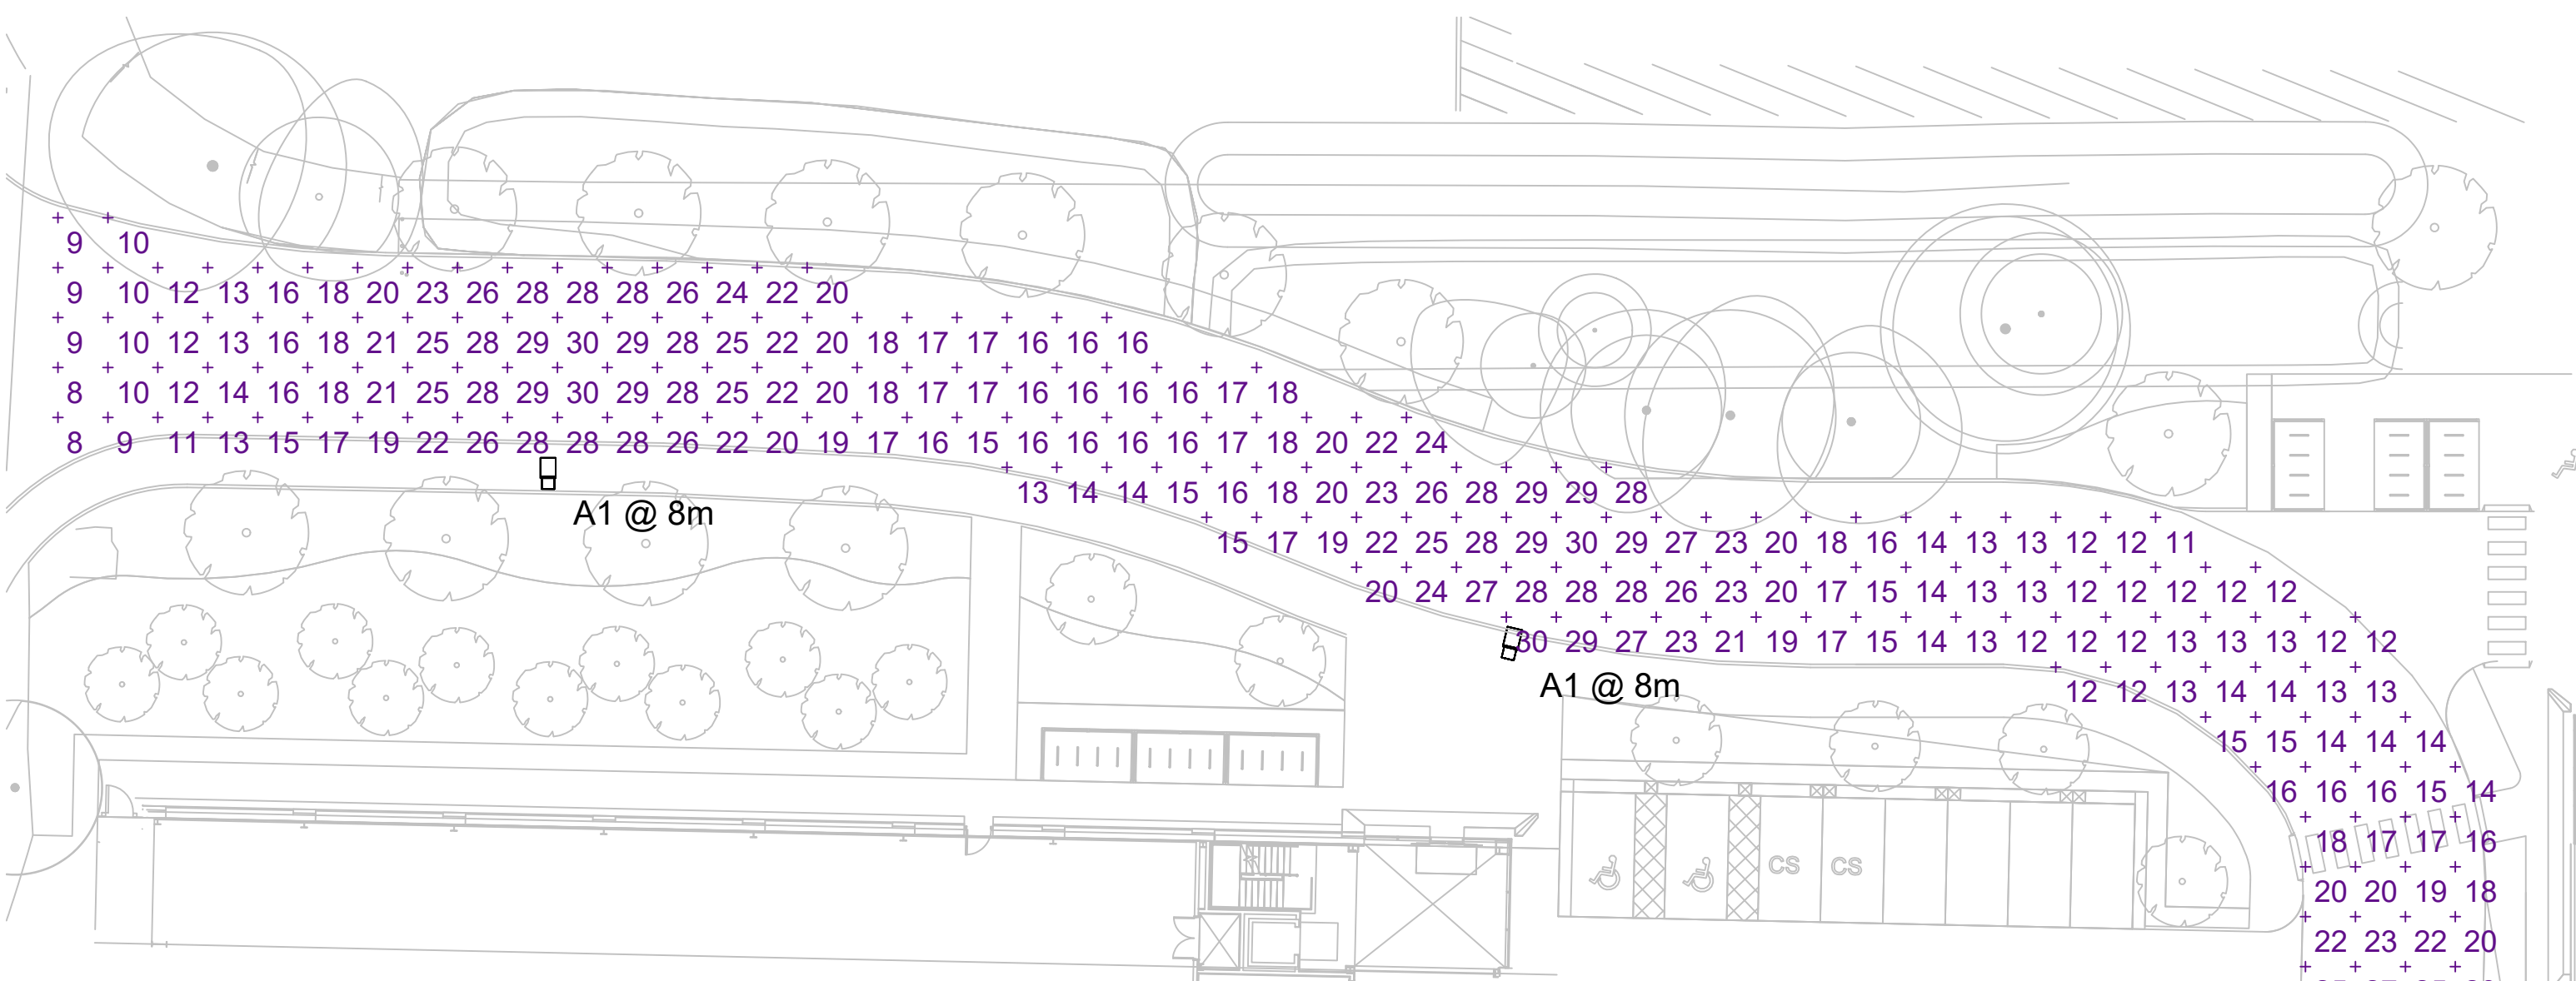

- NOTES
- THIS DRAWING SHALL BE READ IN CONJUNCTION WITH ALL OTHER MAE SERVICES DRAWINGS, SCHEDULES & SPECIFICATIONS, TOGETHER WITH THE ARCHITECTS & STRUCTURAL DRAWINGS.
 - MBA CONSULTS LIMITED HAVE NO RESPONSIBILITY FOR ANY USE MADE OF THIS DRAWING OTHER THAN FOR THAT WHICH IT WAS PREPARED AND ISSUED.
 - DO NOT SCALE FROM THIS DRAWING. WORK TO MEASURED DIMENSIONS ONLY.
 - ANY DISCREPANCIES, ERRORS OR OMISSIONS ARE TO BE CLARIFIED WITH THE RELEVANT ENGINEER AT THE EARLIEST OPPORTUNITY.
 - ALL WORKS ARE TO BE IN ACCORDANCE WITH THE CURRENT RELEVANT STATUTORY REGULATIONS, BUILDING REGULATIONS, BRITISH STANDARDS, ACCEPTED CODES OF PRACTICE AND TRADE ASSOCIATION REQUIREMENTS.
 - FOR DETAILS OF SYMBOLS AND LINE STYLES USED IN THE DRAWINGS, PLEASE REFER TO THE LEGEND SHEETS.

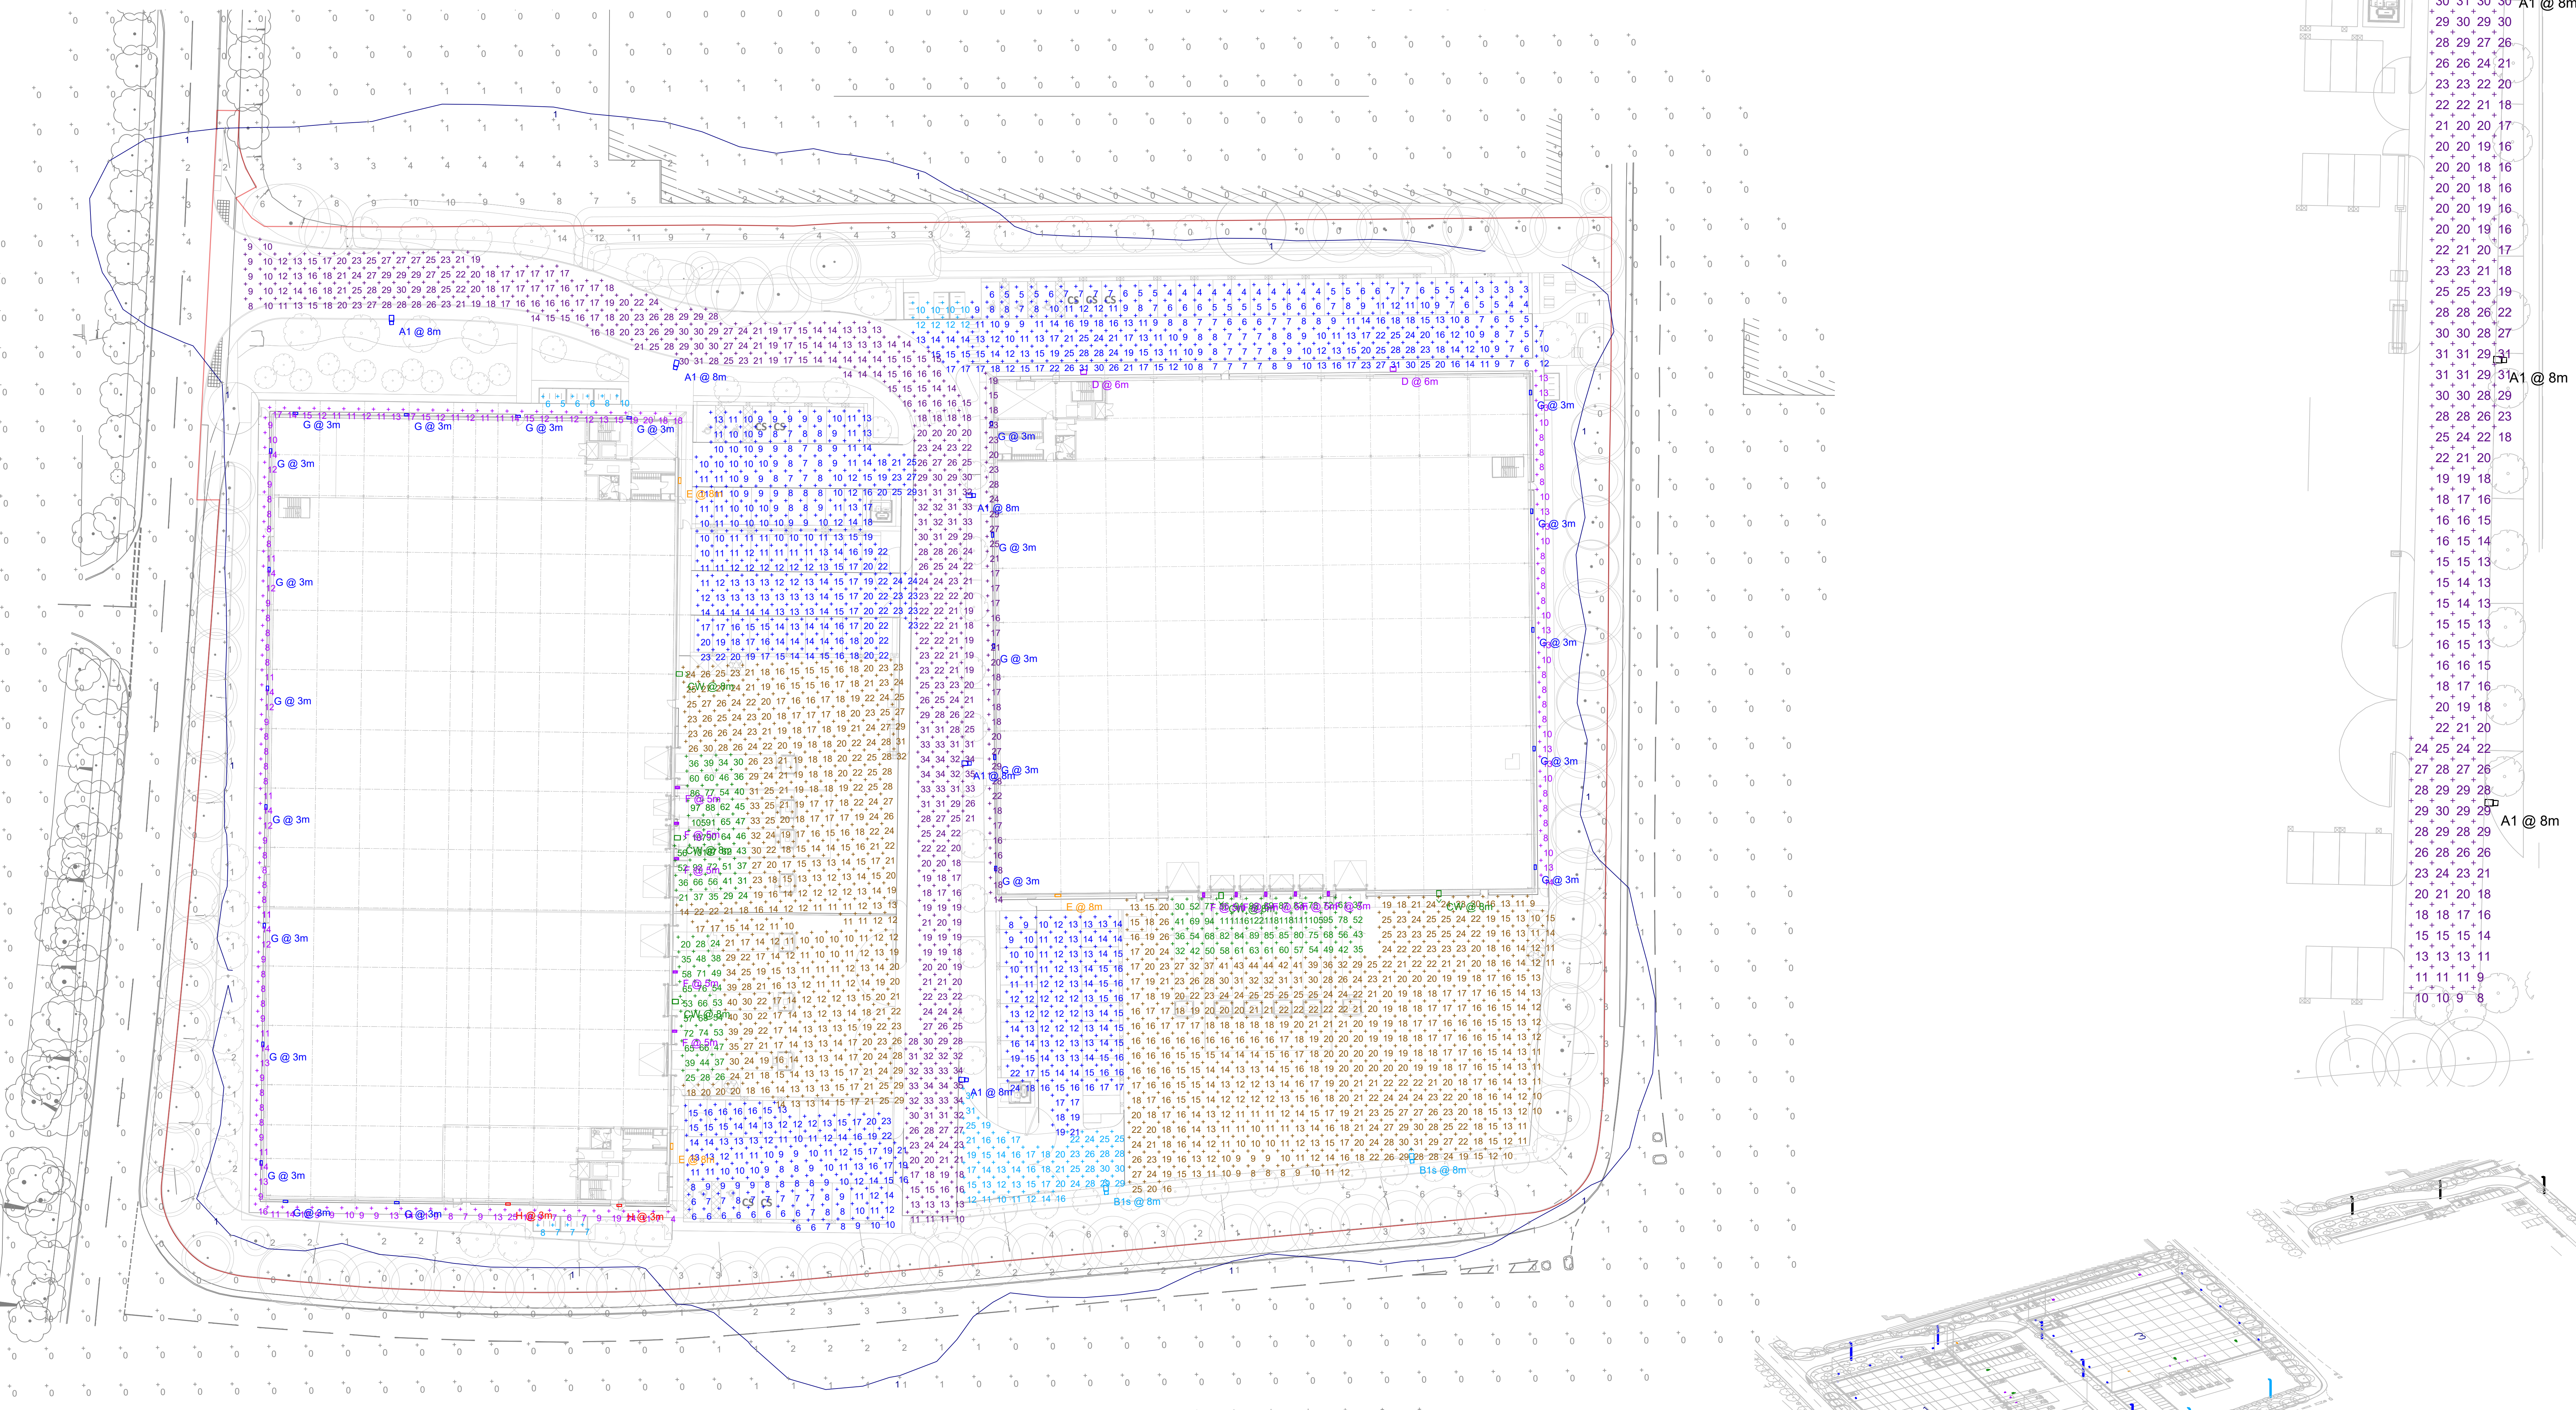


EXTERNAL LIGHTING LAYOUT

Scale 1:350 @ A0

South West View

Scale 1:350 @ A0

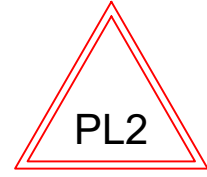

PL2	1604/25	GENERAL UPDATE	RH
PL1	3103/25	FIRST ISSUE - FOR REVIEW	RH
REV	DATE	AMENDMENTS	APPROD
MBA CONSULTS LIMITED 1604 Wood West, Milton Keynes MK14 6PG Telephone: +44 (0) 1908 320 099 Email: enquiries@mbaconsultants.co.uk Web: www.mbaconsultants.co.uk			

CLIENT: WRENBRIDGE

PROJECT: AVENUE ONE, LETCHWORTH

TITLE: EXTERNAL LIGHTING LAYOUT

DRAWING NUMBER: 25020-MBA-EX-SP-DR-E-0001

REV	PL2	STATUS	PLANNING	FLOOR	SITE
SCALE	1:350	DATE	APR 2025	PROJECT NO	25-020