


Rev:	Description:	By:	Date:
------	--------------	-----	-------

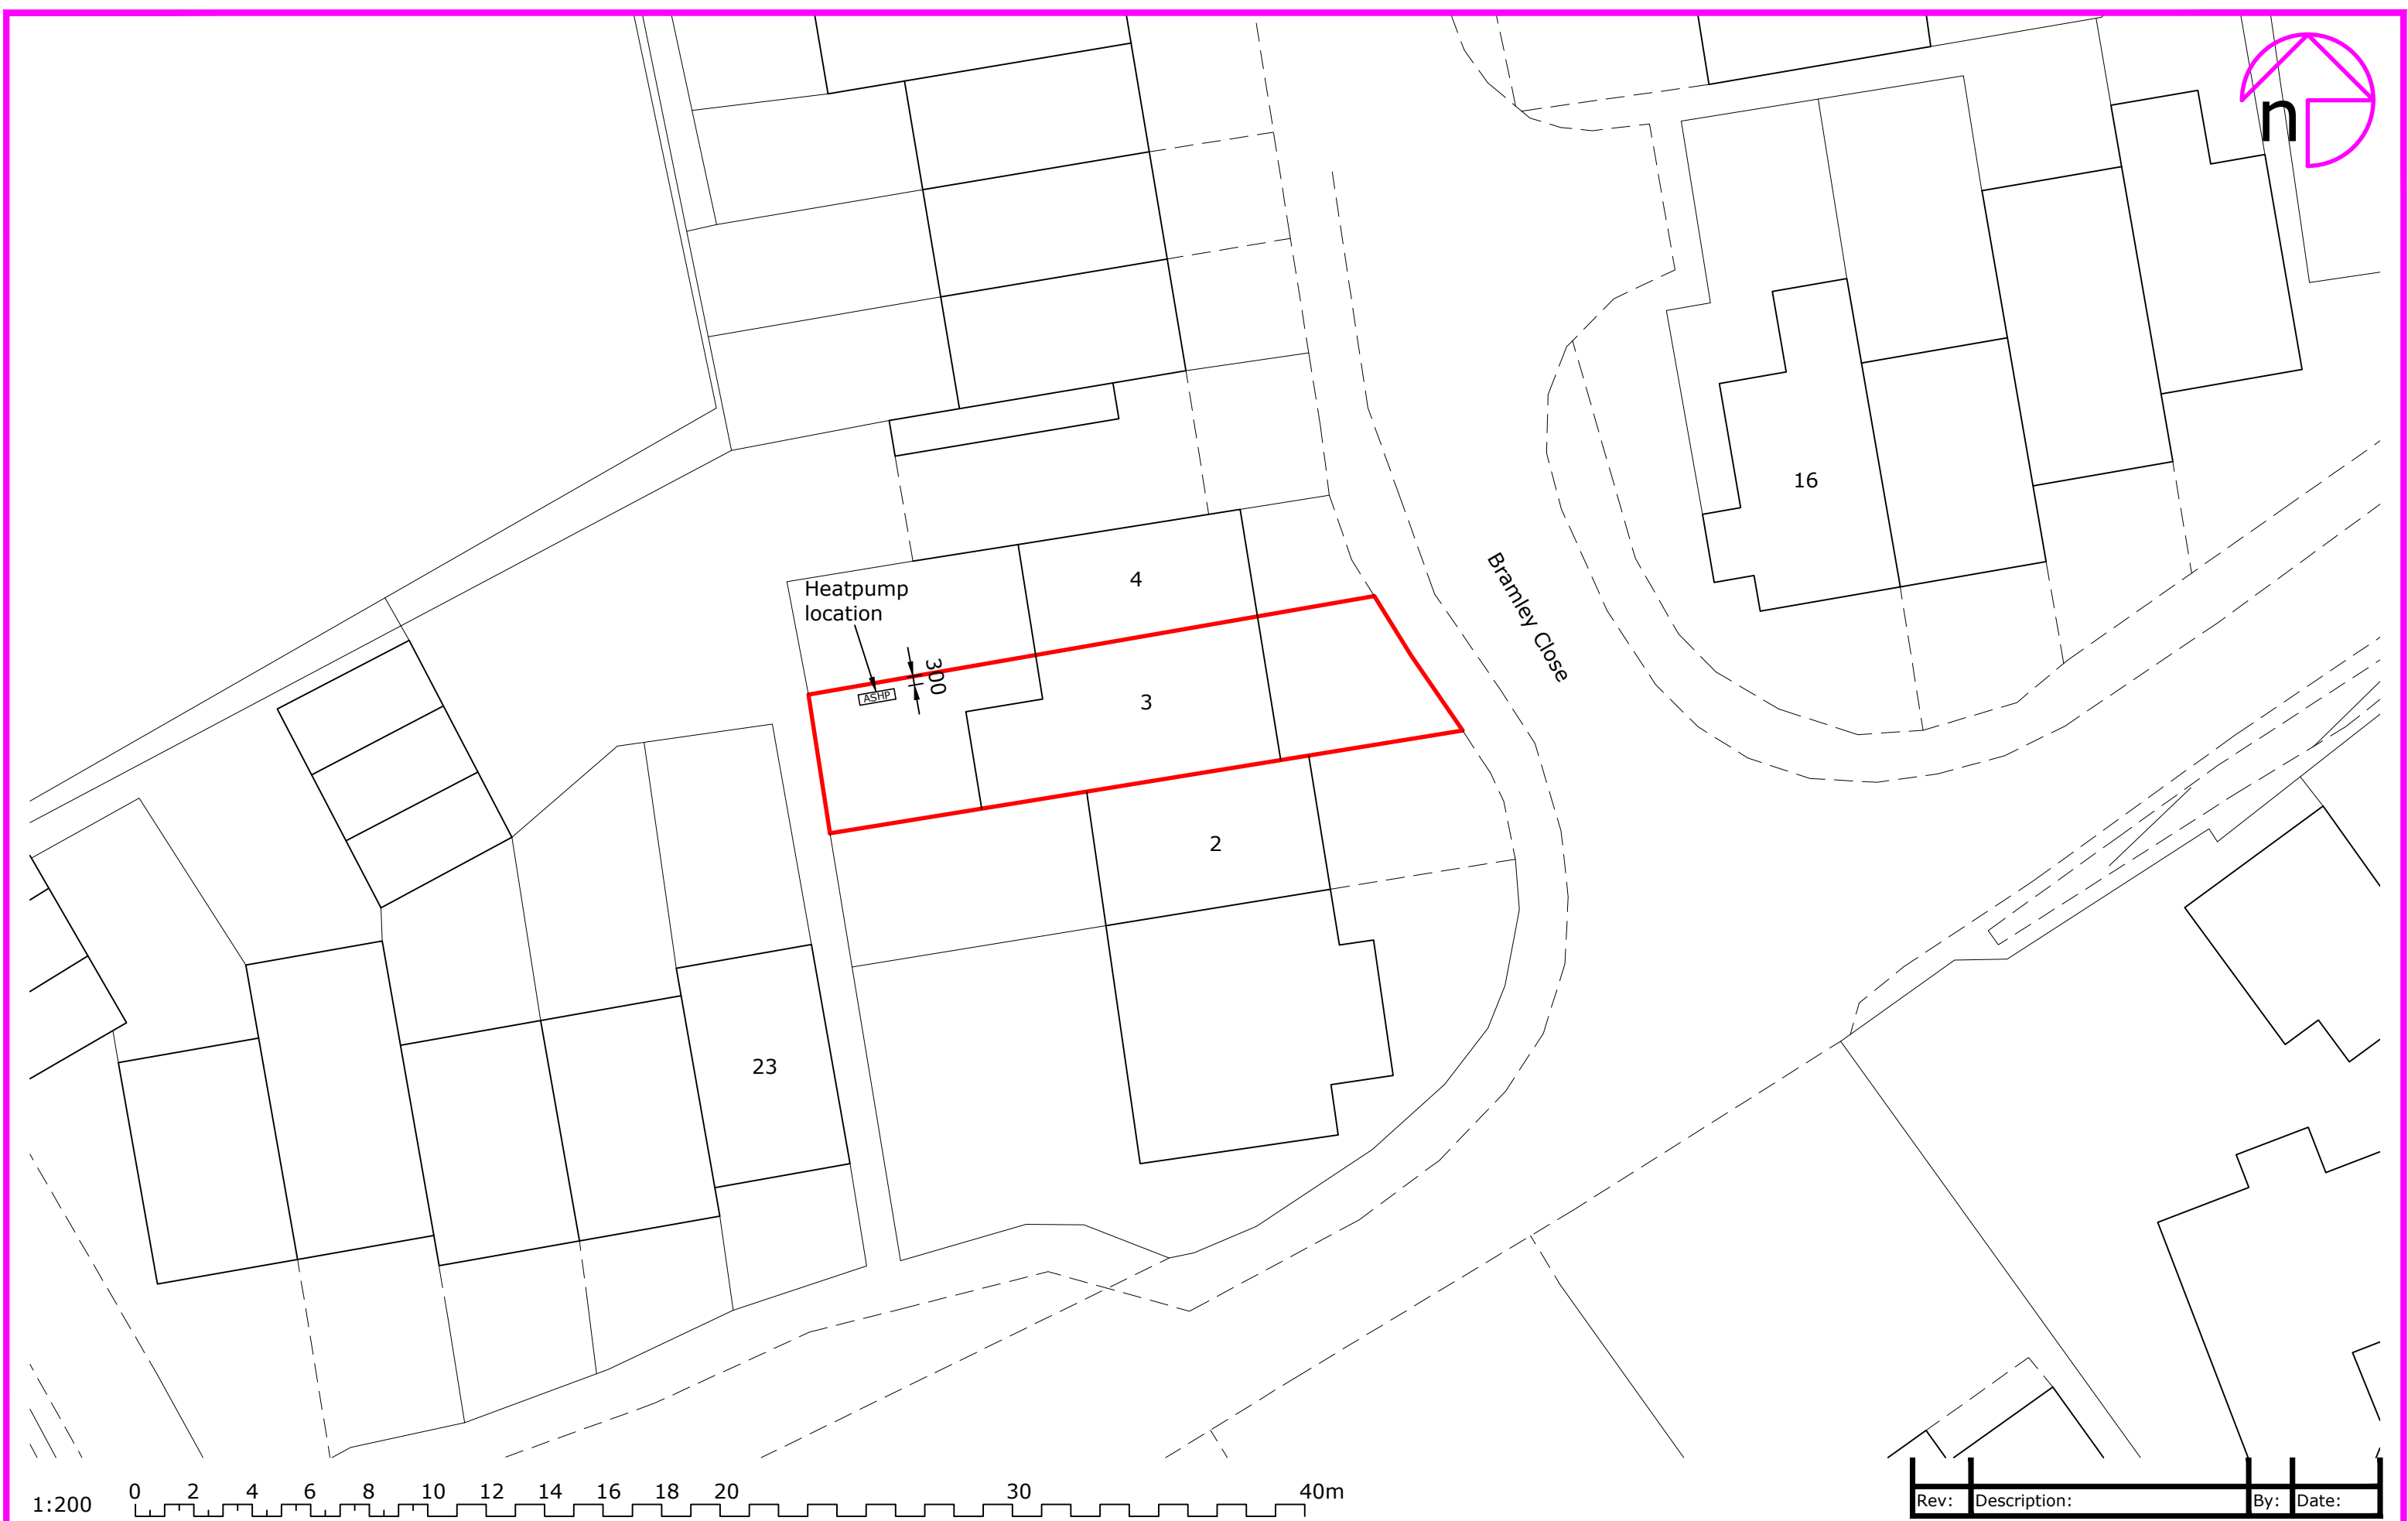

Client/Project: Adomas Skripkauskas, 3 Bramley Close, Baldock , Hertfordshire, SG7 5DF	Project status: PLANNING
	Drawing title: Site plan as proposed showing location of air source heat pump

Scale: 1:200	Paper Size: A3	Drawn: A.Kenyon	Checked: L.M.
Project ID: J-CEAD225C	Drawing No: 02	Revision:	Date: Nov 2024