


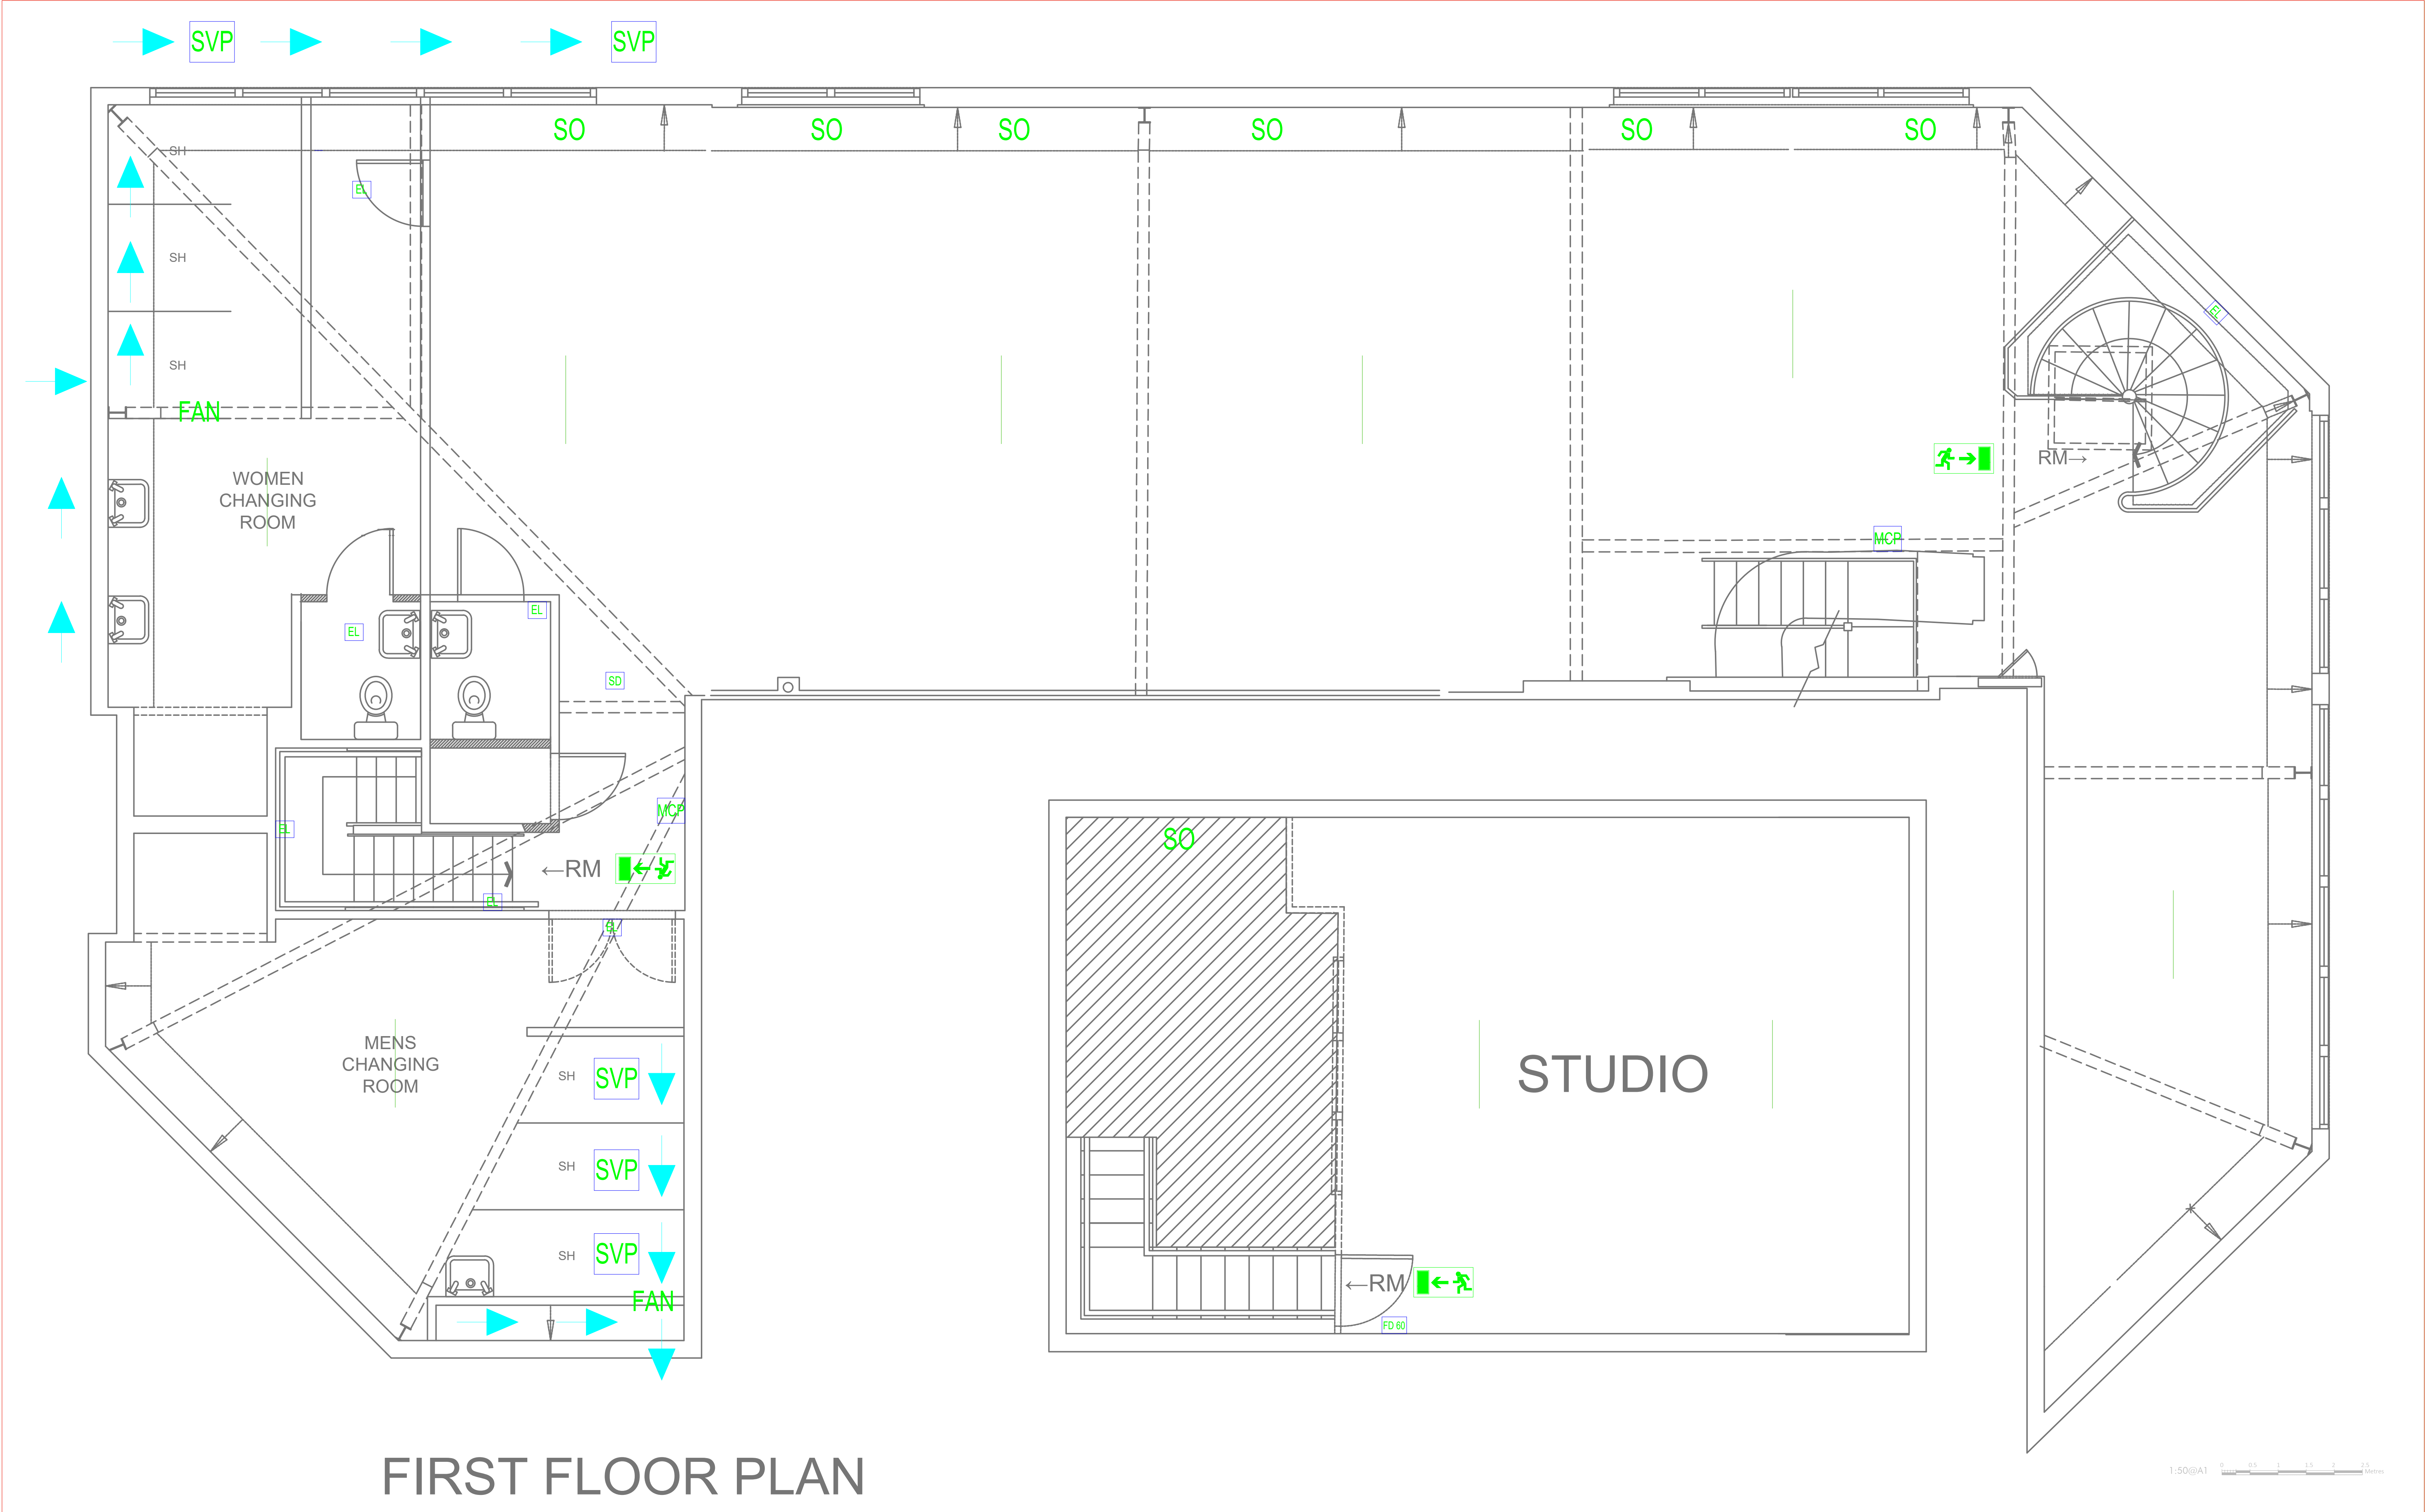

FIRST FLOOR PLAN

CONSULTANT:	DESIGNED BY:	DRAWN BY:	CHECKED BY:	PROJECT:	DRAWING TITLE: ELECTRICAL+PLUMBING FIRST FLOOR	DATE: 14-08-2025 SCALE: AS SHOWN SHEET NO: IF-1.3
-------------	--------------	-----------	-------------	----------	--	---