


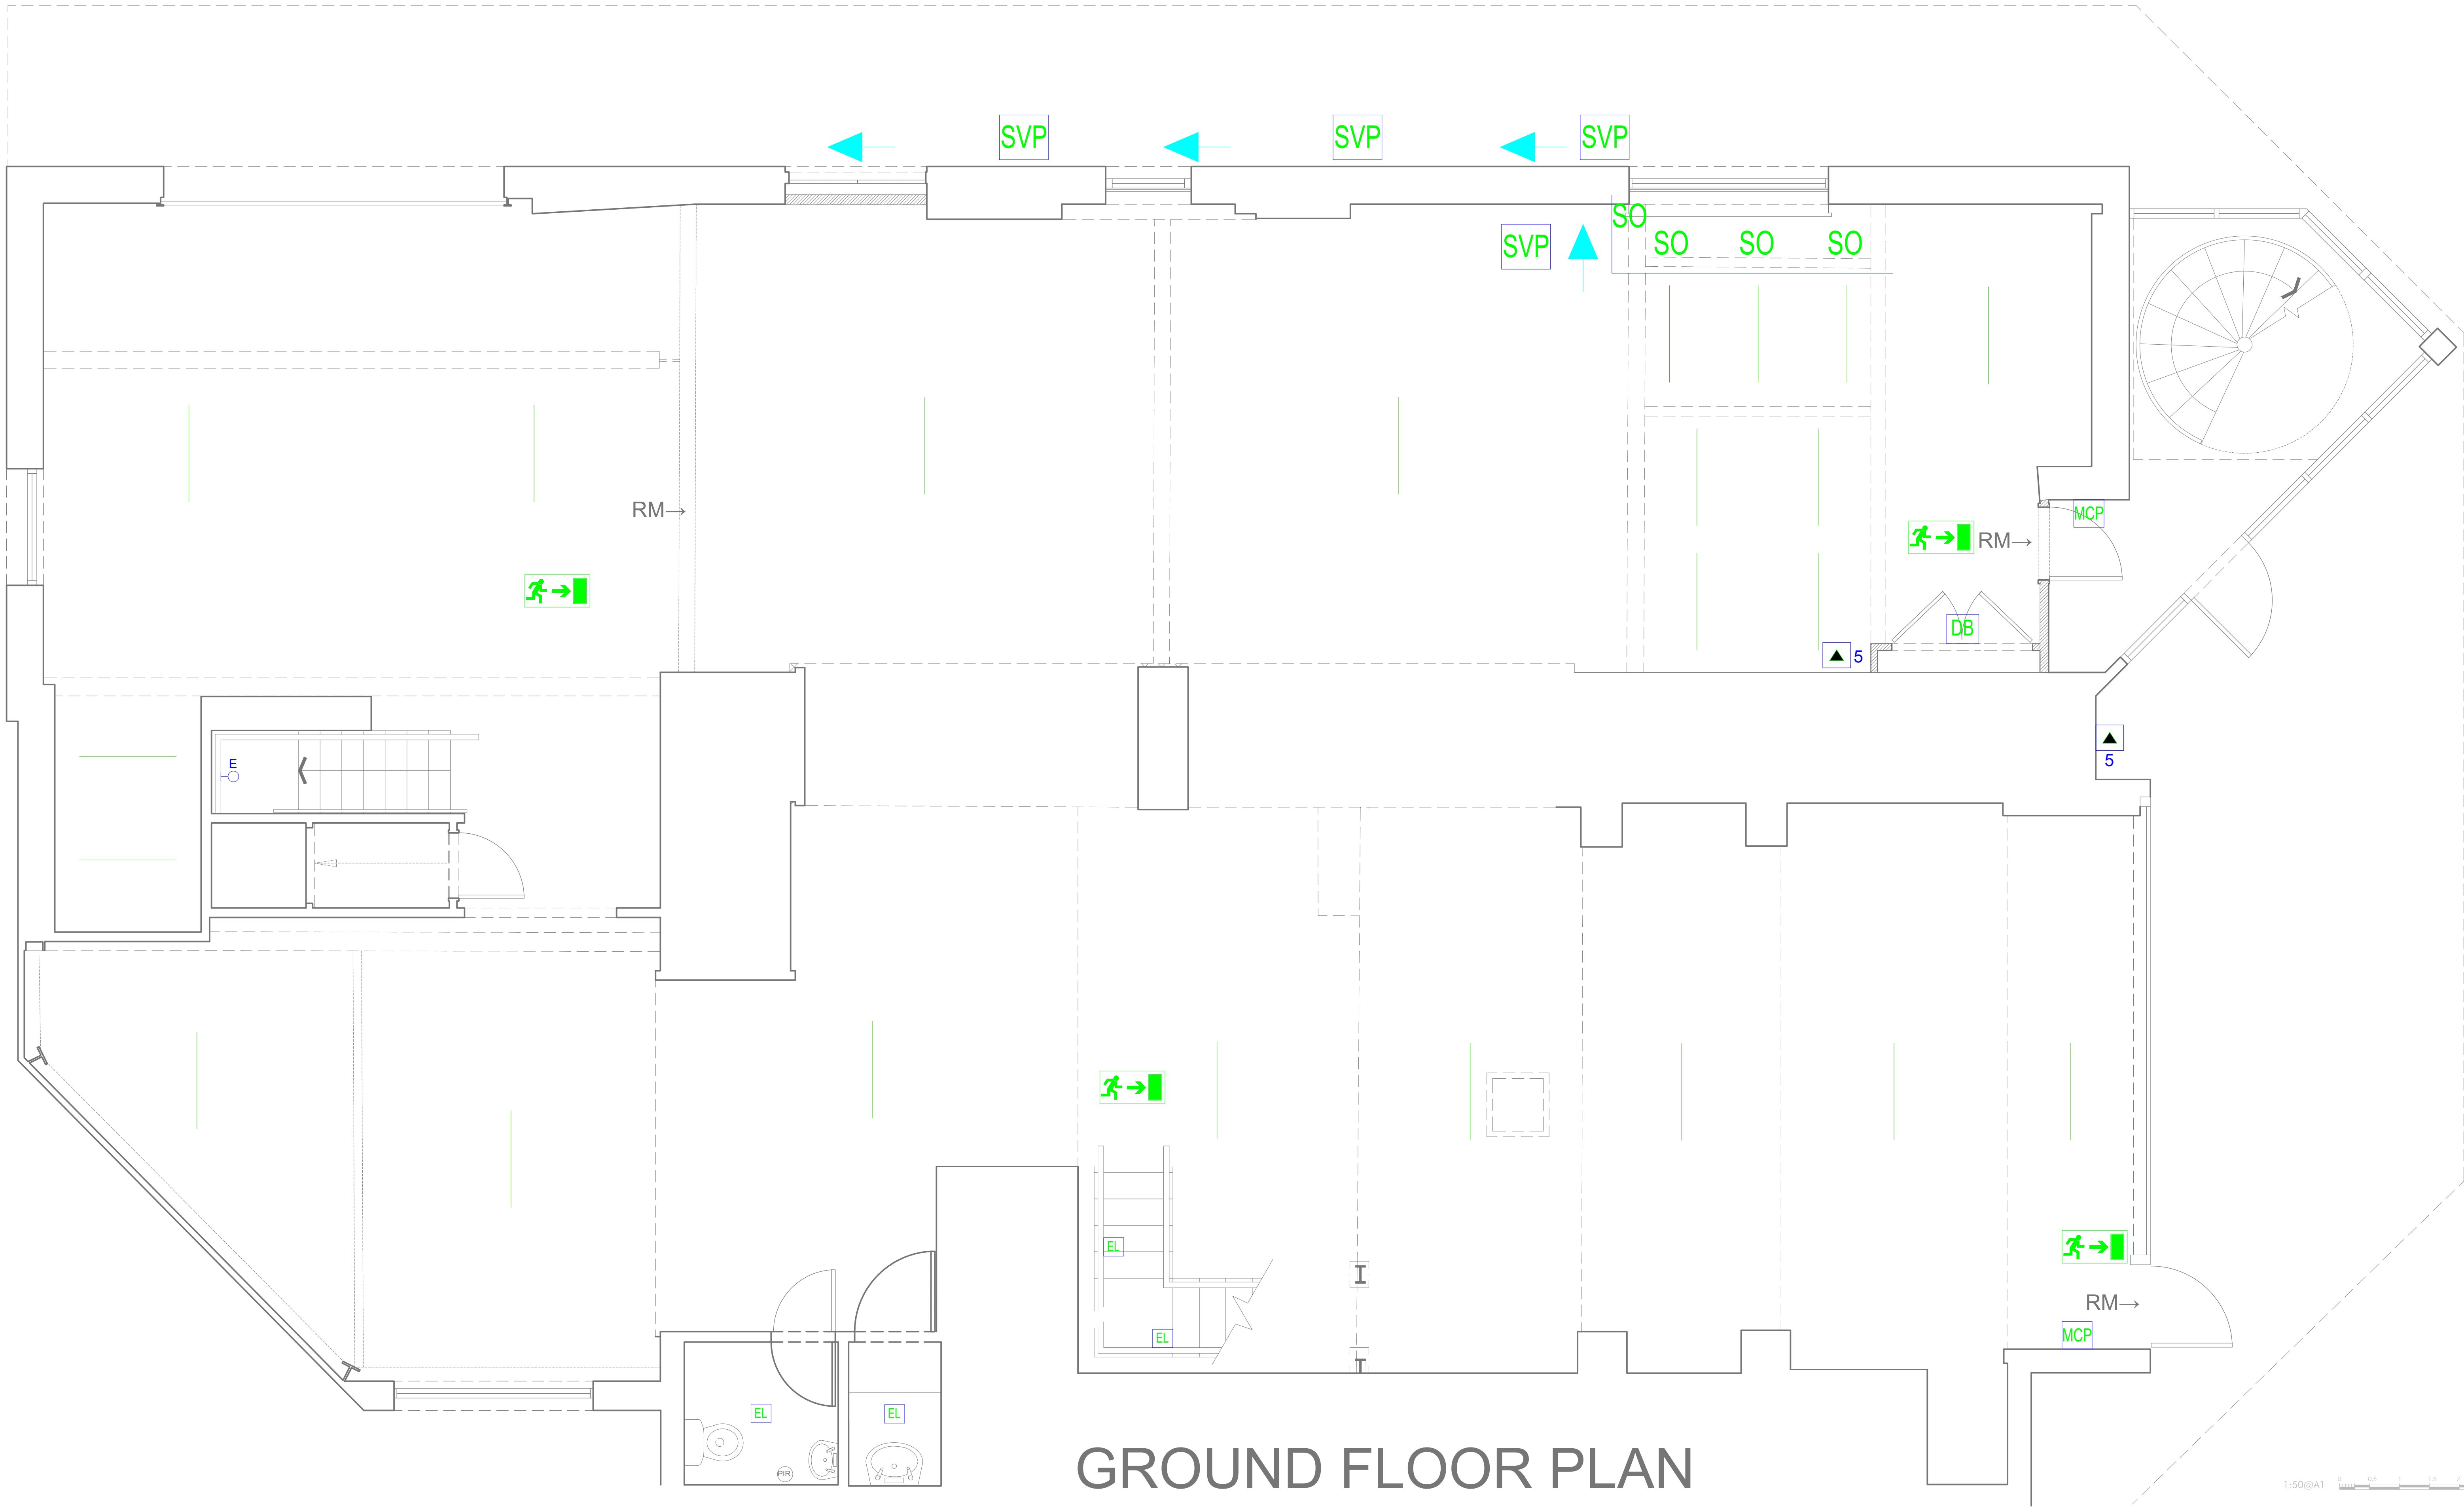

GROUND FLOOR PLAN

CONSULTANT:	DESIGNED BY:	DRAWN BY:	CHECKED BY:	PROJECT:	DRAWING TITLE: ELECTRICAL+PLUMBING GROUND FLOOR	DATE: 14-08-2025 SCALE: AS SHOWN SHEET NO: IF-1.2
-------------	--------------	-----------	-------------	----------	---	---