


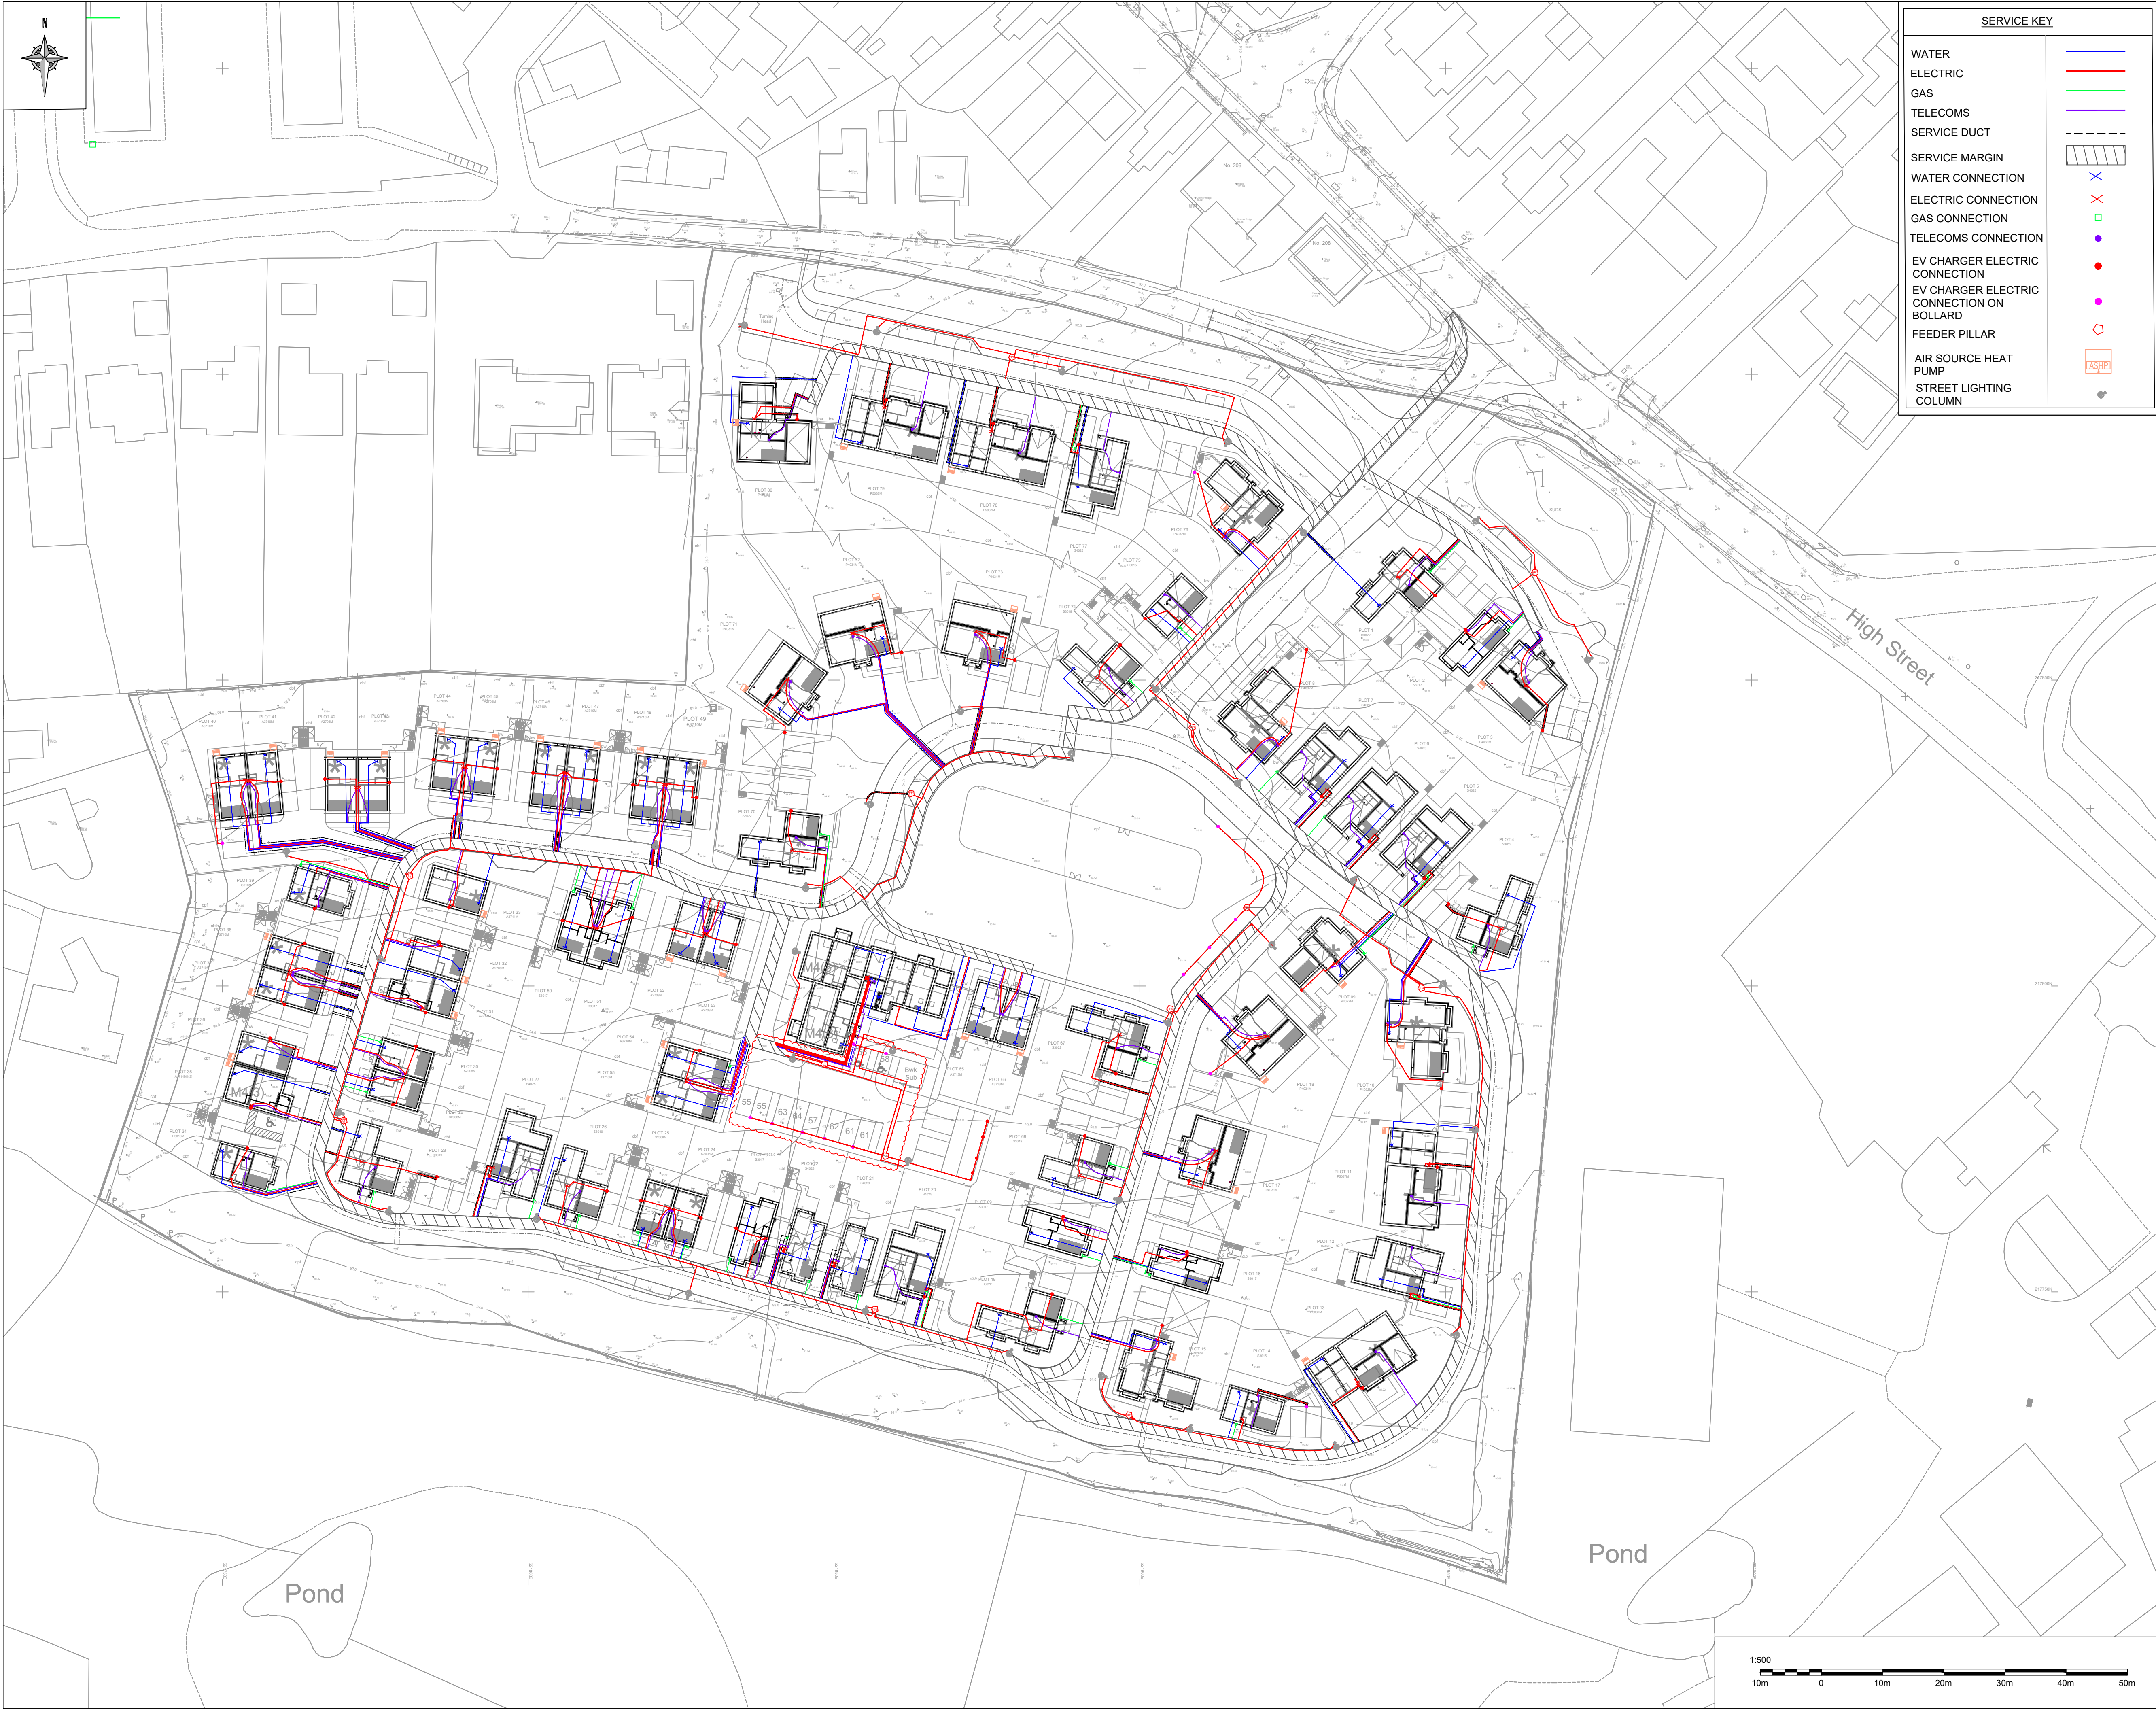

SERVICE KEY	
WATER	
ELECTRIC	
GAS	
TELECOMS	
SERVICE DUCT	
SERVICE MARGIN	
WATER CONNECTION	
ELECTRIC CONNECTION	
GAS CONNECTION	
TELECOMS CONNECTION	
EV CHARGER ELECTRIC CONNECTION	
EV CHARGER ELECTRIC CONNECTION ON BOLLARD	
FEEDER PILLAR	
AIR SOURCE HEAT PUMP	
STREET LIGHTING COLUMN	

- Copyright Barter Hill Partnership. This drawing shall not be copied in whole or part without the written permission of The Barter Hill Partnership.
- Notes
1. CONSTRUCTION ISSUE DRAWING: This drawing should be read as a CONSTRUCTION ISSUE and should be used for construction under any circumstances.
 2. The design has been carried out in accordance with all current working drawings provided by CROUDACE HOMES. Please refer to CROUDACE HOMES house type working drawings to confirm locations of all drainage outlets. Any discrepancies should be reported to the engineer immediately, prior to commencement of any works on site.
 3. Drawing subject to Section 278 approval.
 4. This drawing is based upon external information: Architectural layout - 7268 Site Plan - Revised Planning Changes - 29.09.2023 Topographical survey - Topographical Survey DWG - HS1160_01-04C - 01.11.2023

C2	EVCP BETWEEN PLOTS 55-64 UPDATED TO SUIT SERVICES DRAWING	LA	JR	28/10/24
C1	CONSTRUCTION ISSUE	LA	AR	02/09/24
T3	STREET LIGHTING ADDED/ AMENDED TO SUIT LAYOUT AND ASHP	AR	AB	24/07/24
T2	FEEDER PILLARS & EV BOLLARDS ADDED AND EV POSITIONS AMENDED	JWH	AR	07/02/24
T1	TENDER ISSUE	JCR	AB	19/01/24

Rev.	Description	By	Chk.	Date
Barter Hill Partnership Limited Greenway Business Centre Greenway Harlow Business Park Essex CM19 5QE t: 01279 430888 e: mail@barterhill.co.uk				
15 Meridian Way Meridian Business Park Norwich NR7 0TA t: 01603 300360 e: mail@barterhill.co.uk				

Client		
Project		
Coward's Lane, Codicote		
Drawing Title		
Services Layout		
Designed by	Drawn by	Checked by
AR	JWH	AB
Scale @ A1	Contact Office	Date
1:500	Norwich	January 2024
Status	Revision	Job Ref
CONSTRUCTION ISSUE	C2	9674
Drawing No		
093-BHP-XX-XX-D-C-025		
Cad file		
P:9674/Civils/BHP Drawings/093-BHP-XX-XX-D-C-025		

