




NOTE: CONTRACTOR TO CHECK DIMENSIONS ON SITE PRIOR TO COMMENCEMENT OF WORK. ALL WORK CARRIED OUT TO SATISFACTION OF LOCAL AUTHORITY AND IN STRICT ACCORDANCE WITH MANUFACTURER'S INSTRUCTIONS

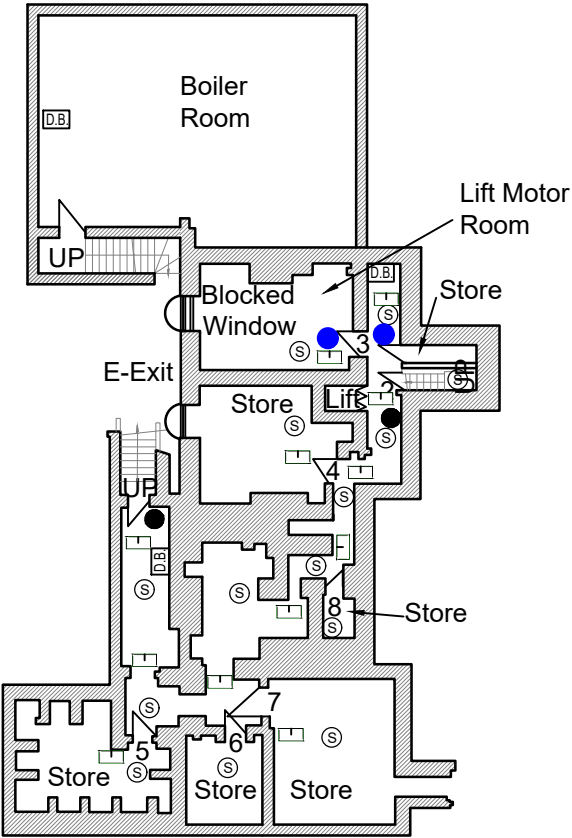

Basement

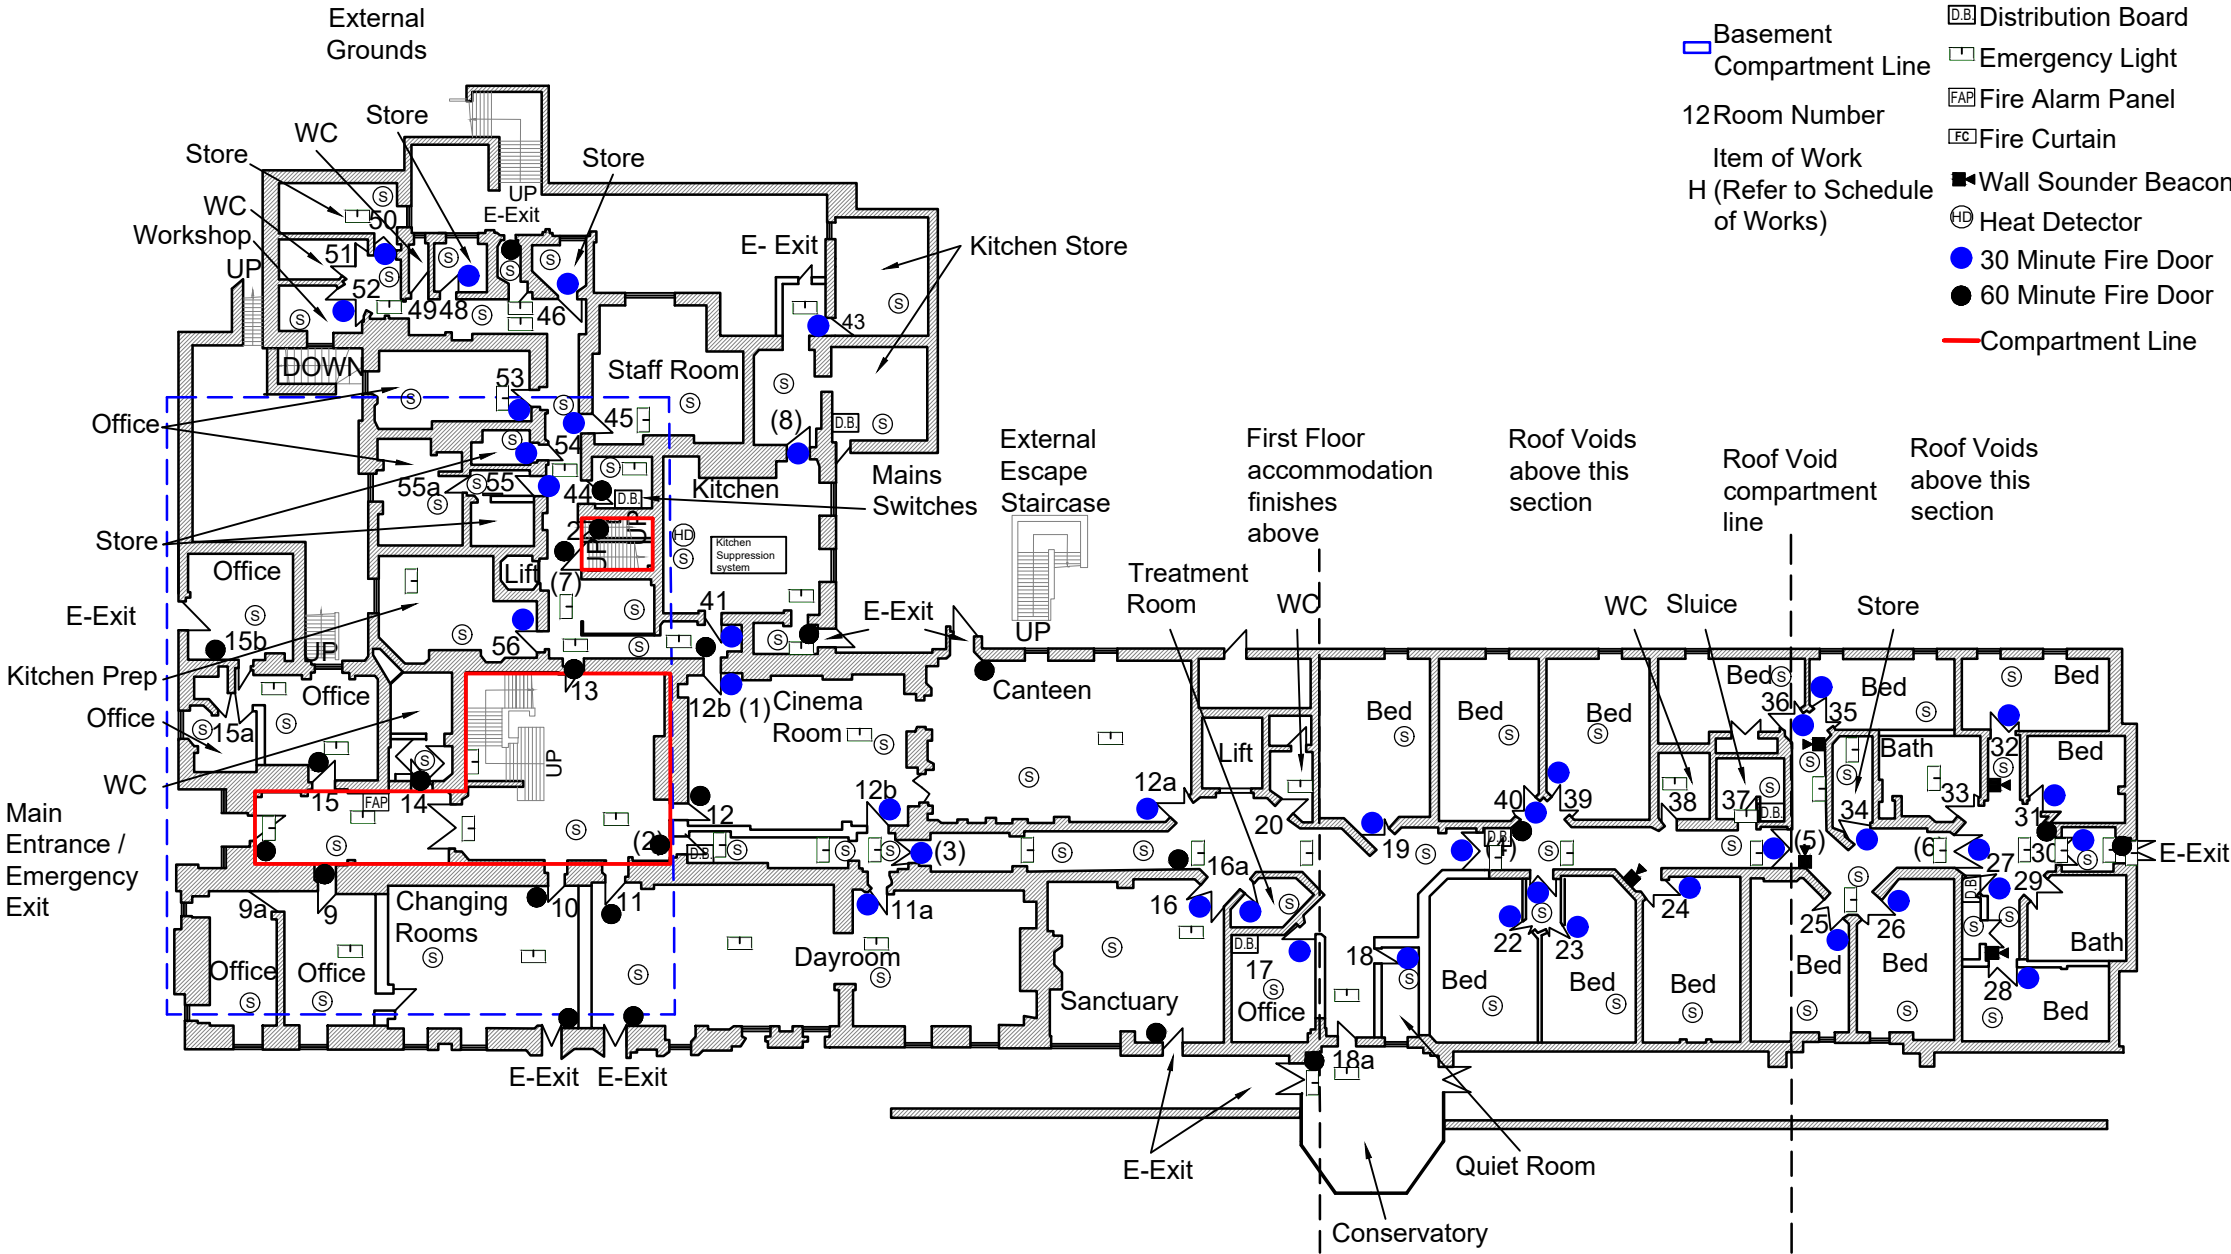

Ground Floor (Main Building)

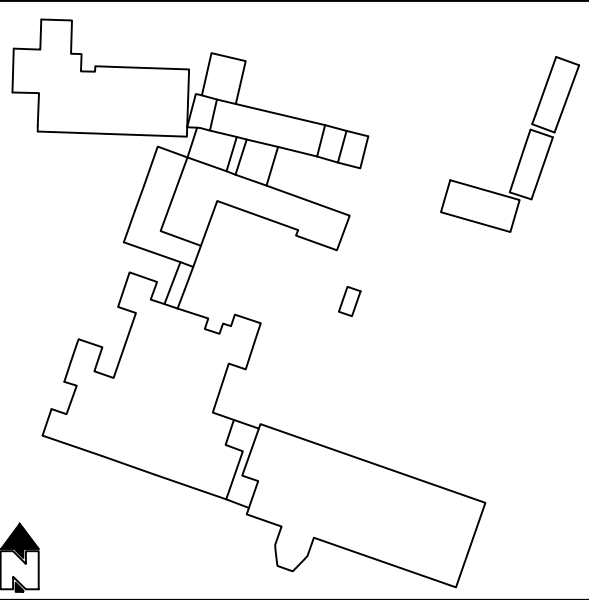

Location Plan Scale 1:200

LEGEND

- Masonry Wall
- Partition Wall
- Basement Compartment Line
- 12Room Number
- Item of Work
- H (Refer to Schedule of Works)

LEGEND

- Smoke Detector
- Manual Call Point
- Distribution Board
- Emergency Light
- Fire Alarm Panel
- Fire Curtain
- Wall Sounder Beacon
- Heat Detector
- 30 Minute Fire Door
- 60 Minute Fire Door
- Compartment Line

A	ISSUED FOR INFORMATION	LT	IB	RM	13.06.25
REV	DESCRIPTION	BY	CHK	APP	DATE
ADDRESS:					
Stagenhoe Park					
St Paul's Walden					
Hitchin					
SG4 8BZ					
25 Broom Wood Court					
Prudhoe					
Northumberland					
NE42 6RB					
Tel: 07870 215 490					
Web: www.onaek.co.uk					
Email: enquiries@onaek.co.uk					
Reg No: 6216880					
PROJECT:					
Brainkind					
Fire Safety Remedial Works					
DRAWING TITLE:					
Location of Fire Alarm System Components, Fire Doors and					
Protected 60 minutes Compartments					
Basement and Ground Floor (Main Building)					
SCALE	A3	DRAWN	DATE	CHECKED	DATE
	1:500	LT	JAN 25	IB	JAN 25
PROJECT No.		OFFICE		DRAWING No.	
		N/A	BS	05	
APPROVAL		INFORMATION		TENDER	
				CONTRACT	
				CONSTRUCTION	

