


**OFFLEY CHASE
GROUND FLOOR**

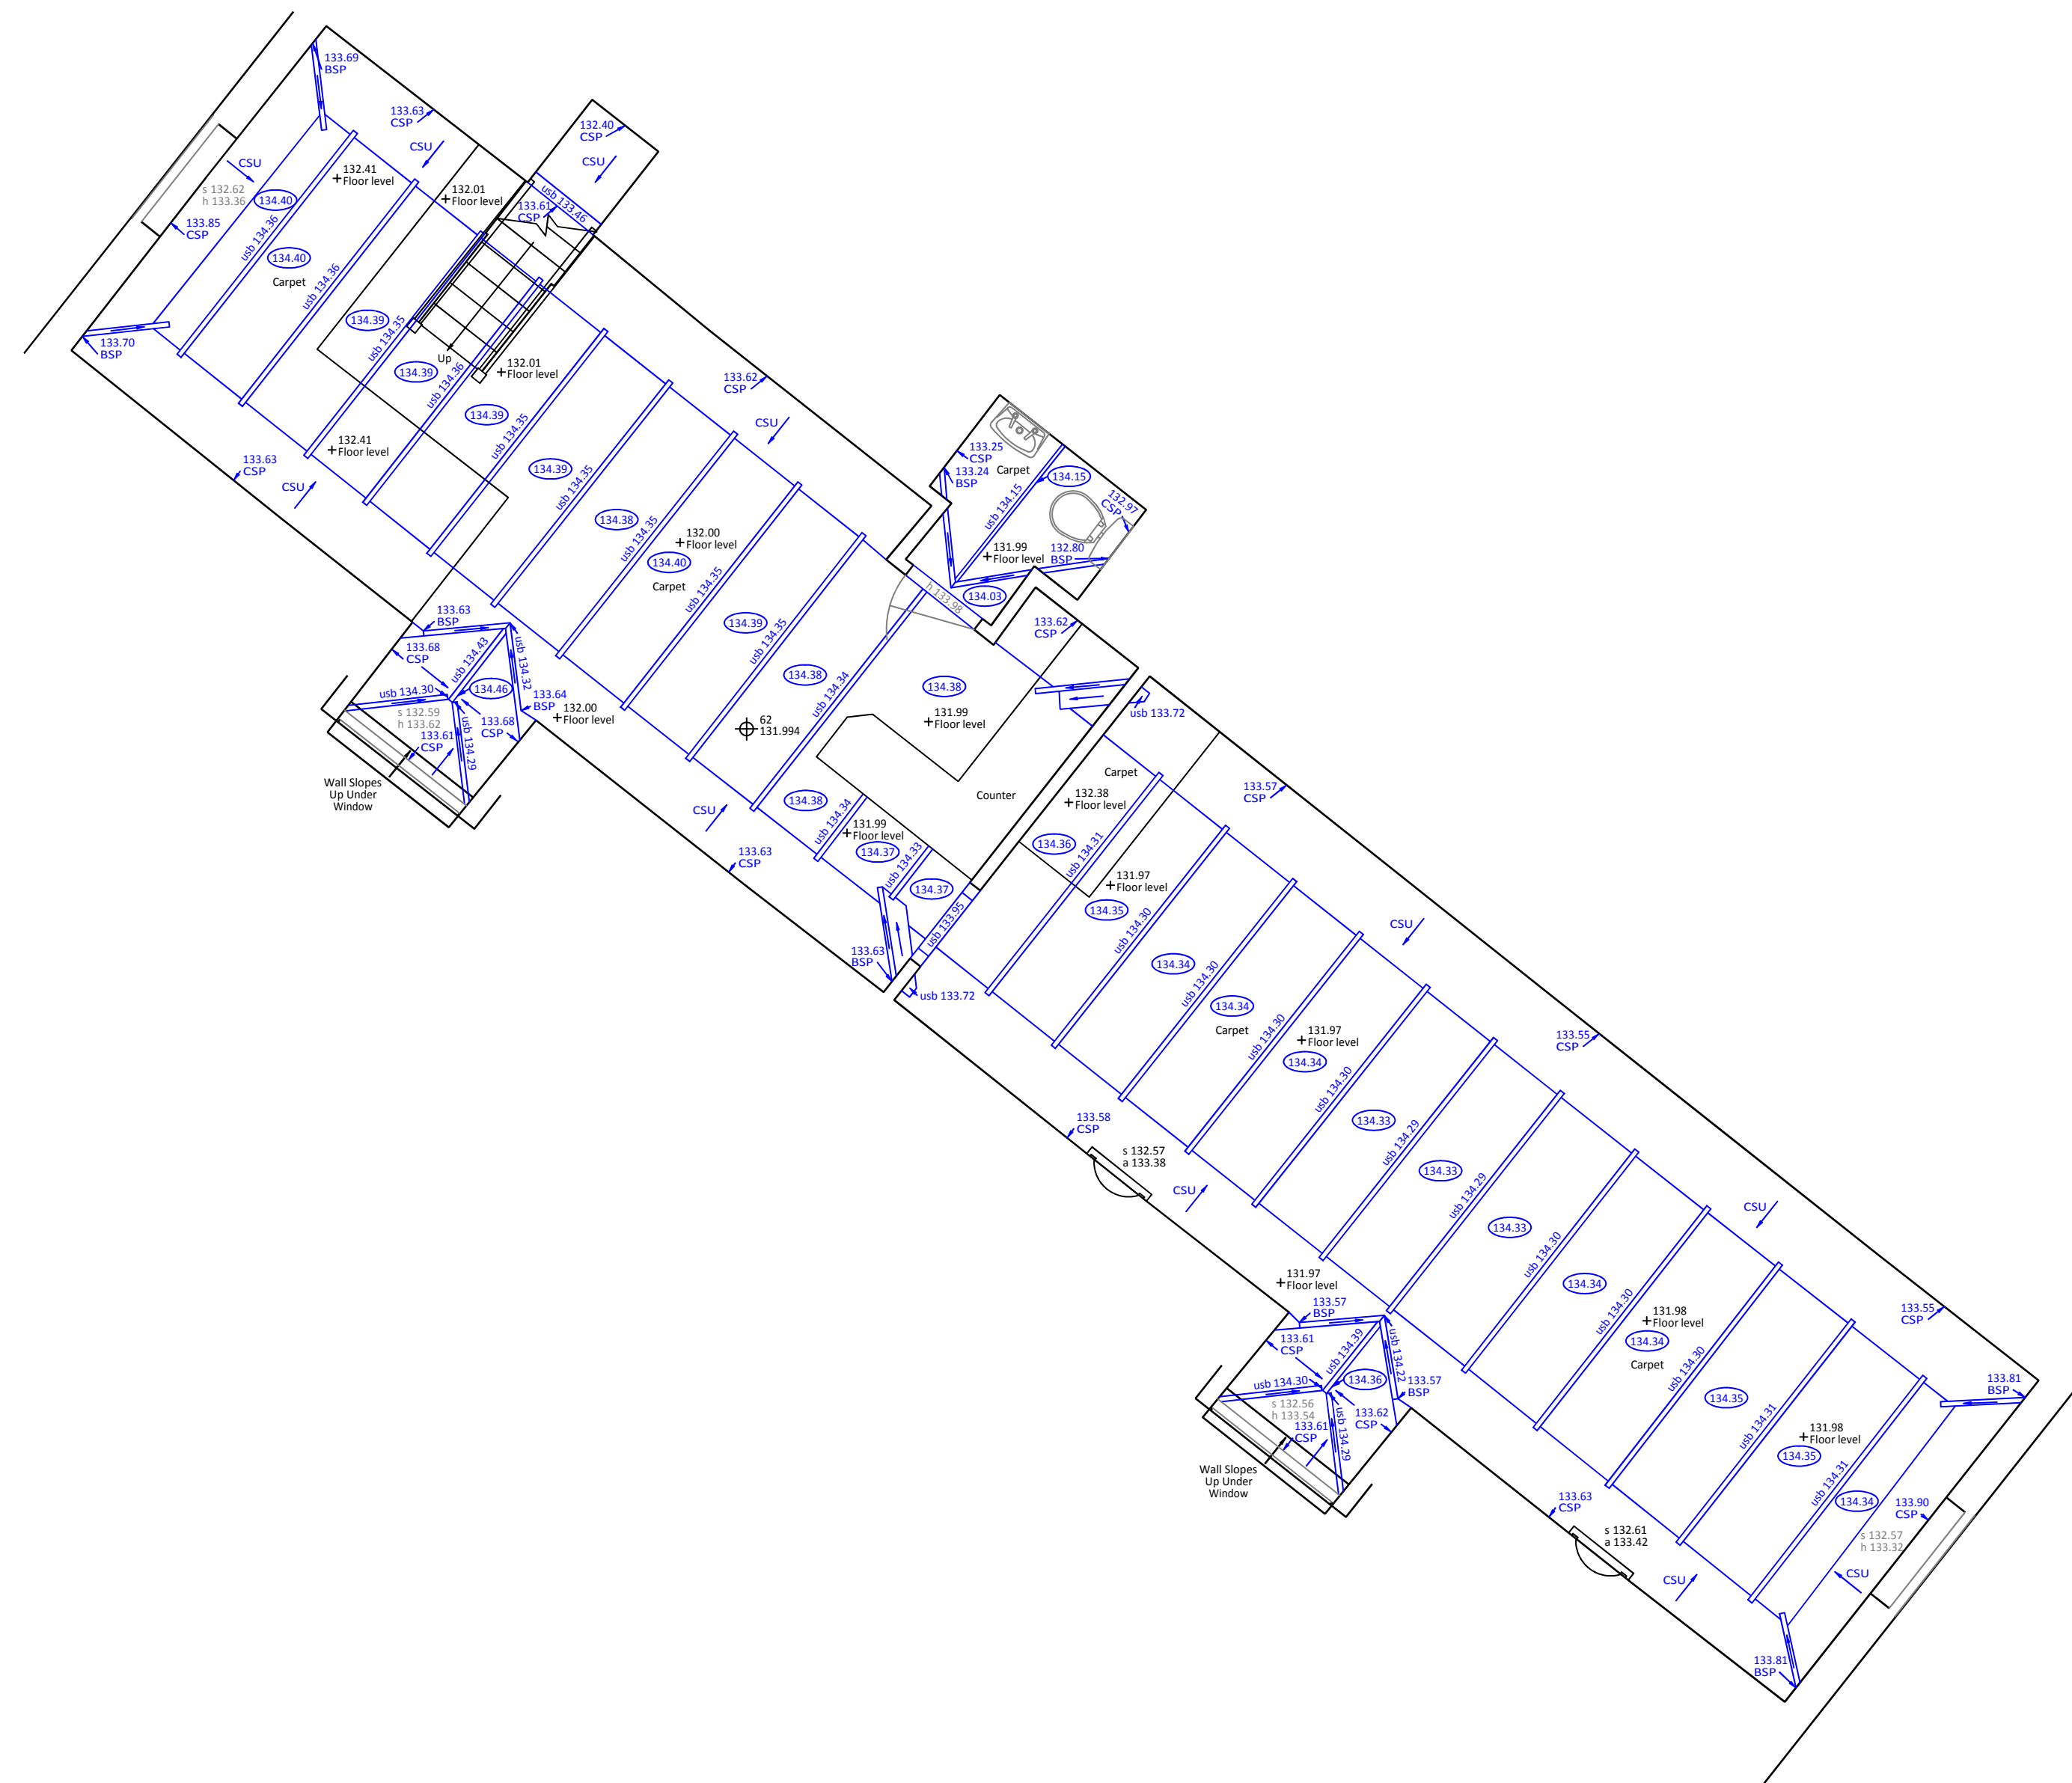


OFFLEY CHASE FIRST FLOOR



+ Fixing Point A (STA 1)

+ Fixing Point B (STA 2)

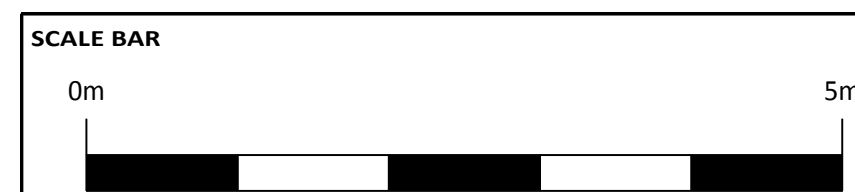

NOTES

- 1 LEVELS ARE RELATED TO ORDNANCE SURVEY BY GPS OBSERVATION.
- 2 SURVEY HAS BEEN CARRIED OUT TO AN ACCURACY COMMENSURATE WITH A 1:50 SCALE DRAWING.

ABBREVIATION LIST

AC	AIR-CONDITIONING VENTS OR EQUIPMENT
BSJ	BEAM SPRING LEVEL
BSL	BEAM SLOPES UP
CSP	CeILING SPRING LEVEL
CSU	CeILING SLOPES UP
DO	DOUBLE FLUSH
ELS	EMERGENCY LIGHT SWITCH
EP	ELECTRIC PUMP
ESM	ELECTRIC SWITCH MACHINE
FA	FLOOR LEVEL
FL	FLOOR LEVEL
FS	FLOOR/ELECTRIC SWITCH
JR	JUNCTION BOX
L	LIGHT
LCB	LIFT CALL BUTTON
LS	LIGHT SWITCH
SP	SINGLE FLUSH
TOB	TOP OF BUILDING
TOW	TOP OF WALL
	WALL LIGHT
h 1.00	STILL LEVEL
h 1.00	HEAD LEVEL
u/s 1.00	LEVEL OF UNDERSIDE OF ARCH
u/s 1.00	LEVEL OF UNDERSIDE OF BEAM
u/s 1.00	LEVEL OF UNDERSIDE OF DUCTING
u/s 1.00	LEVEL OF UNDERSIDE OF PIPE
u/s 1.00	CEILING LEVEL
CS-30	SOLID SPRING LEVEL
CS-30	FALSE CEILING

NO.	DATE	DETAILS

REVISIONS



el: 01494 718453
ex: 01494 717576
mail: admin.office@kndsveys.com

74 WATCHET LANE
HOLMER GREEN
HIGH WYCOMBE
BUCKINGHAMSHIRE
HP15 6UG

ENT

OFFLEY CHASE ESTATES LTD
HOUGHTON HALL
THE GREEN
HOUGHTON REGIS
DUNSTABLE
BEDFORDSHIRE
LU5 5DY

B TITLE

OFFLEY CHASE
CHALK HILL
LILLEY
LUTON
LU2 8NJ

DRAWING TITLE

FLOOR PLANS

AWING No. B1219 - F	DRAWN BY NJG	DATE 11 FEB 2019
REVIEWED BY NJG		SCALE 1:50 A/D Sheet