


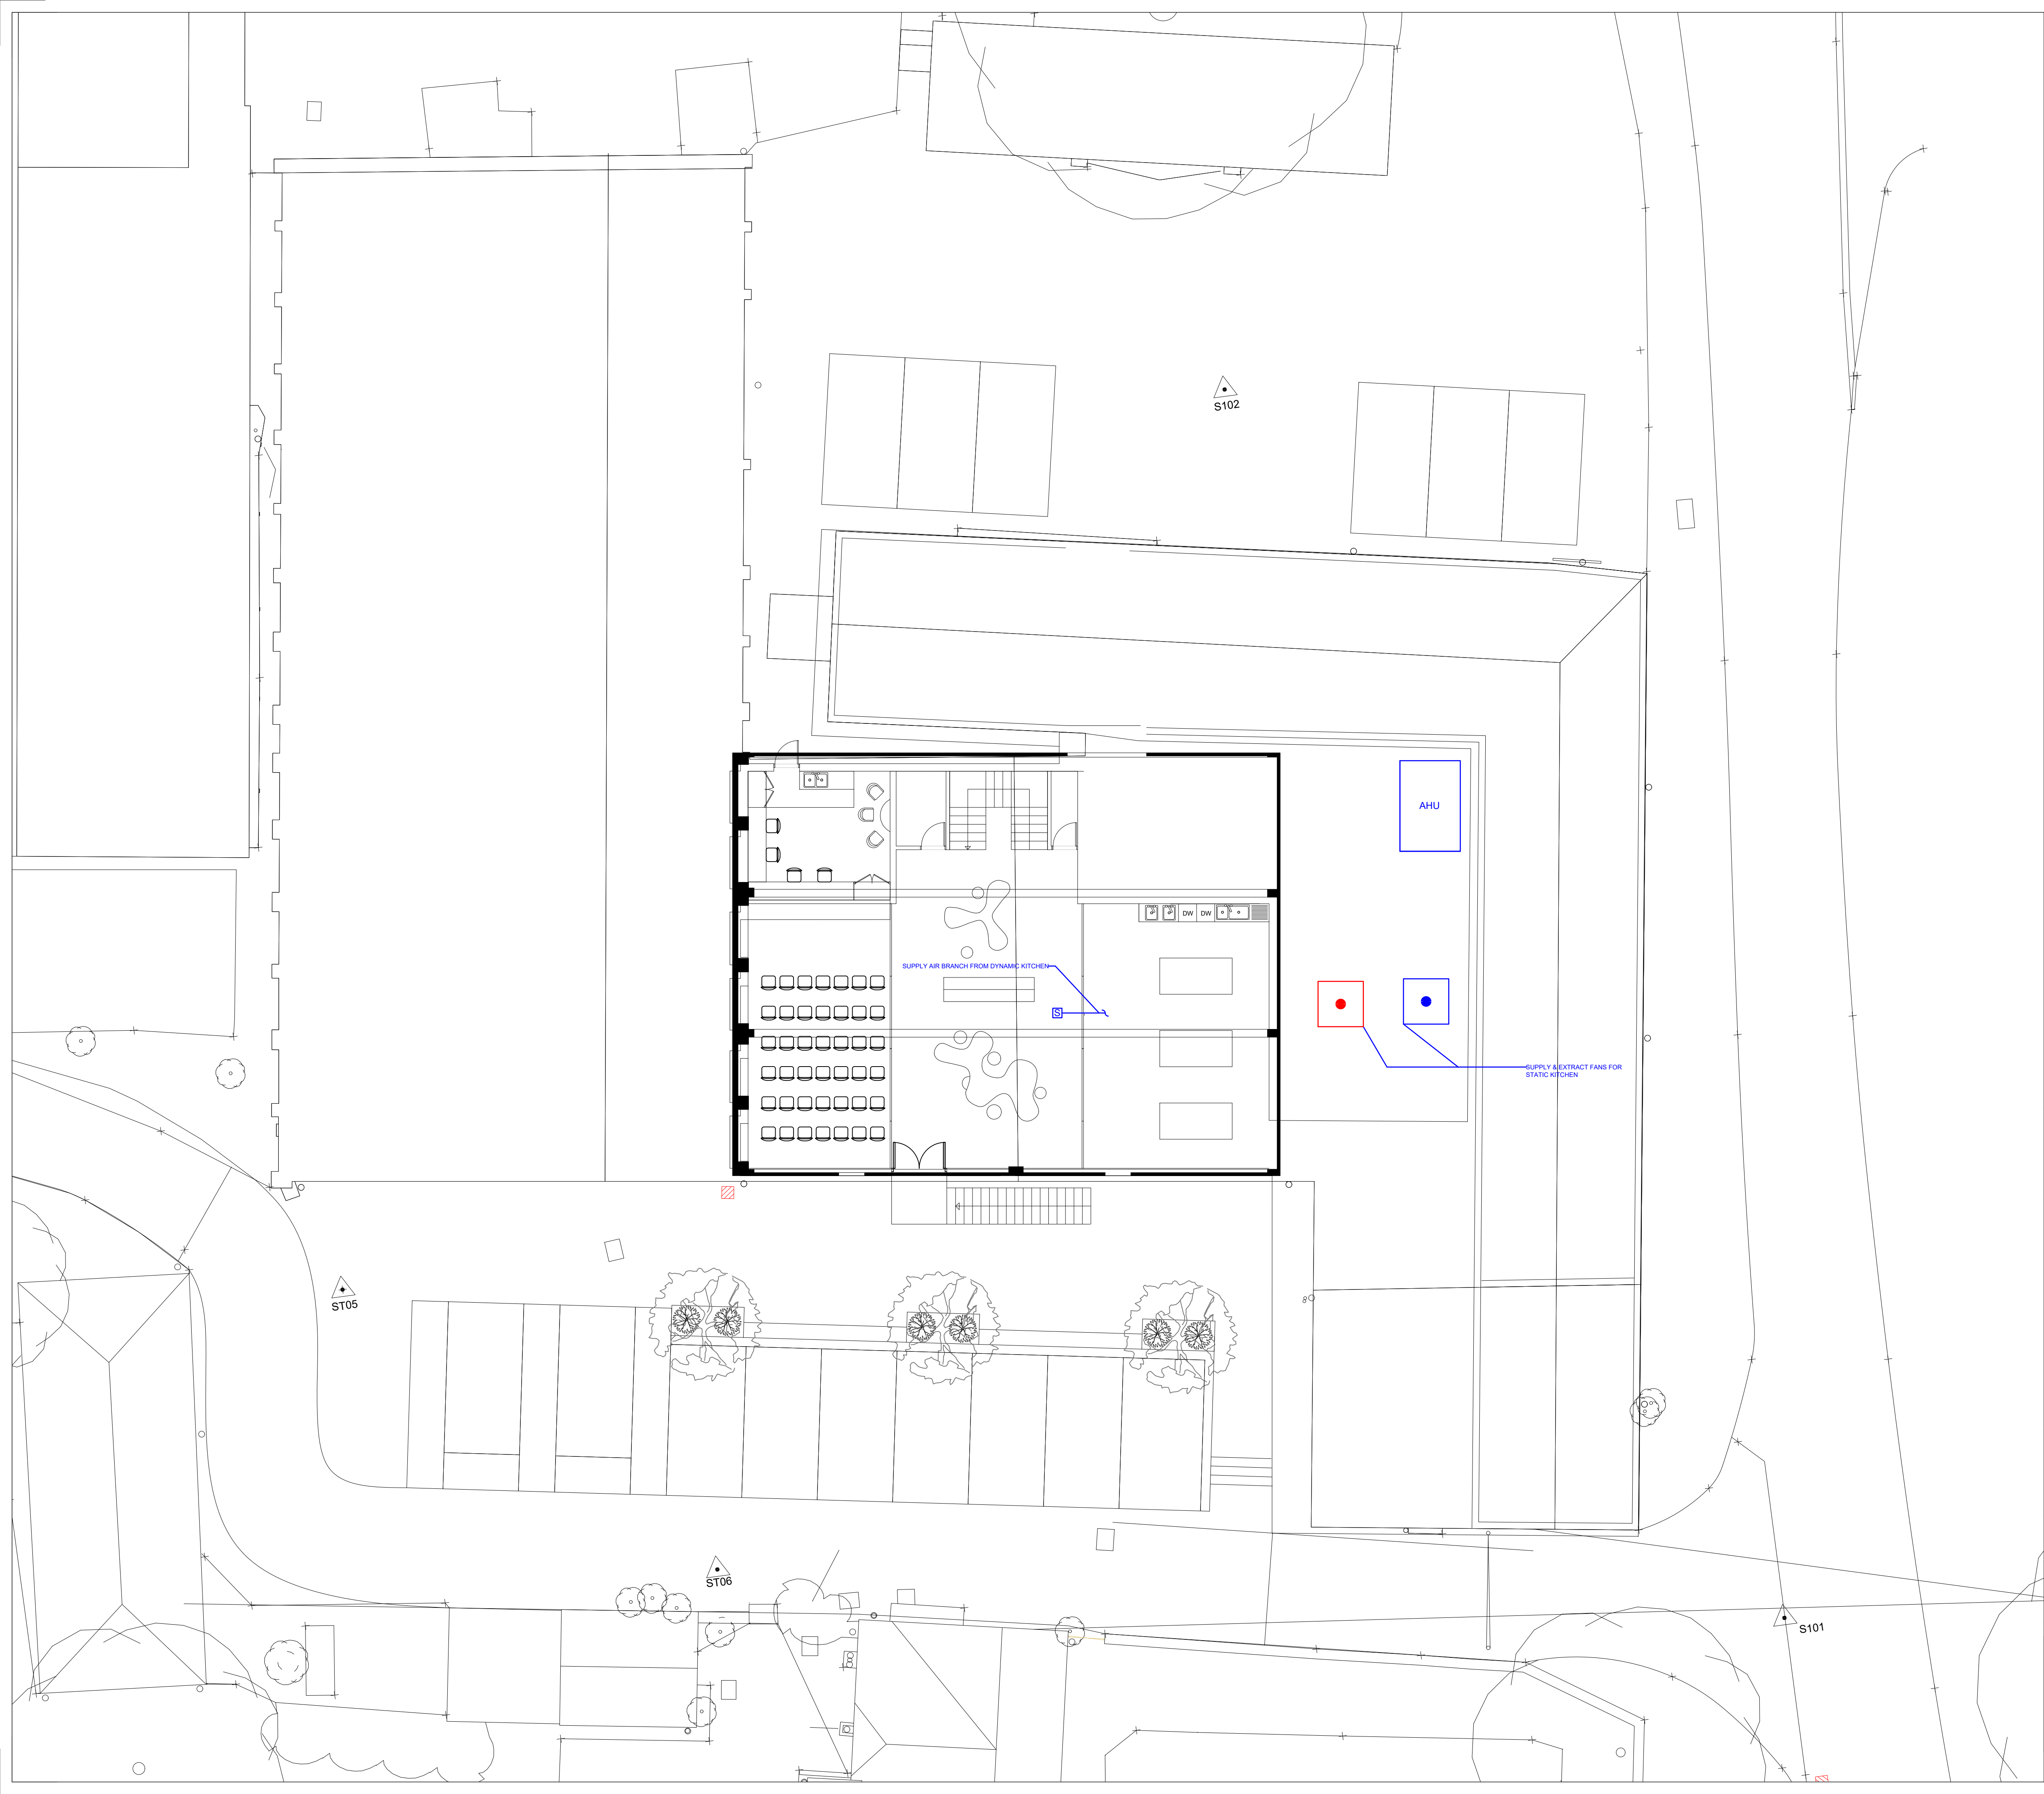

LEGEND KEY :

REV	DATE	DRAWN BY	CHECKED BY	COMMENTS
-	-	-	-	-

Project:
GROUNDSCHOOL, IRON FARM

Drawing Title:
DRAFT VENTILATION LAYOUT MEZZANINE

Client:
MICHEAL COLLINS ARCHITECTS LLP

Stage:
FOR COMMENT

Dwg. No. LSL-E0864-001	Date: 04.04.25	Rev. V1	Scale: 1:100 @A1
Purpose of Issue: FIRST ISSUE	Checked by: DG	Drawn by: KHC	

Contact us at info@luths-services.com / 0333210840 / www.luths-services.com



LUTHS
SERVICES

BUILDING SERVICE ENGINEERS | ENERGY ASSESSORS | LOW CARBON CONSULTANTS