

Legend

External Wall Mounted Luminaire
Thorn Lighting - Axyl Echo S 4L 930
WB HF BK
110mm x 110mm x 110mm (H x W x D)
7.7W, 378lm, 49lm/W, 3000K IP65 LED

Lighting Control

Lighting to be switched on and off by
localised photocell, and switched off by
timer switch at distribution board at
night time.

Ruane Construction Design And
Consultancy Ltd

International House
6 Canterbury Crescent
London
SW9 7QD



General Notes:

- 1. This drawing should be reviewed alongside all other relevant design information.
- 3. The drawing contains information from more than one source and must be read in conjunction with all relevant specifications.
- 4. Any drafting errors and differences between other drawings and specifications shall be brought to the attention of RCDC.

CDM Regulations:

In addition to any information included in this drawing, refer also to the project CDM Risk Register for information on residual risks.



Drawing Specific Notes:

- 1.This drawing must be read in conjunction with the M&E services specifications, contract drawings, and distribution board schedules.
- 2.Do not scale from this drawing; all dimensions are to be verified on site.
- 3.The electrical installation shall comply fully with the IET Wiring Regulations, BS 7671:2018 (18th Edition, with amendments).

Elevation A



Elevation B

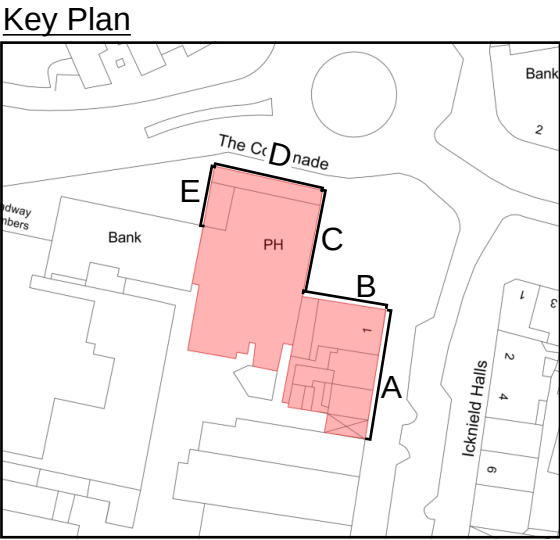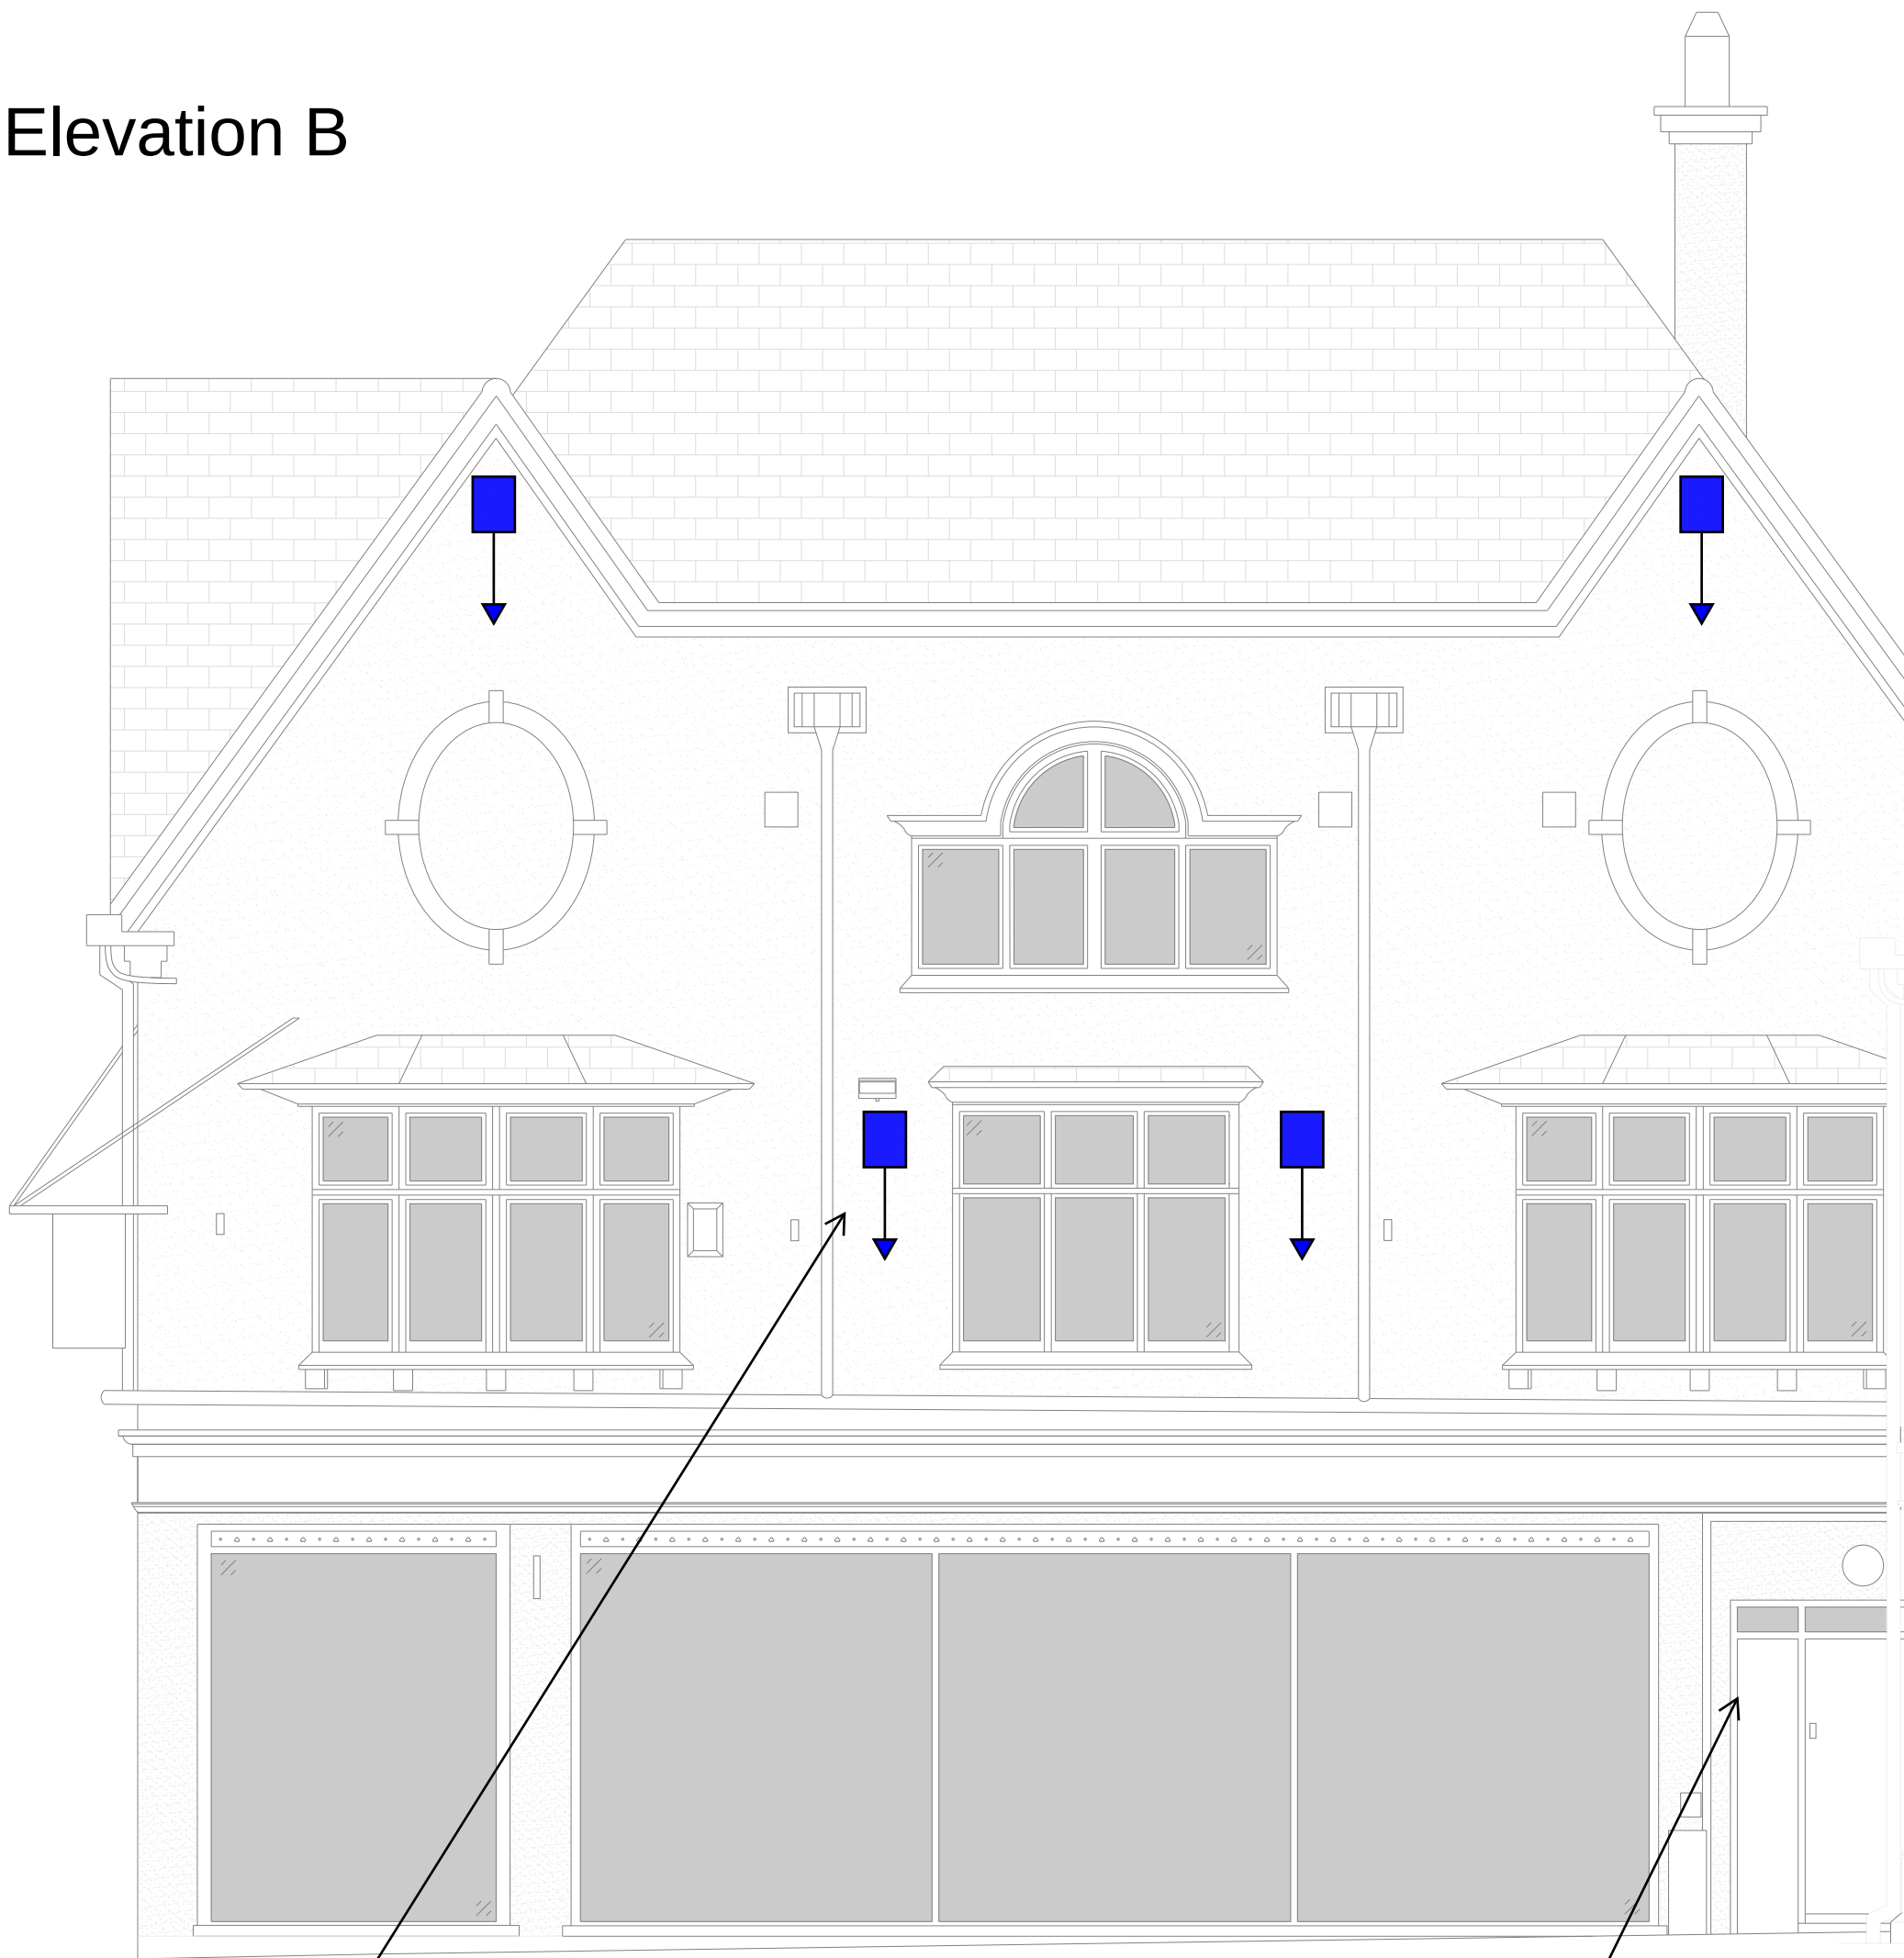

T02	Stage 3 Issue	KA	SM	VR	20.07.26
T01	Stage 3 Issue	KA	SM	VR	02.06.26
Rev	Revision Purpose	Drwn	Chkd	Vrfd	Date

Revision History

Project Name:

Collonade and Eastcheap Lighting

Client:

Letchworth Garden City Heritage Foundation

Architect:

-

Services:

Electrical

Drawing Title:

External Lighting Layout - (Sheet 1 of 2)

Stage 3 Issue

Project No: 26014	Drawing Status: S4	Scale@A1: 1:100
Design: KA	Checked: SM	Verified: VR

Drawing Reference: CEL-RCDC-03-GF-DR-E-6301	Rev: T02
--	-------------

Localised photocell

Distribution board in cupboard on first
floor feeding external lighting on elevation
A & B. Timer switch to be provided at
distribution board.

