


This drawing is based upon survey drawings prepared by
SGD Site Engineering & Surveys Ltd



NORLYS Bornholm in white.
Ref: 541W 11.3w LED IP65
bulkhead light.

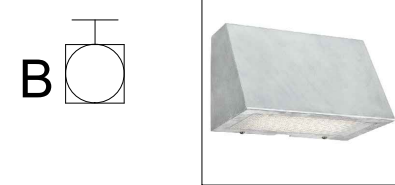


NORLYS Ski in galvanized finish.
Ref: 1392GA 5.2w LED IP44

No. 160

150mm Ø Mechanical extract
from the kitchen taken at high
level to air brick
KITCHEN AREA
20.12m²

200 litre Water Butt

100mm Ø Mechanical extract
from the WC taken at high level to
air brick

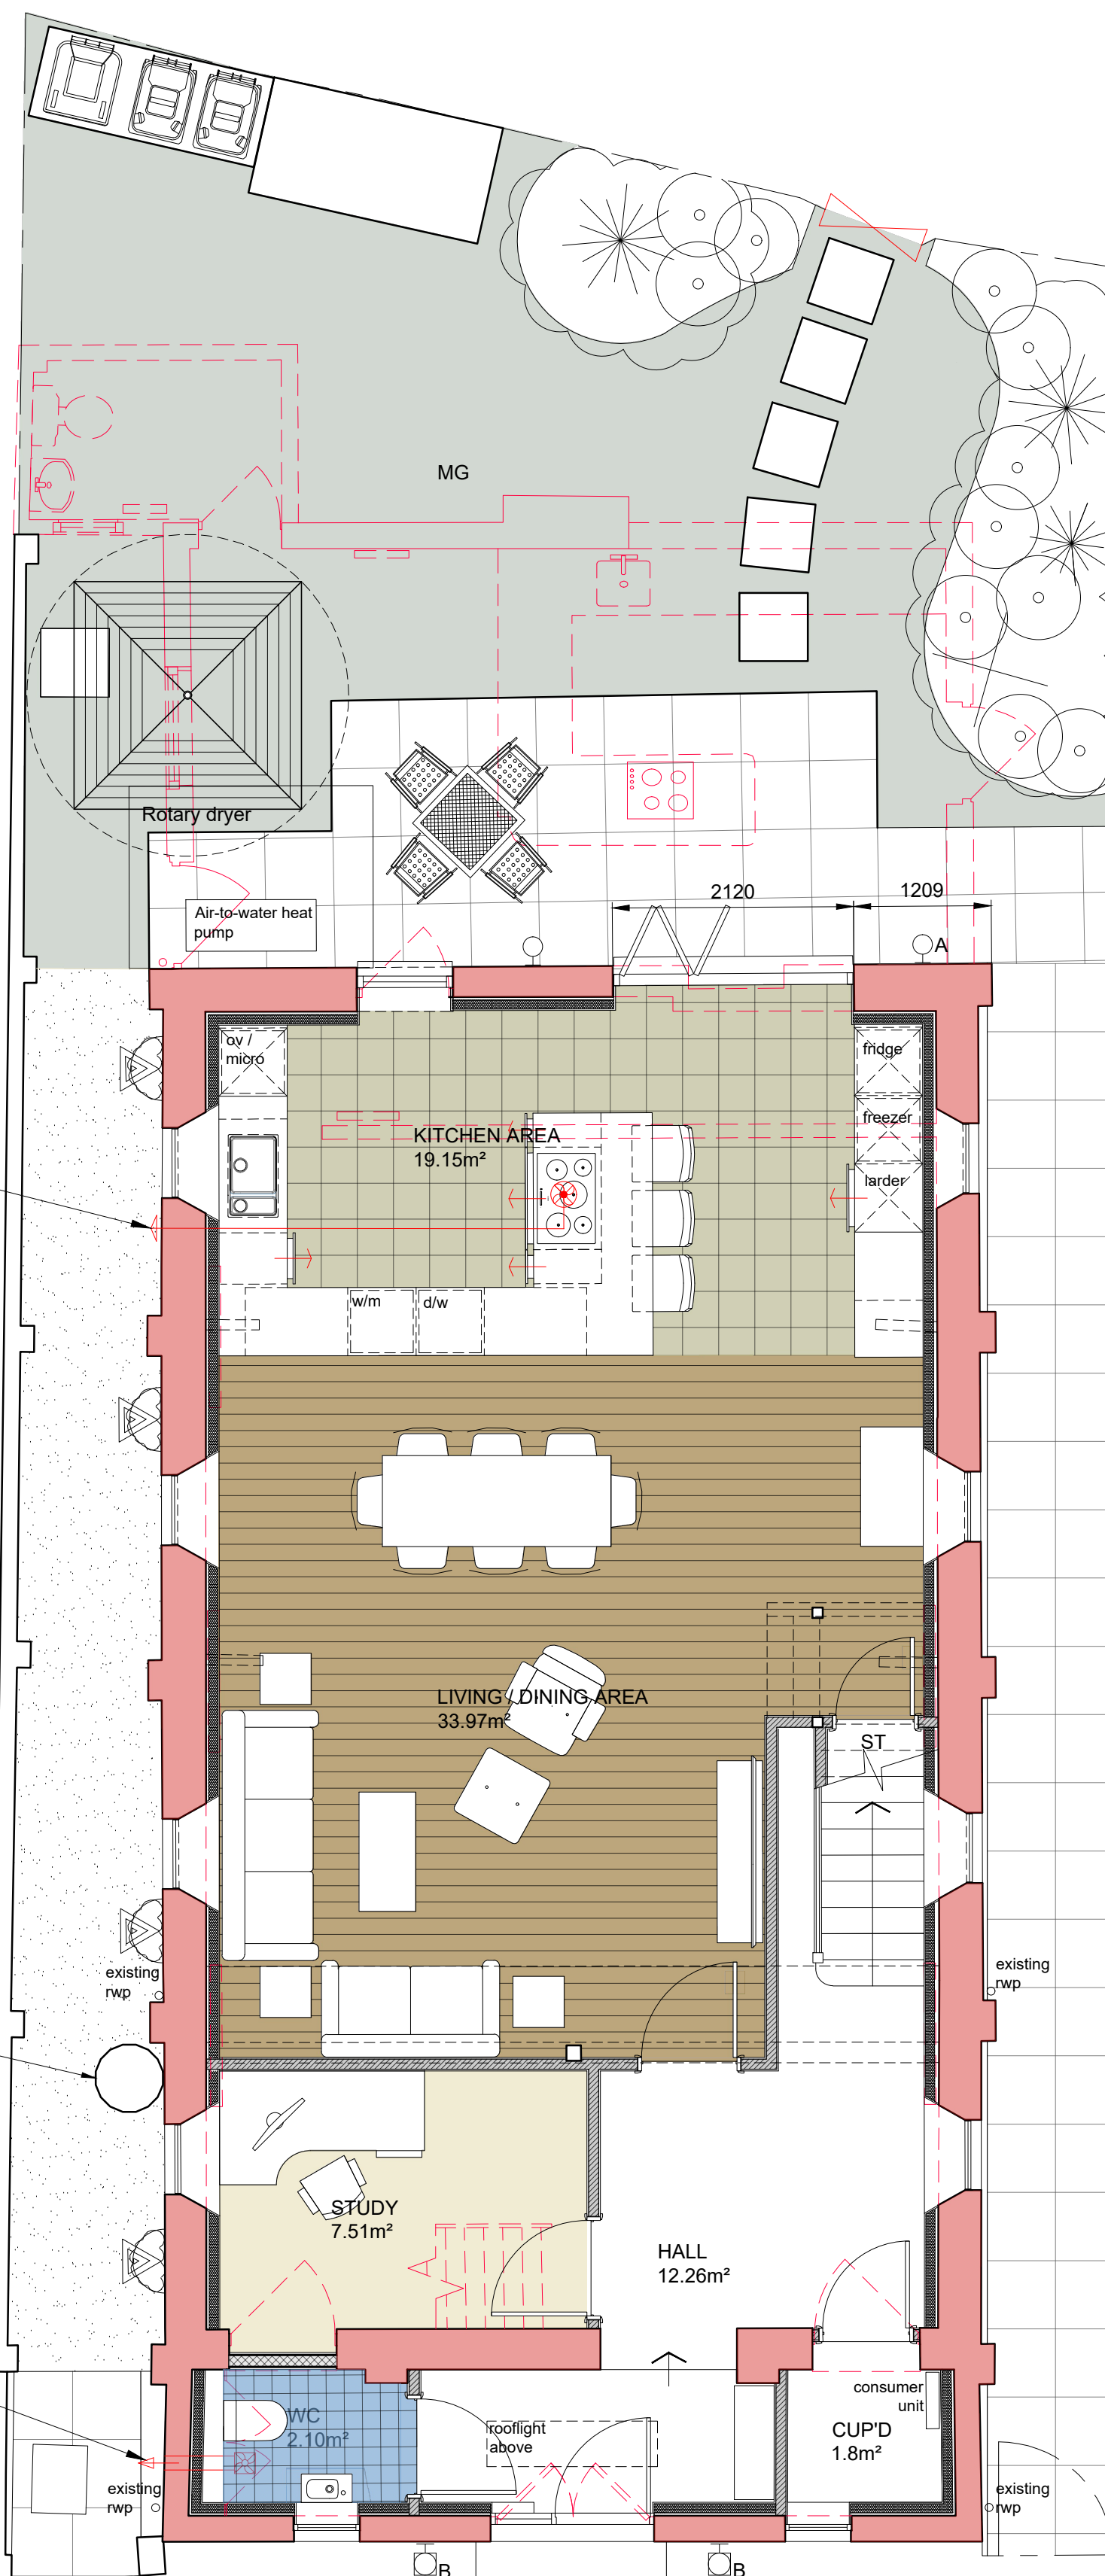

public footpath

HIGH STREET

No. 156

PROPOSED GROUND FLOOR PLAN
scale 1 to 50@A1

This drawing and any information hereon is the
Copyright (C) property of Gardiner Design
Associates. All rights reserved.

All dimensions in millimetres.
This drawing original is at A1.

Rev.	Date.	Description.
------	-------	--------------

PROJECT:

CONVERSION OF OFFICE TO
RESIDENTIAL DWELLING

CLIENT:

MR D JENKINS
CHAPEL STUDIO
158 HIGH STREET, CODICOTE
HERTFORDSHIRE. SG4 8UB

JOB No	GDA-653	DRG. No.	08
SCALE:	1/50@A1	DATE:	JUNE 2023

DRG. TITLE:

PROPOSED GROUND FLOOR
PLAN

GARDINER DESIGN ASSOCIATES



Tel: 01707 272 185
info@gardinerdesign.co.uk
www.gardinerdesign.co.uk