



CONTROL SCHEDULE			
STN	EASTING	NORTHING	LEVEL
101	500.000	200.000	10.000
102	479.800	207.497	9.581
103	484.187	224.725	10.260
104	482.390	226.586	10.513
105	491.645	229.588	10.427

This drawing is based upon survey drawings prepared by
SGD Site Engineering & Surveys Ltd

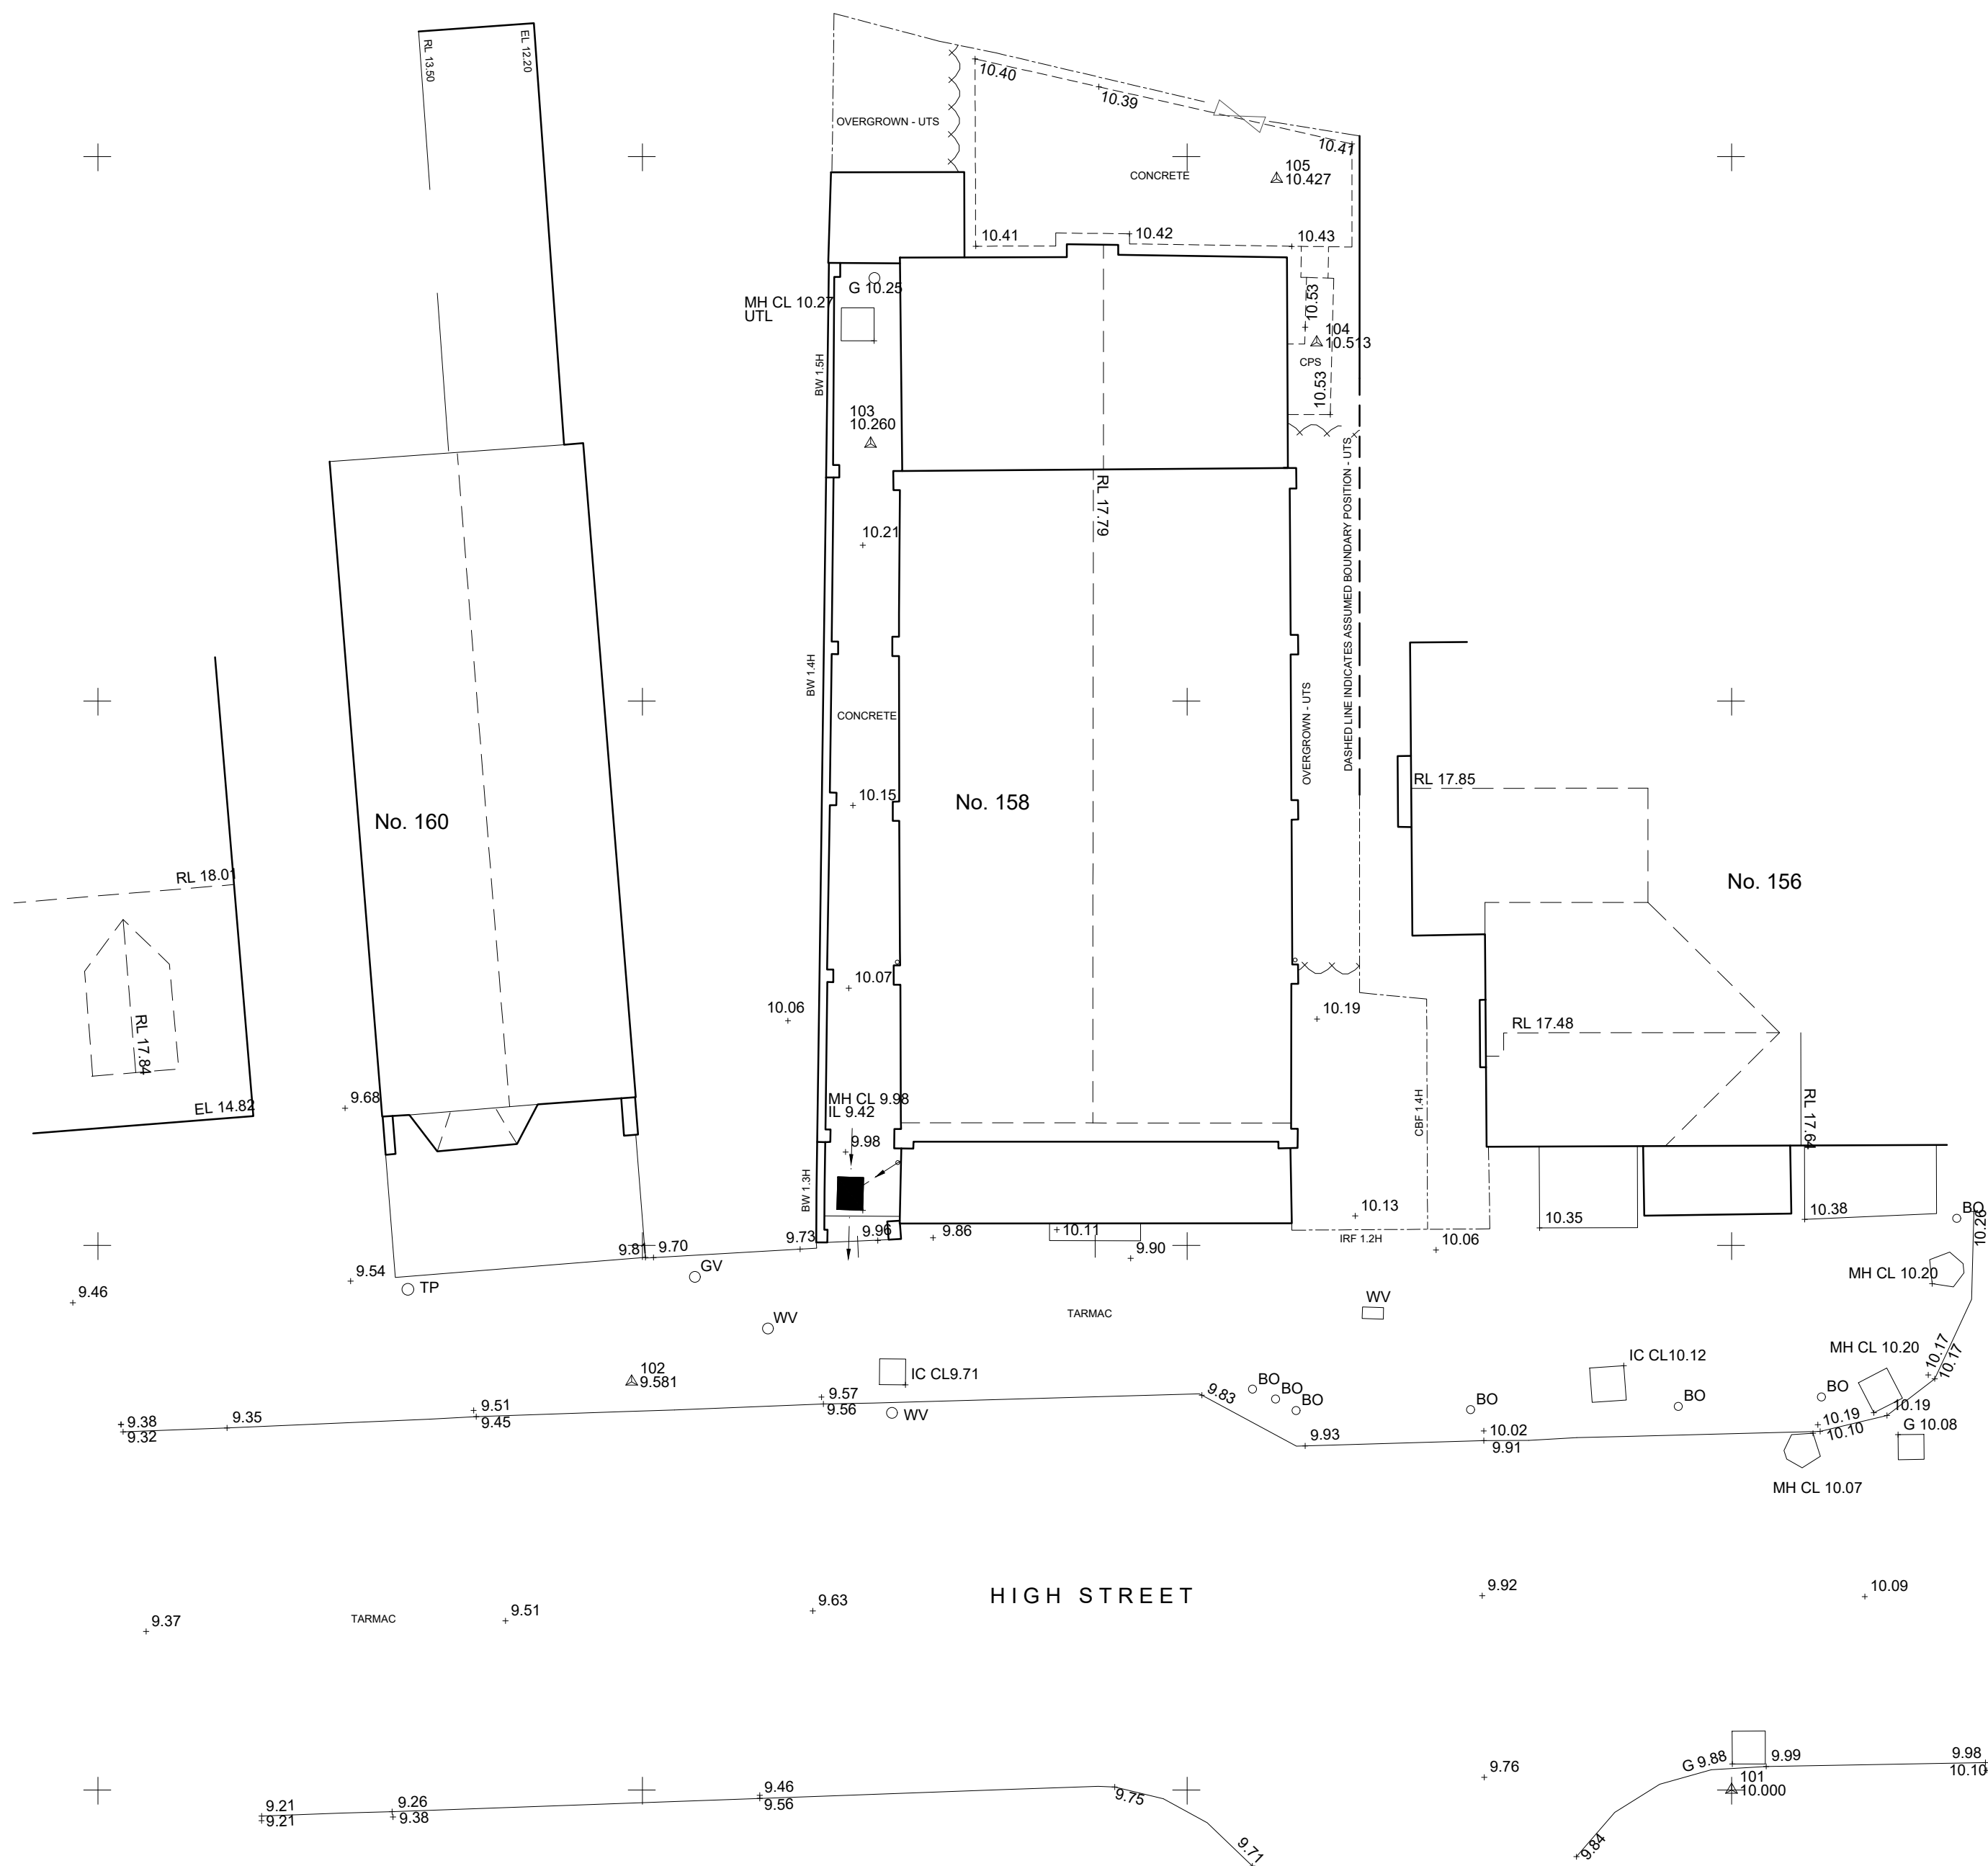

ABBREVIATIONS

AB	Air Brick	DP	Down Pipe	PRF	Post & Rail Fence
B	Bollard or Bottom Heights	EL	Eave Level	PWF	Post & Wire Fence
BB	Belisha Beacon	ELEC	Electricity	R	Render
BD	Back Drop	EP	Electricity Pole	RAD	Radiator
BH	Borehole or Beam Height	FB	Flower Bed	RE	Rodding Eye
BL	Bed Level	FH	Fire Hydrant	RG	Rough Ground
BP	Brick Pavings	FL	Floor Level	RL	Ridge Level
BRW	Brick Retaining Wall	FRL	Fiat Roof Level	RS	Road Sign
BS	Bus Stop	G	Gully	RWP	Rain Water Pipe
BT	British Telecom	GV	Gas Valve	S	Spread or Stone
BW	Brick Wall	H	Height in Metres	SV	Stop Valve
BWF	Barbed Wire Fence	H	Window Head Height	SL	Soffit Level or Skylight
C	Window Cill Height	HT	Height	SP	Arch Springer Height
CB	Control Box	IC	Inspection Cover	SPS	Stone Paving Slabs
CBF	Close Boarded Fence	IL	Invert Level	SW	Stone Wall
CBW	Concrete Block Wall	IRF	Iron Railing Fence	TB	Telecoms Box
CCB	Cable TV Control Box	IWF	Interwoven Fence	TCSU	Traffic Control
CD	Channel Drain	KO	Kerb Outlet	TL	Traffic Light
CHF	Chestnut Paling Fence	L	Light	TP	Telephone Pole
CIF	Corrugated Iron Fence	LP	Lamp Post	TPF	Timber Panel Fence
CL	Cover Level	MH	Manhole	TPS	Tactile Paving Slabs
CLF	Chain Link Fence	MKR	Marker	UTL	Unable To Lift
CPF	Concrete Panel Fence	OV	Over Flow Pipe	V	Vent
CPS	Concrete Paving Slabs	O/H	Overhead	VP	Vent Pipe
CR	Arch Crown Height	P	Post	W	Window
CRW	Concrete Retaining Wall	PALF	Palisade Fence	WL	Water Level
CSU	Ceiling Slopes Up	PHR	Pedestrian Hand Rail	WM	Water Meter
CTV	Cable Television	PIT	Trial Pit	WMF	Wire Mesh Fence
CW	Concrete Wall	PL	Pavement Light	WV	Water Valve
D	Diameter or Doors	PM	Parking Meter	Ø	Diameter

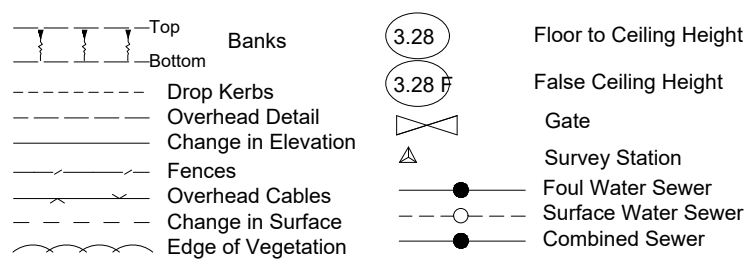

This drawing and any information hereon is the
Copyright (C) property of Gardiner Design
Associates. All rights reserved.

All dimensions in millimetres.

This drawing original is at A1.

Rev. Date. Description.

PROJECT:

CONVERSION OF OFFICE TO
RESIDENTIAL DWELLING

CLIENT:

MR D JENKINS
CHAPEL STUDIO
158 HIGH STREET, CODICOTE
HERTFORDSHIRE. SG4 8UB

JOB No	GDA-653	DRG. No.	03
SCALE:	1/100@A1	DATE:	MAY 2023

DRG. TITLE:

EXISTING SITE PLAN

GARDINER DESIGN ASSOCIATES



Tel: 01707 272 185

info@gardinerdesign.co.uk

www.gardinerdesign.co.uk

EXISTING SITE PLAN
scale 1 to 100@A1