


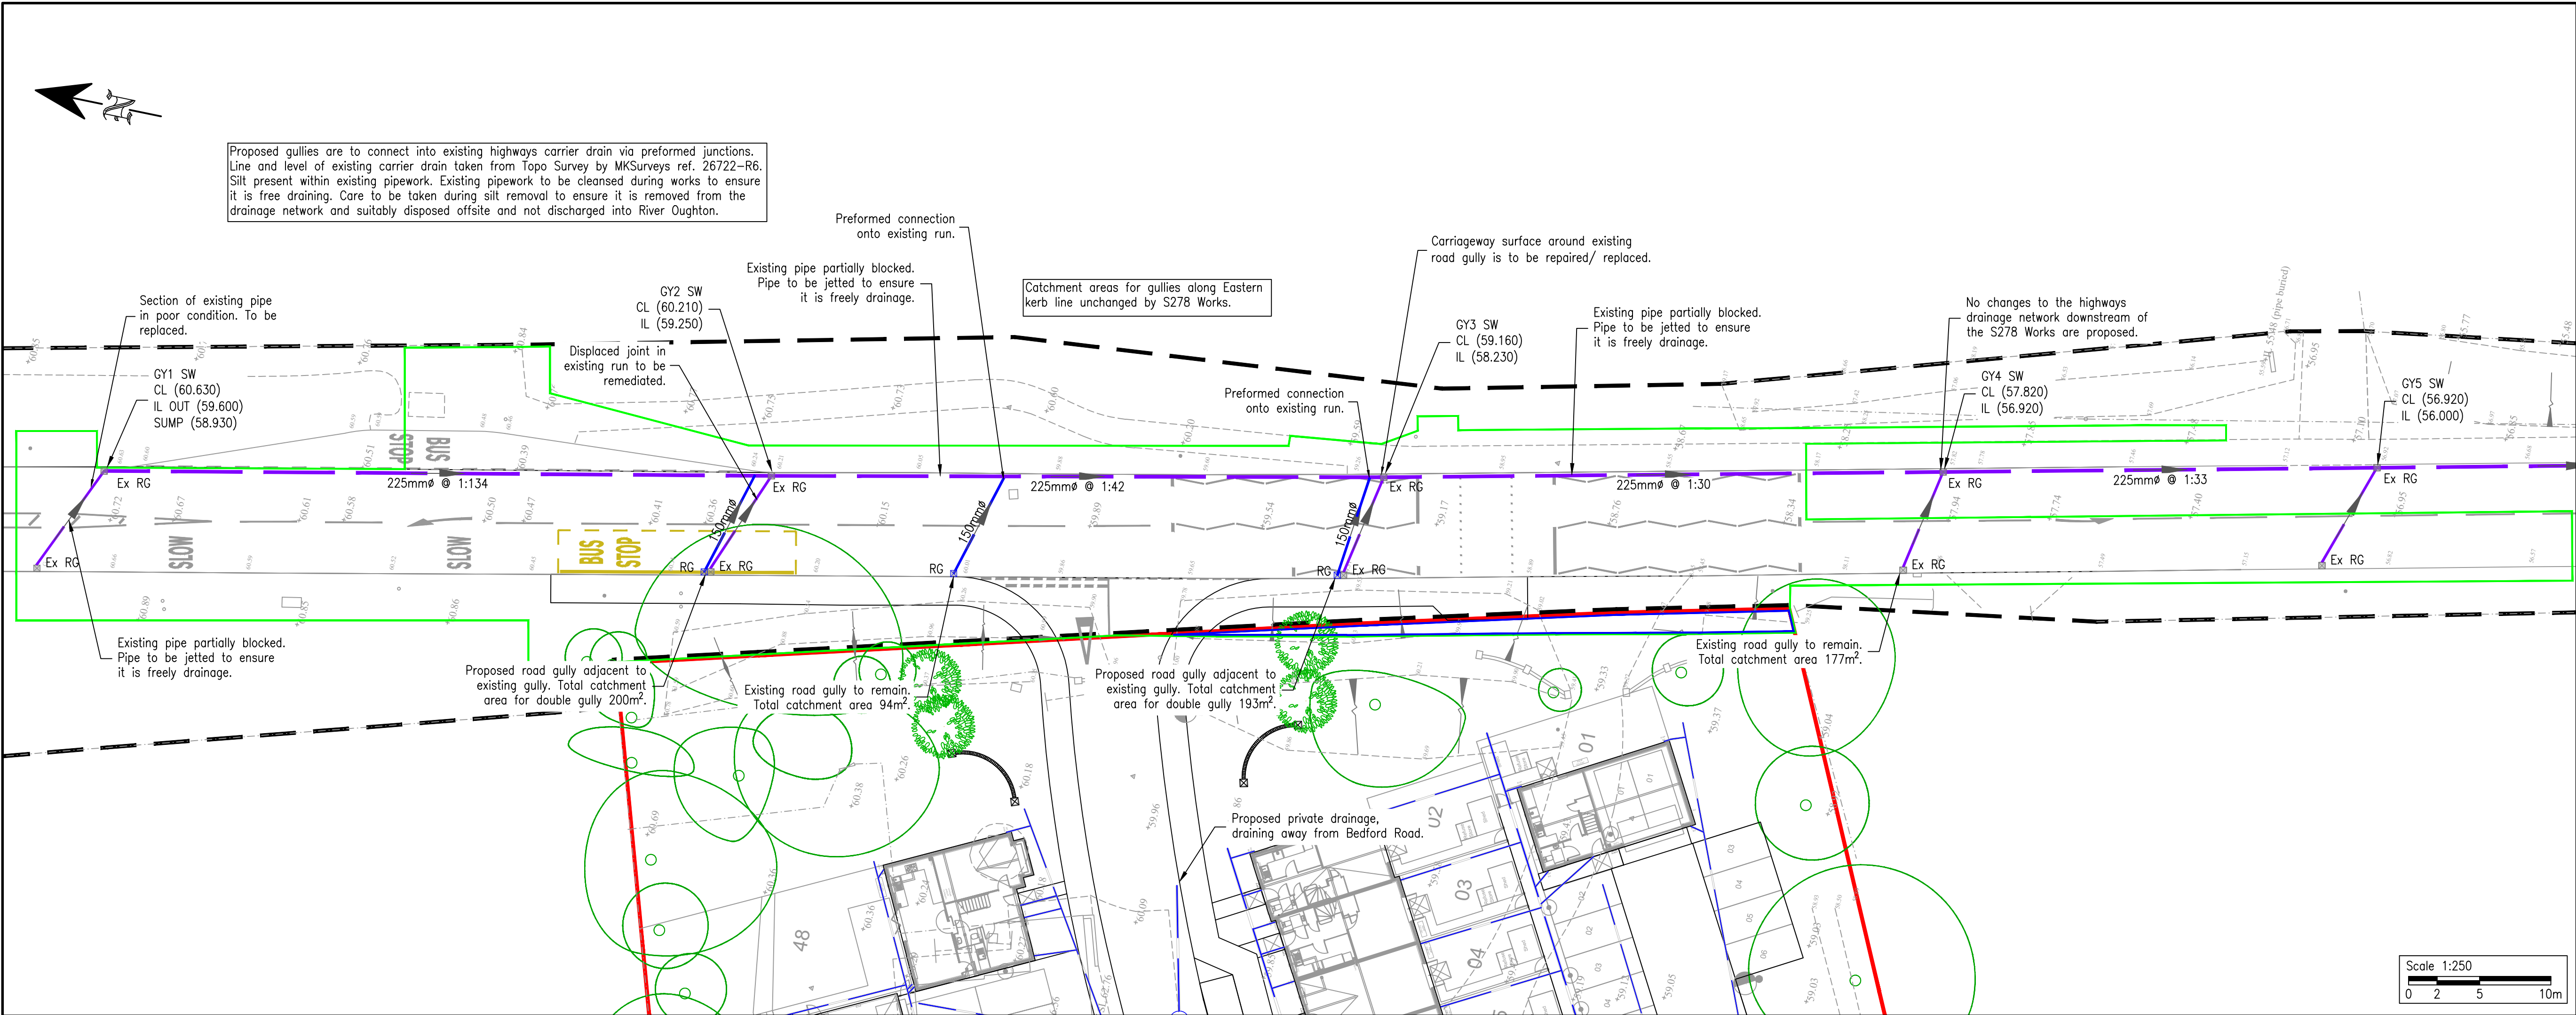

Notes:

- Do not scale from this drawing.
- In case of any discrepancies in drawings, details or bills, refer to engineers for clarification: unilateral decisions by the Contractor will not be accepted.
- This drawing is to be read in conjunction with all related Architects, Consultants & Sub-Contractors drawings and specifications.
- The Contractor is advised that all design drawings and information are to be read concurrently and any discrepancies or omissions reported directly to PTA's Civil Engineering Department.
- Based on topographical survey by Mark Beaver Surveying dated 07.03.2019
- All new pipework to be uPVC to BS EN 1401.
- Pipelines should be laid with a depth of cover of at least 1.5m, when below carriageway. The cover can be reduced to 1m in other locations.


Technical Approval Granted 26.01.24. Commencement of works subject to signed S278 agreement & Permit to Work.

Key:

- Site Boundary
- Extent of Section 278 Works
- Extent of Land to be Dedicated
- Highway Boundary
- Proposed/ Existing Road Markings
- Existing Highways Surface Water Drainage Network
- Proposed S278 Surface Water Drainage Network
- Proposed Private Surface Water Drainage Network
- Ex RG RG Existing/ Proposed Road Gully
- Catchment Area
- 1,001 Microdrainage Pipe References

© Powell Tolner & Associates Ltd.
The contents of this drawing may not be reproduced in whole or in part without the prior written permission of Powell Tolner & Associates.

DRAWING STATUS

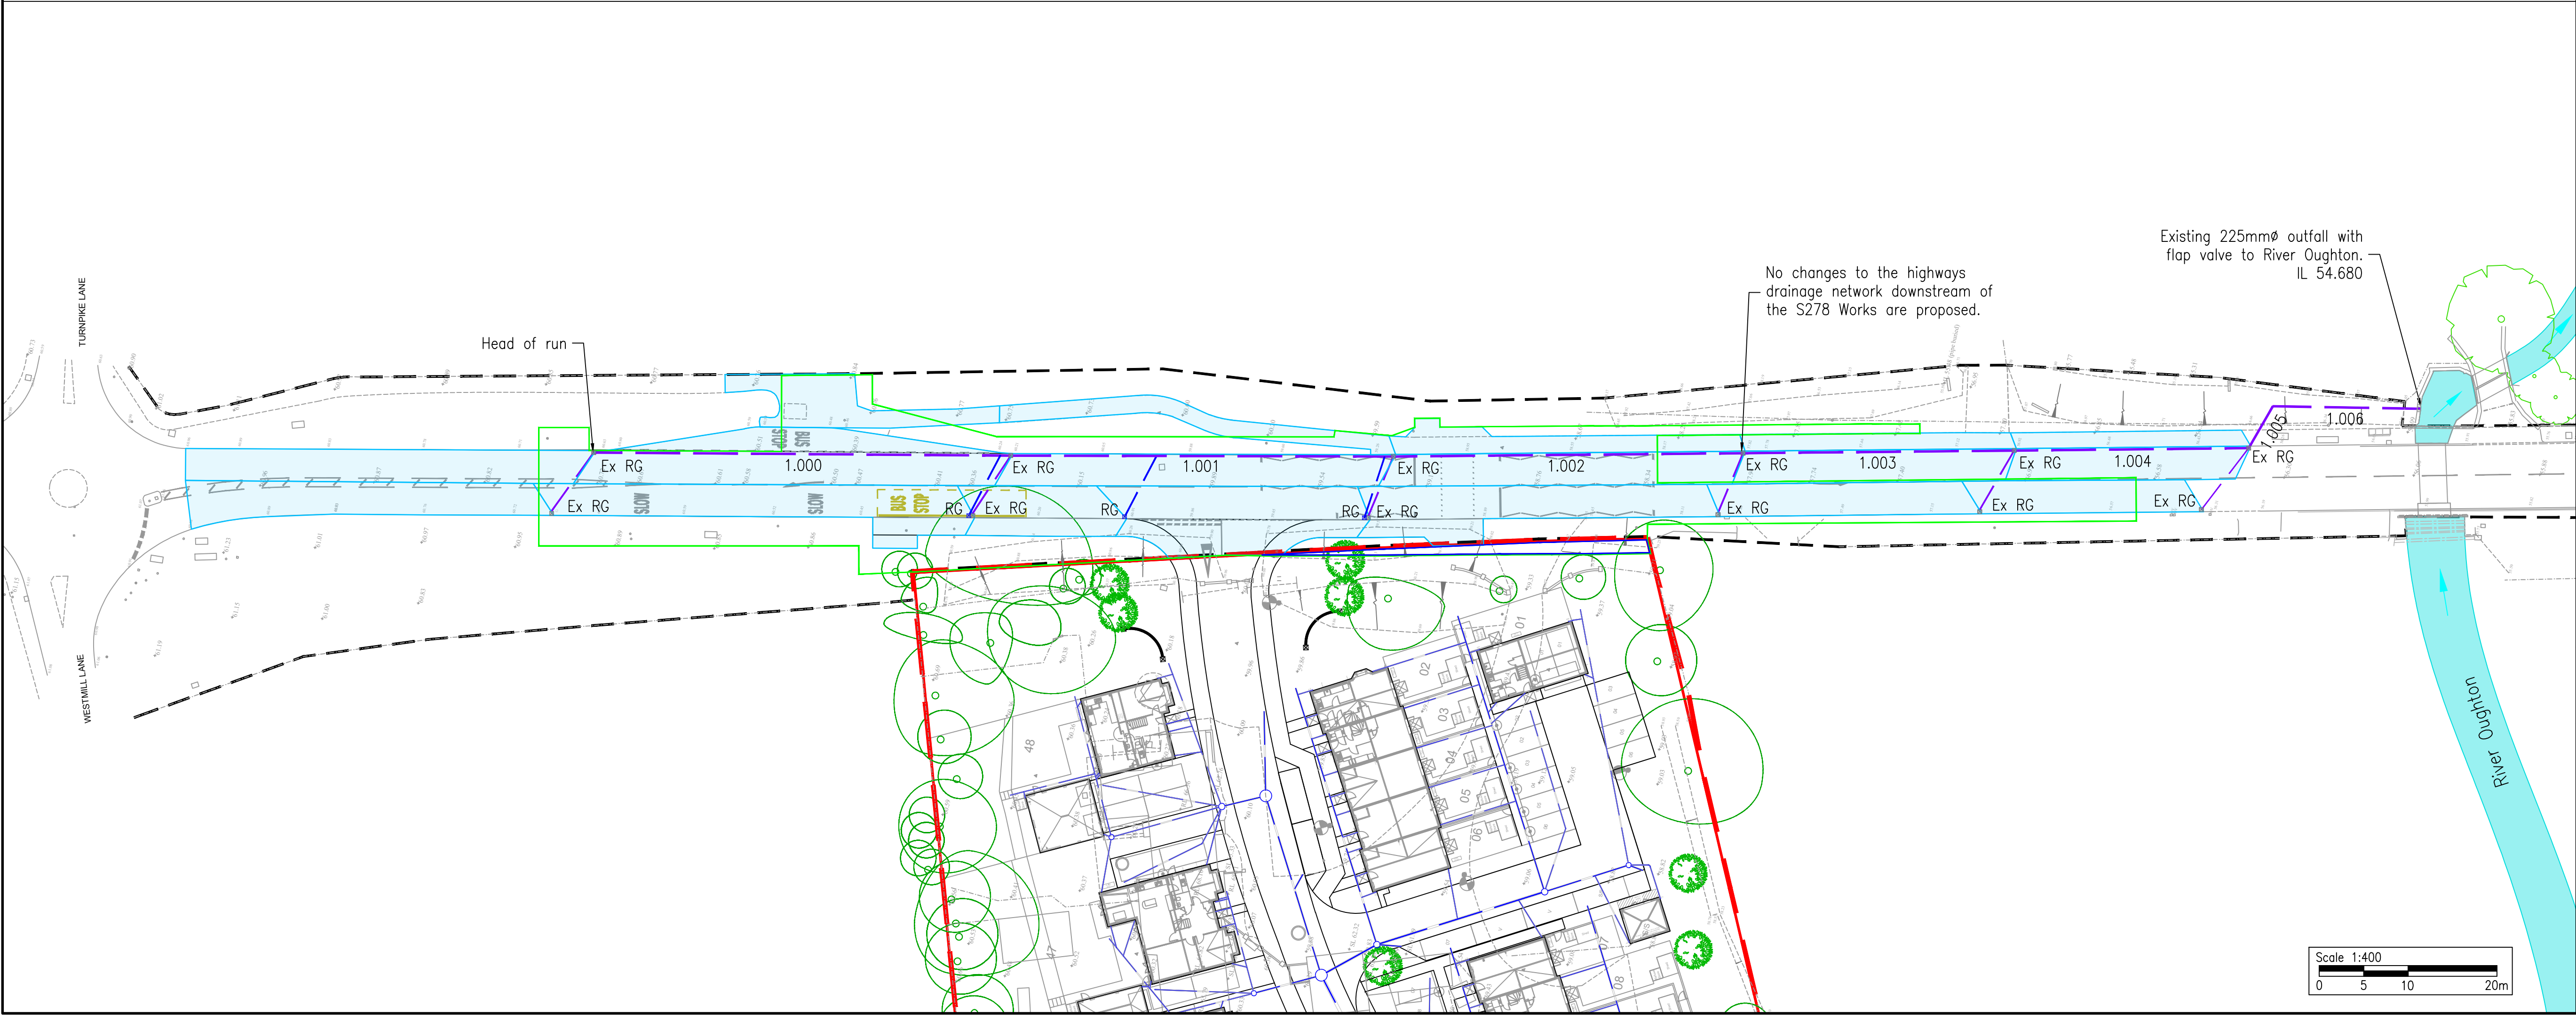

FOR CONSTRUCTION

REV	DESCRIPTION	BY	DATE	CHK'D
C01	Issued for Construction	TA	26.01.24	AH
P07	Notes Updated	TA	17.11.23	AH
P06	S278 Boundary Updated	TA	18.10.23	AH
P05	S278 Boundary Updated	TA	07.07.23	AH
P04	Strategy Updated Following Drainage Survey. Details Moved to Separate Sheet	TA	25.05.23	AH
P03	Footpath Locally Widened West of Puffin Crossing	TA	20.03.23	AH
P02	Drainage Strategy Revised	TA	06.03.23	AH
P01	First Issue	TA	07.12.22	AH

PROJECT TITLE
Bedford Road, Ickleford Hertfordshire

DRAWING TITLE
S278 Drainage Layout

DATE	Dec. 2022	CHECKED DO	CHECKED ENG	PTA PROJ No
DRAWN	TA			9607
SCALE	1:250 / 1:500	TA	AH	REVISION
DRG SIZE	A1 / A3			C01

DRAWING NO
00061-8421-C- S278 - GA

Consulting Civil & Structural Engineers

pta
29 Red Lion Street
Chesham
Bucks.
HP5 1EJ
Tel. 01494 772721
www.ptaconsult.co.uk