




ABB CHARGE POST FOUNDATION PLAN
SCALE 1:50

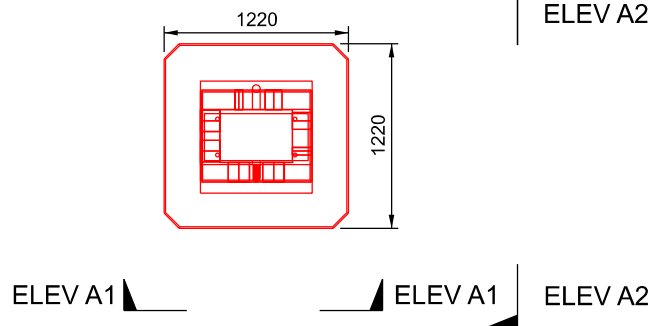


HP CABINET FOUNDATION PLAN
SCALE 1:50

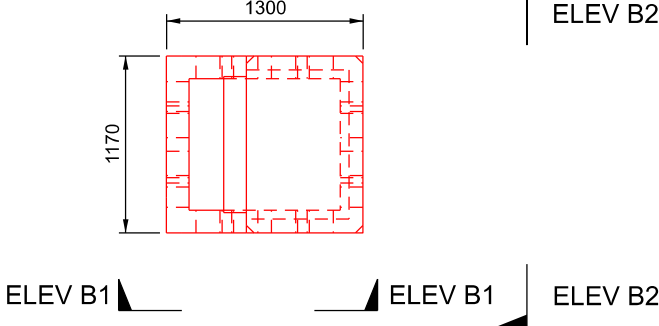


ELEVATION A1
SCALE 1:50

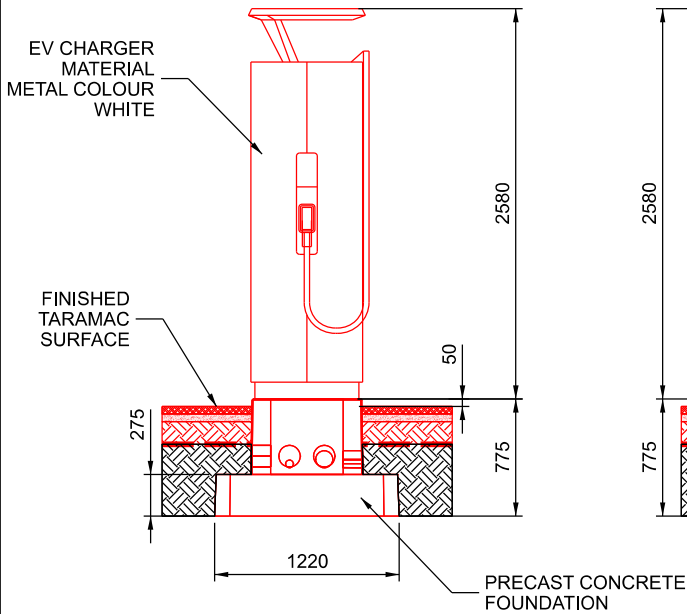


ELEVATION A2
SCALE 1:50

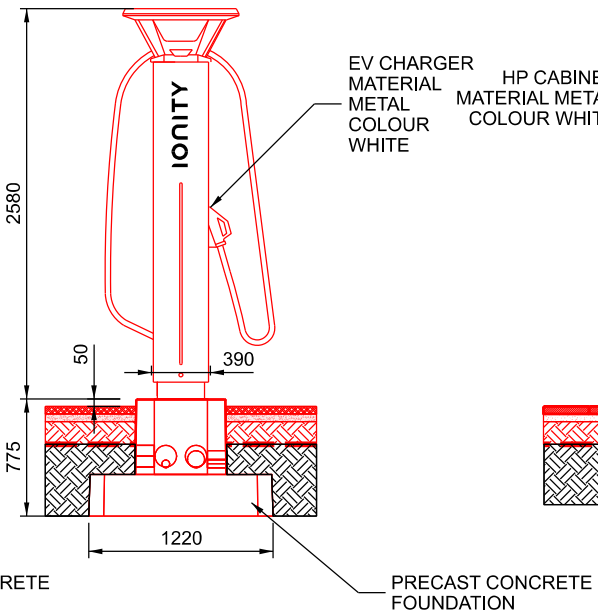


ELEVATION B1
SCALE 1:50

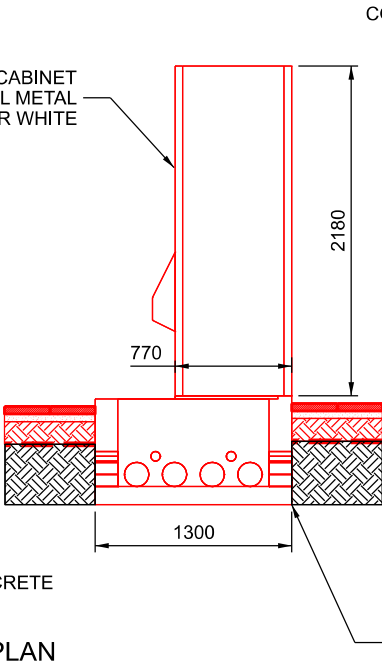


ELEVATION B2
SCALE 1:50

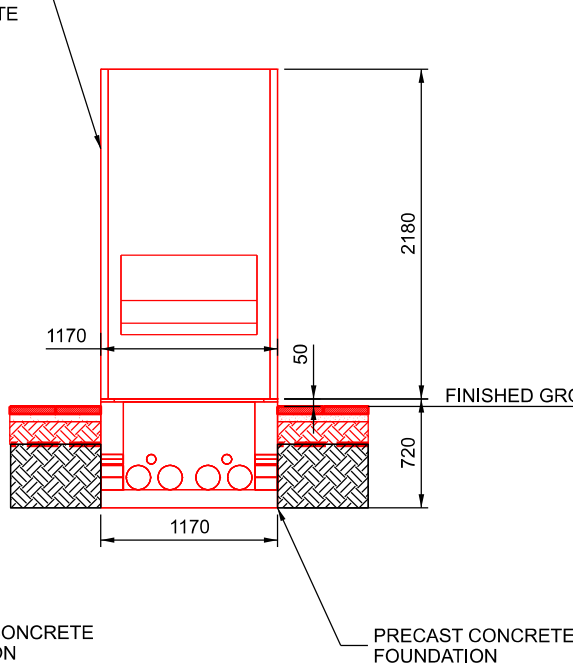


HYC 400 ALPITRONIC CHARGER PLAN
SCALE 1:50

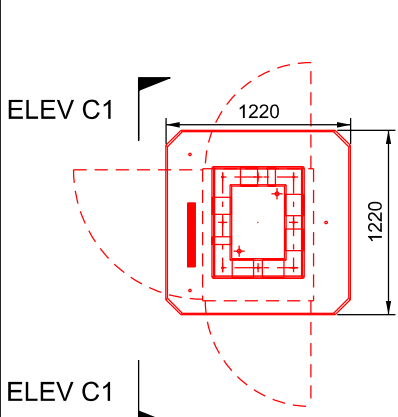


ELEVATION C1
SCALE 1:50

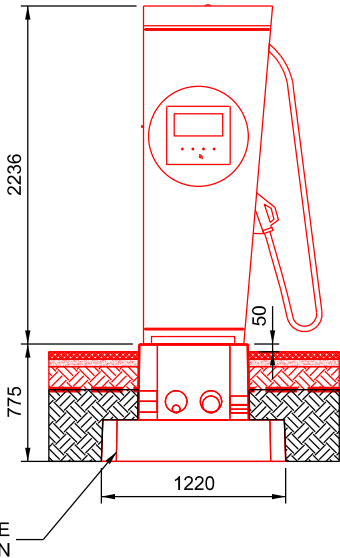


NAL BOLLARD PLAN
SCALE 1:50

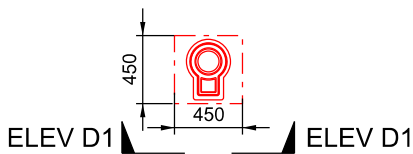

ELEVATION D1
SCALE 1:50

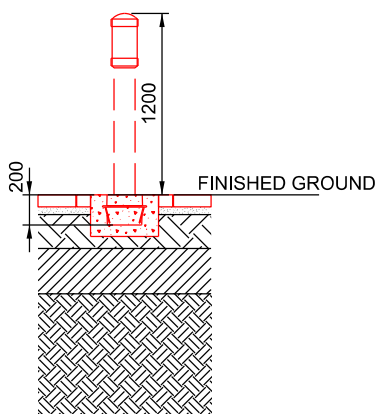

LV PANEL ELEVATION
SCALE 1:50

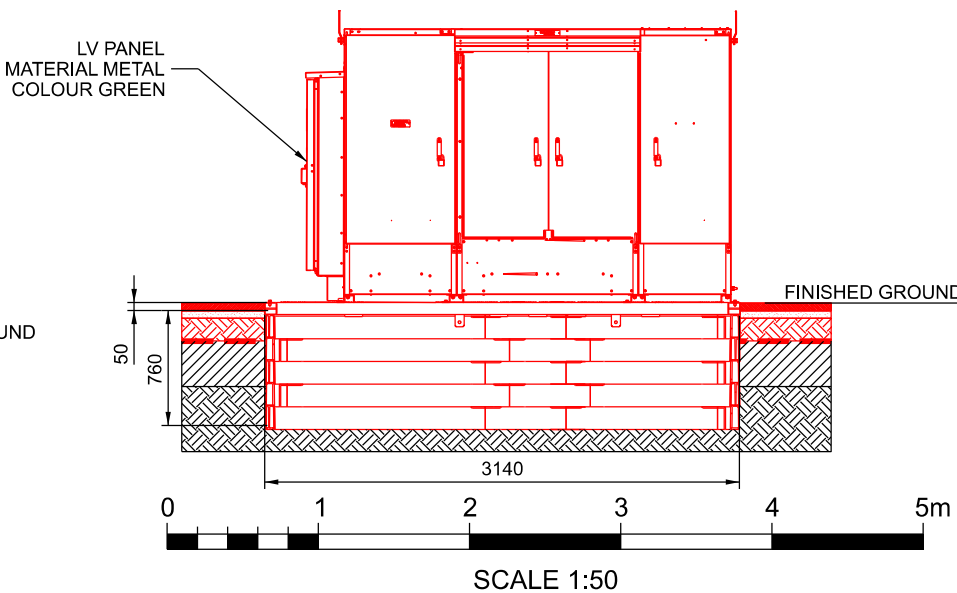

NOTES:
1. ALL DIMENSIONS ARE IN MILLIMETRES (mm) AND LEVELS ARE IN METRES (m) UNLESS STATED OTHERWISE.

COLOUR CONVENTIONS
BLACK - EXISTING OR UNCHANGED
BLUE - MODIFIED OR TO BE MOVED
GREEN - REDUNDANT OR TO BE REMOVED
RED - PROPOSED OR ADDITIONAL
PURPLE - WORKS BY OTHERS/FUTURE WORKS

P02	07/06/24	ISSUED FOR REVIEW	ADI	Chk	App
P01	22/02/24	ISSUED FOR REVIEW	VK	Chk	App
Rev	Date	Description of Revisions	Drawn	Chkd	Appr

S0 - WORK IN PROGRESS

POISE

Poise Group Ltd
No.5 C - D Bear Lane
London
SE1 0UH

Contractor(s)

IONITY

Ionity GmbH
Moosacher Strasse 84,
D-80809 Munich
Germany

Project

9586 - IONITY
BALDOCK

Drawing Title

GENERAL TYPICAL DETAILS

Designed	V KUMAR	Signed		Date	13/02/24
Drawn	V KUMAR	Signed		Date	22/02/24
Checked	Checked	Signed		Date	Date3
Approved	Approved	Signed		Date	Date4
Scale(s)	1:50	ELR & Mileage	ELR&Mileage		
Alternative Reference	-			Sheet	01 of 01
Drawing Number	9586-POI-DRG-CIV-200017			Revision	P02