


Indicative

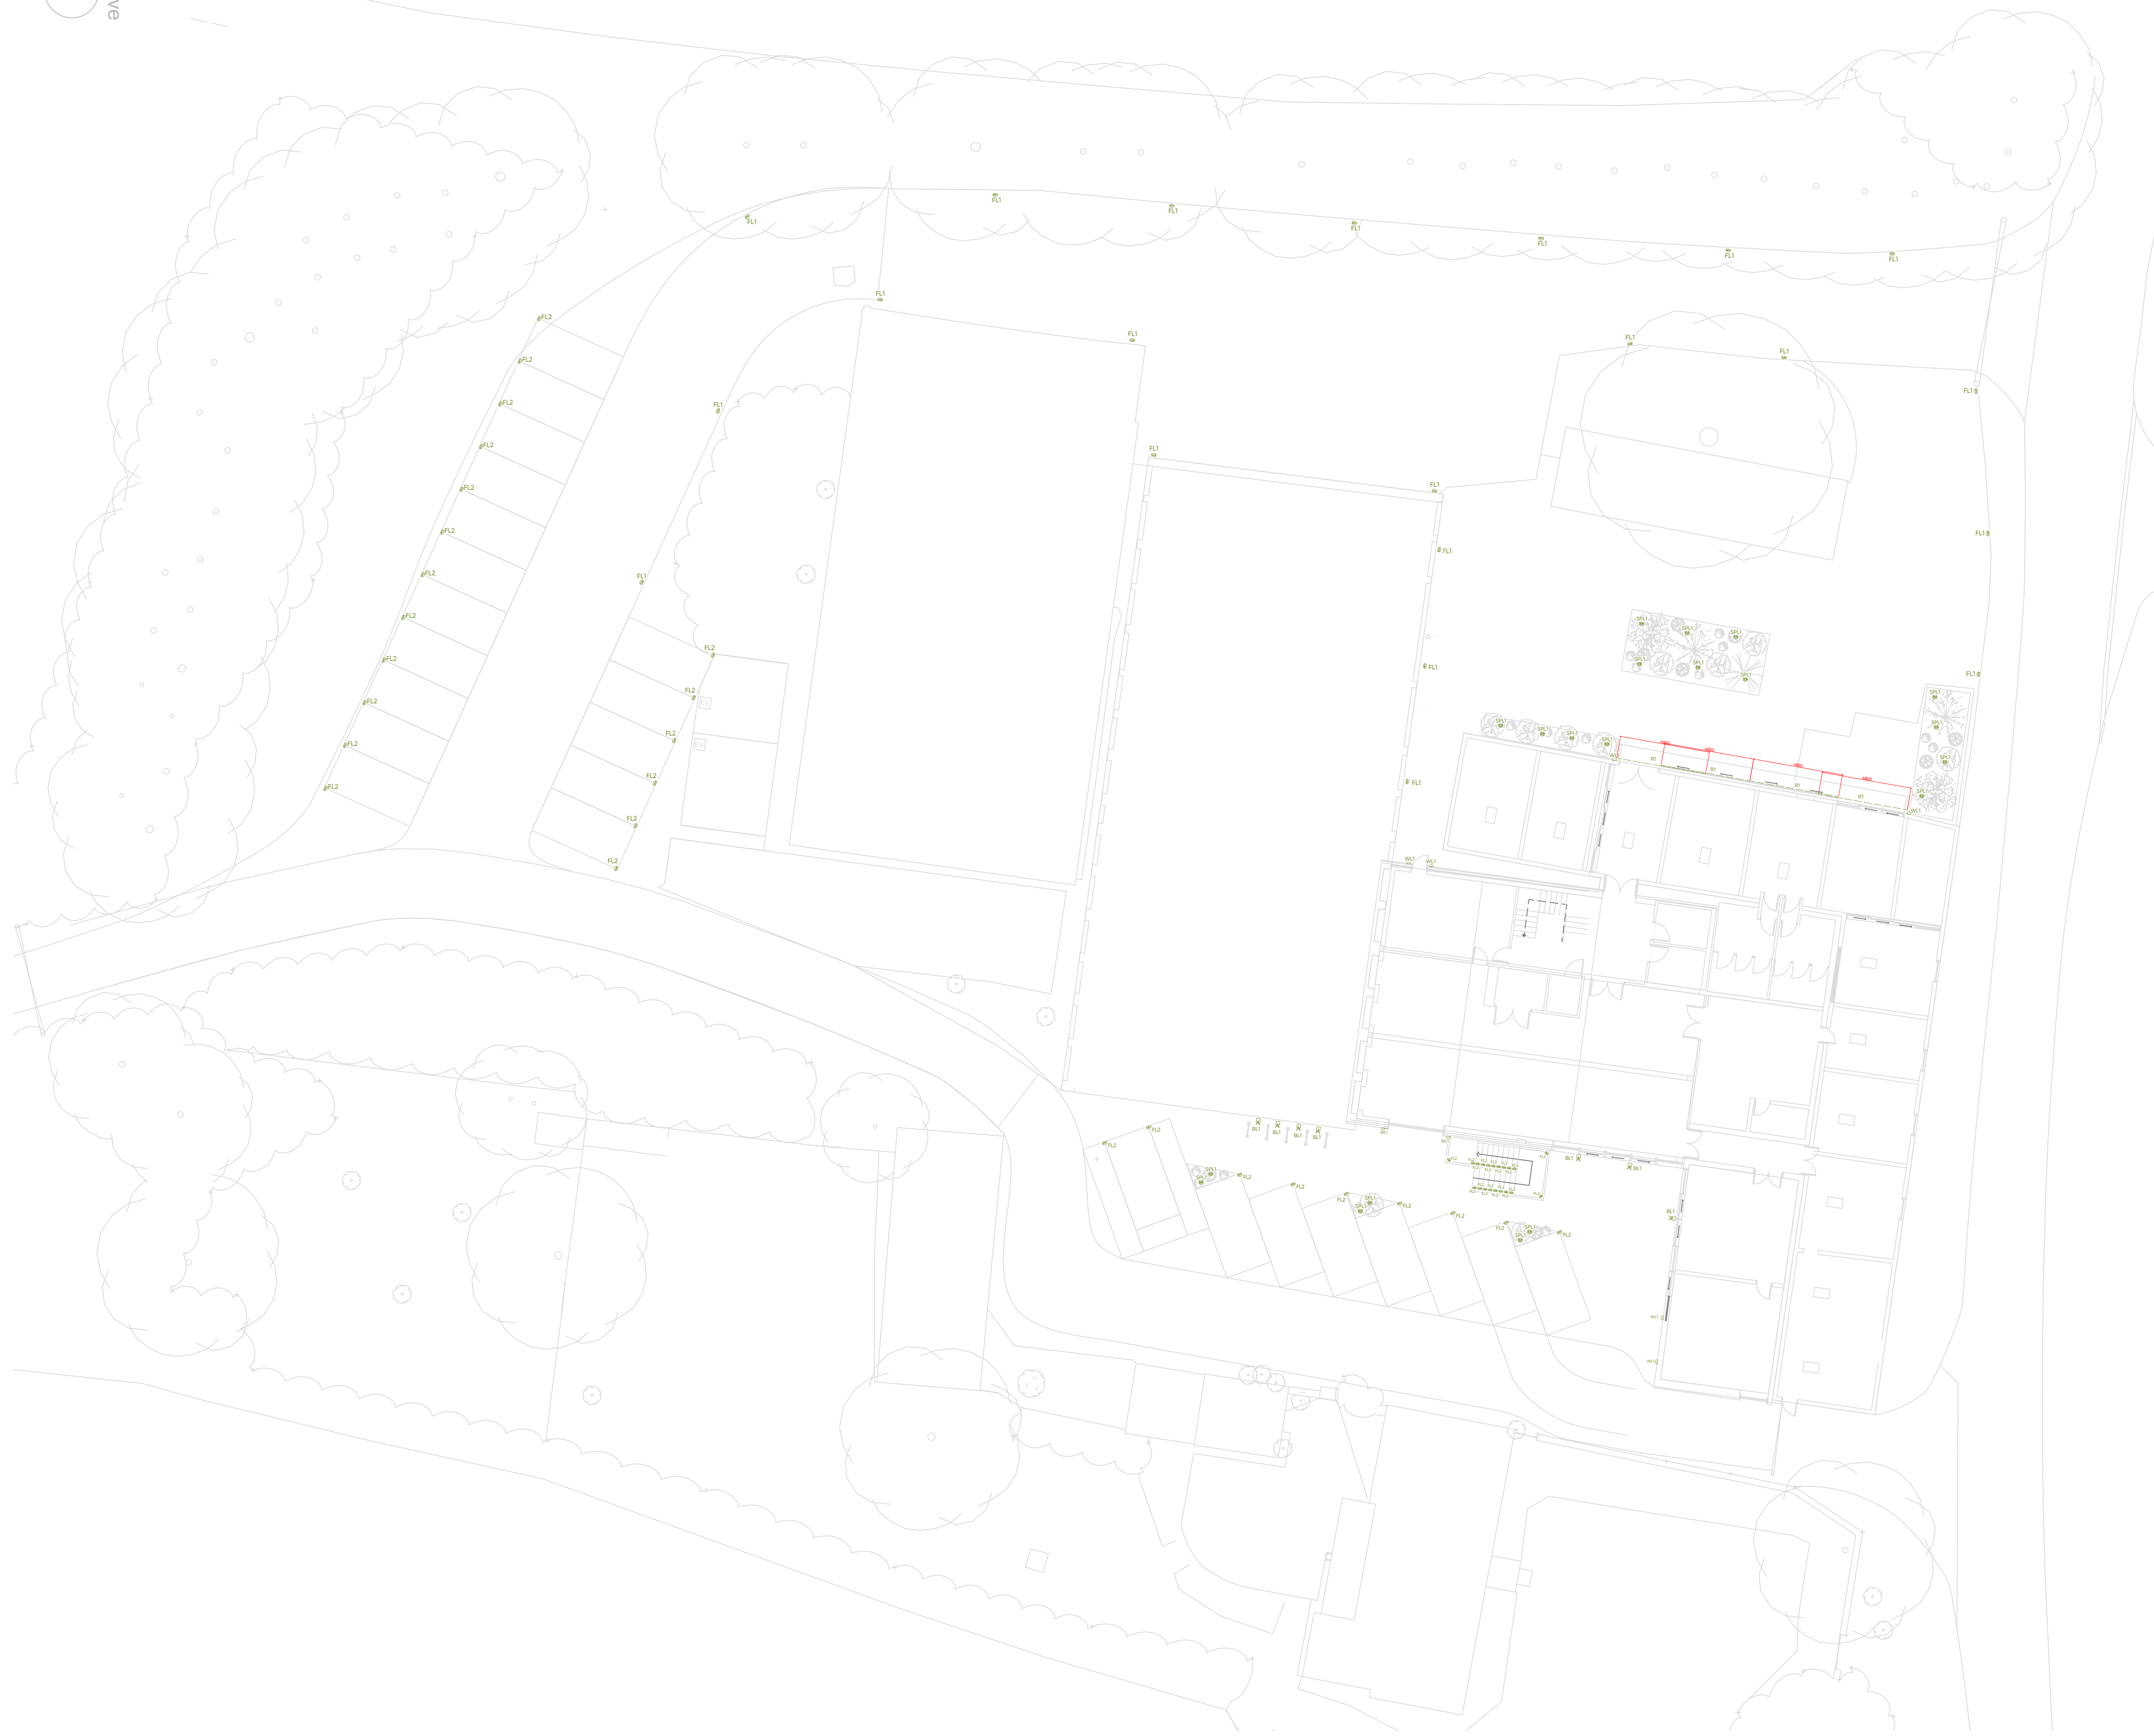

# Key

## Notes

- Drawing to be cross-referenced with the Luminaire Schedule.
- Light fitting symbols are not to scale.
- Mounting and suspension heights are to the centre of the fitting.
- Dimensions are provided in millimeters.
- WL1 fittings are to be mounted 1.8m above the ground.
- R1 fittings are to be installed within the roof soffit, directed downward to illuminate the sign.

## Luminaires

- |      |  |               |
|------|--|---------------|
| BL1  |  | Bollard light |
| FL1  |  | Floor light   |
| FL2  |  | Floor light   |
| R1   |  | Ribbon        |
| SPL1 |  | Spikelight    |
| WL1  |  | Wall light    |



ECOLOGICAL LIGHTING  
SOLUTIONS  
WILDLIFE-FRIENDLY LIGHTING DESIGN

Rev: 1  
Reason: Additional calculation surfaces added  
Status: For planning  
Date: 11/03/2026

Project  
Groundschool Irongate Farm

Client  
Irongate Farm Partnership

Drawing title  
Layout Drawing – Site 01

Drawing no.  
P26025 – 00 – 01

|                       |                   |                     |
|-----------------------|-------------------|---------------------|
| Project no.<br>P26025 | Service no.<br>S1 | Iteration no.<br>I1 |
|-----------------------|-------------------|---------------------|

|                |                  |                   |
|----------------|------------------|-------------------|
| Drawn by<br>OB | Checked by<br>JK | Scale<br>1:175 A1 |
|----------------|------------------|-------------------|