



GENERAL NOTES:

1. THIS DRAWING IS FOR PLANNING PURPOSES ONLY AND **NOT** FOR CONSTRUCTION.

KEY - STREET LIGHTING EQUIPMENT:

- A8 8m BASE-HINGED COLUMN AND 3000K LED LUMINAIRE A TO HCC SPECIFICATION
- B8 8m BASE-HINGED COLUMN AND 3000K LED B TO HCC SPECIFICATION
- C4 4m MID-HINGED COLUMN AND KIRIUM PRO MINI (SHIELD) 16LED 2.26KLM 2700K LED LUMINAIRE
- C5 5m MID-HINGED COLUMN AND KIRIUM PRO MINI (SHIELD) 16LED 2.26KLM 2700K LED LUMINAIRE
- C4 4m MID-HINGED COLUMN AND KIRIUM PRO MINI (SHIELD) 16LED 2.26KLM 2700K LED LUMINAIRE
- C0 4m MID-HINGED COLUMN AND KIRIUM PRO MINI 4LED 1.02KLM 2700K LED LUMINAIRE
- D4 4m MID-HINGED COLUMN AND KIRIUM PRO MINI 4LED 1.02KLM 2700K LED LUMINAIRE
- D0 4m MID-HINGED COLUMN AND KIRIUM PRO MINI 4LED 1.02KLM 2700K LED LUMINAIRE


EXISTING LIGHTING COLUMN TO BE REMOVED

EXISTING COLUMN TO REMAIN

KEY - OVERHEAD LINE CLEARANCES:

- UKPN HORIZONTAL CLEARANCE FOR 4m HEIGHT COLUMN REFER TO DRAWING 1302 FOR MORE DETAIL
- UKPN HORIZONTAL CLEARANCE FOR 5m HEIGHT COLUMN REFER TO DRAWING 1302 FOR MORE DETAIL
- UKPN & NATIONAL GRID HORIZONTAL CLEARANCE FOR 8m HEIGHT COLUMN REFER TO DRAWING 1302 FOR MORE DETAIL
- NATIONAL GRID HORIZONTAL CLEARANCE FOR 5m HEIGHT COLUMN REFER TO DRAWING 1302 FOR MORE DETAIL

- PLEASE ALSO REFER TO THE FOLLOWING GUIDANCE DOCUMENTS:
- Energy Networks Association Technical Specification 43-8 Issue 5
 - National Grid Technical Guidance Note 287 - Third-party guidance for working near National Grid Electricity Transmission equipment
 - National Grid overhead line profile drawing 4TB001A-074_13714_A
 - UKPN overhead line profile drawing 099-EPN-DR-8430059315-88-000 R1

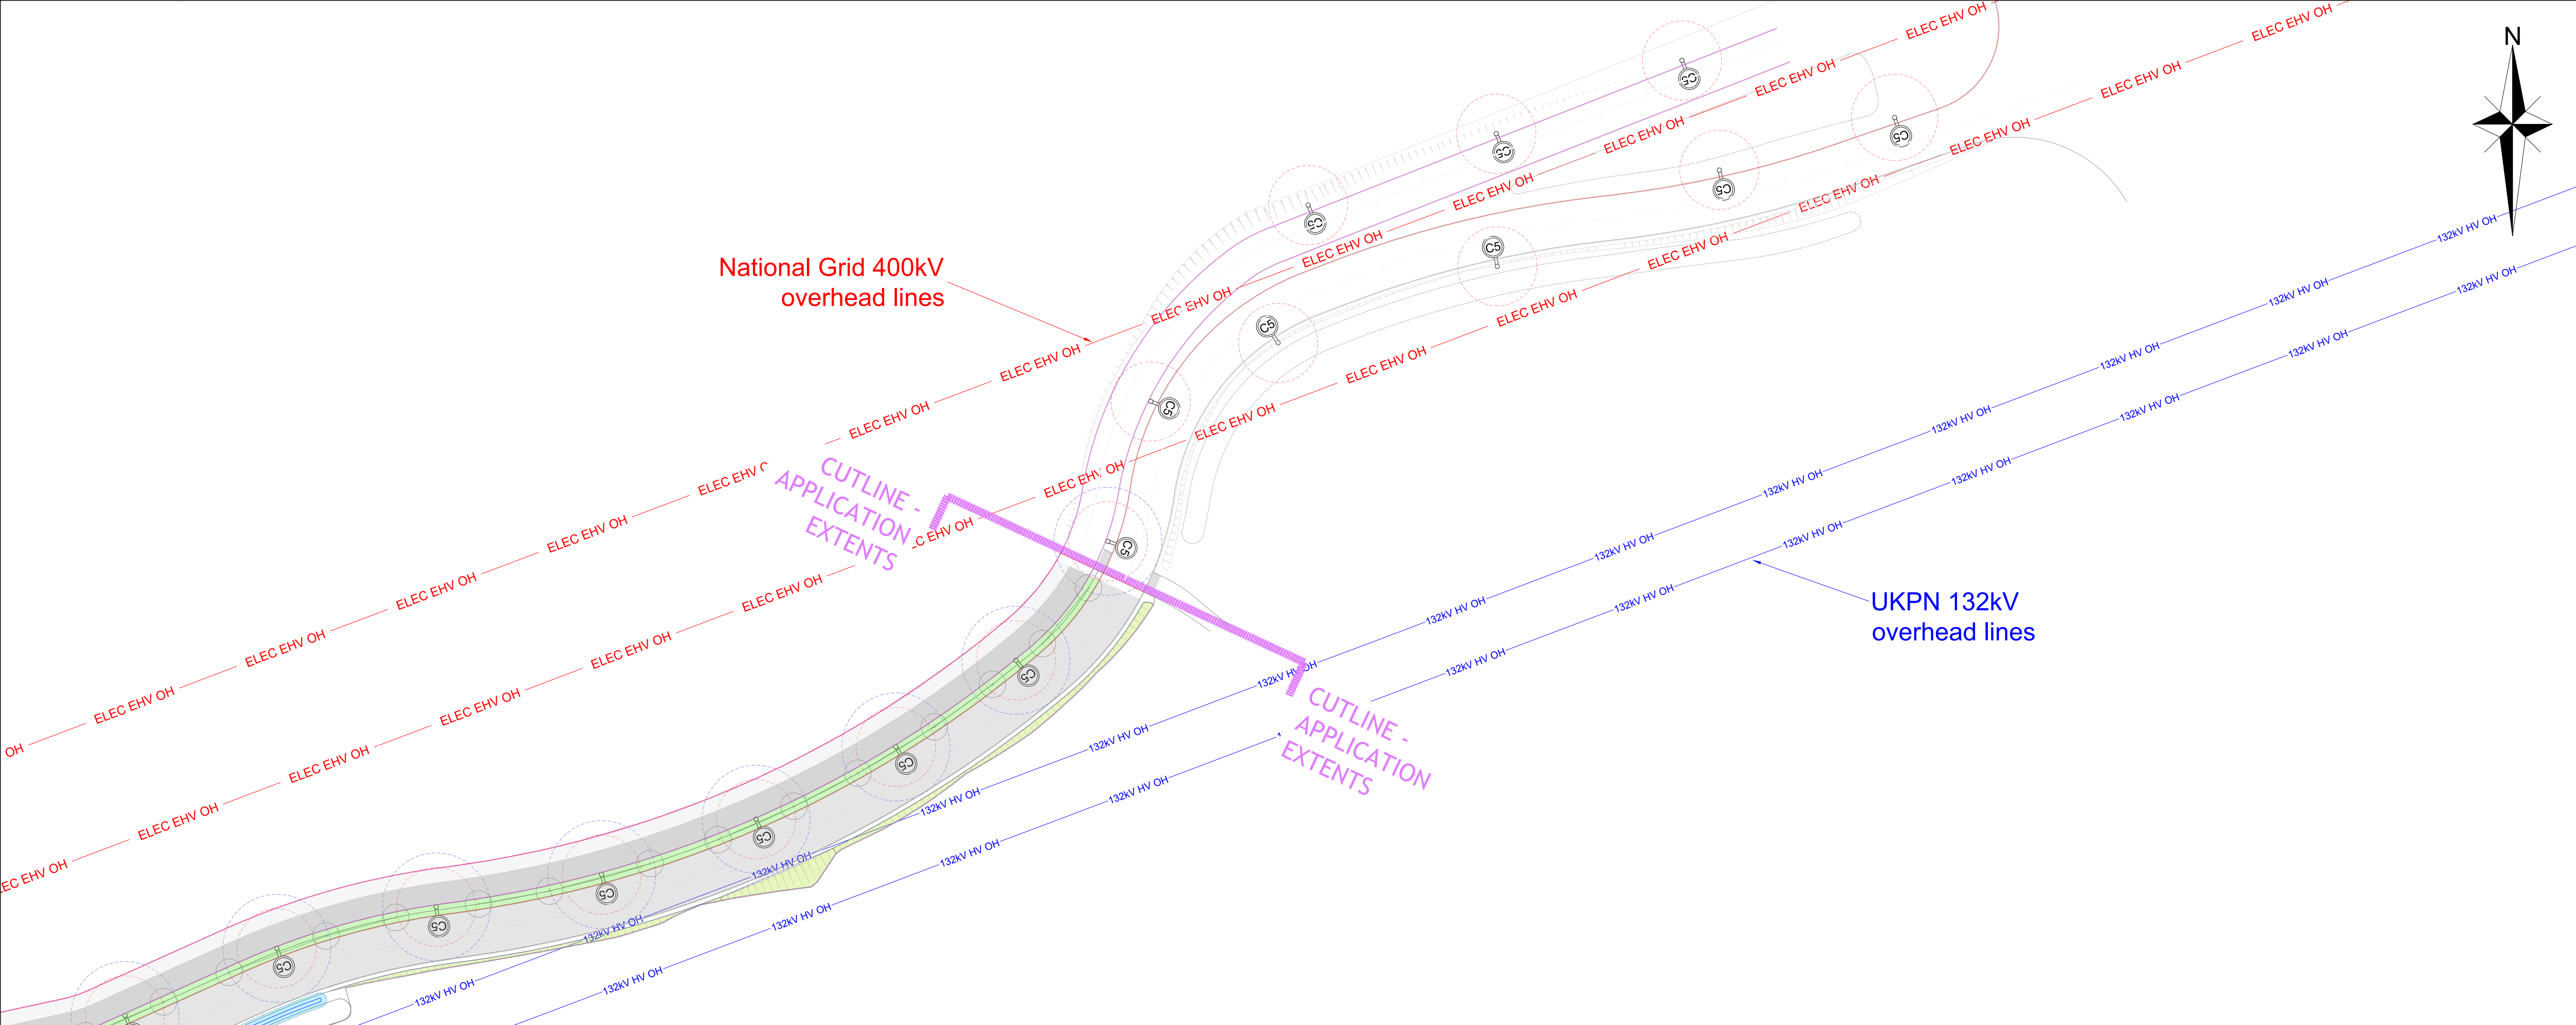

P04	JJ	JJ	03.07.2026	HIGHWAY AND LIGHTING LAYOUT UPDATED
P03	JJ	JJ	03.10.2025	HIGHWAY AND LIGHTING LAYOUT UPDATED
P02	JJ	JJ	22.04.2025	NATIONAL GRID CLEARANCES ADDED
P01	JJ	JJ	17.04.2025	FIRST ISSUE
REV	DRN	DES	DATE	DESCRIPTION
joseph				lighting
www.josephlighting.co.uk				
Client				
PICTURE ESTATES LTD				
Project				
GREAT ASHBY MAIN ACCESS				
Title				
PROPOSED LIGHTING LAYOUT SHEET 1 OF 3				
Scale 1:500	Drawn JJ	Design JJ	Created 08.04.2025	
Drawing No. 100730-JLD-ASH-DR-0001				Revision P04
Status FOR PLANNING				Sheet Size A1