


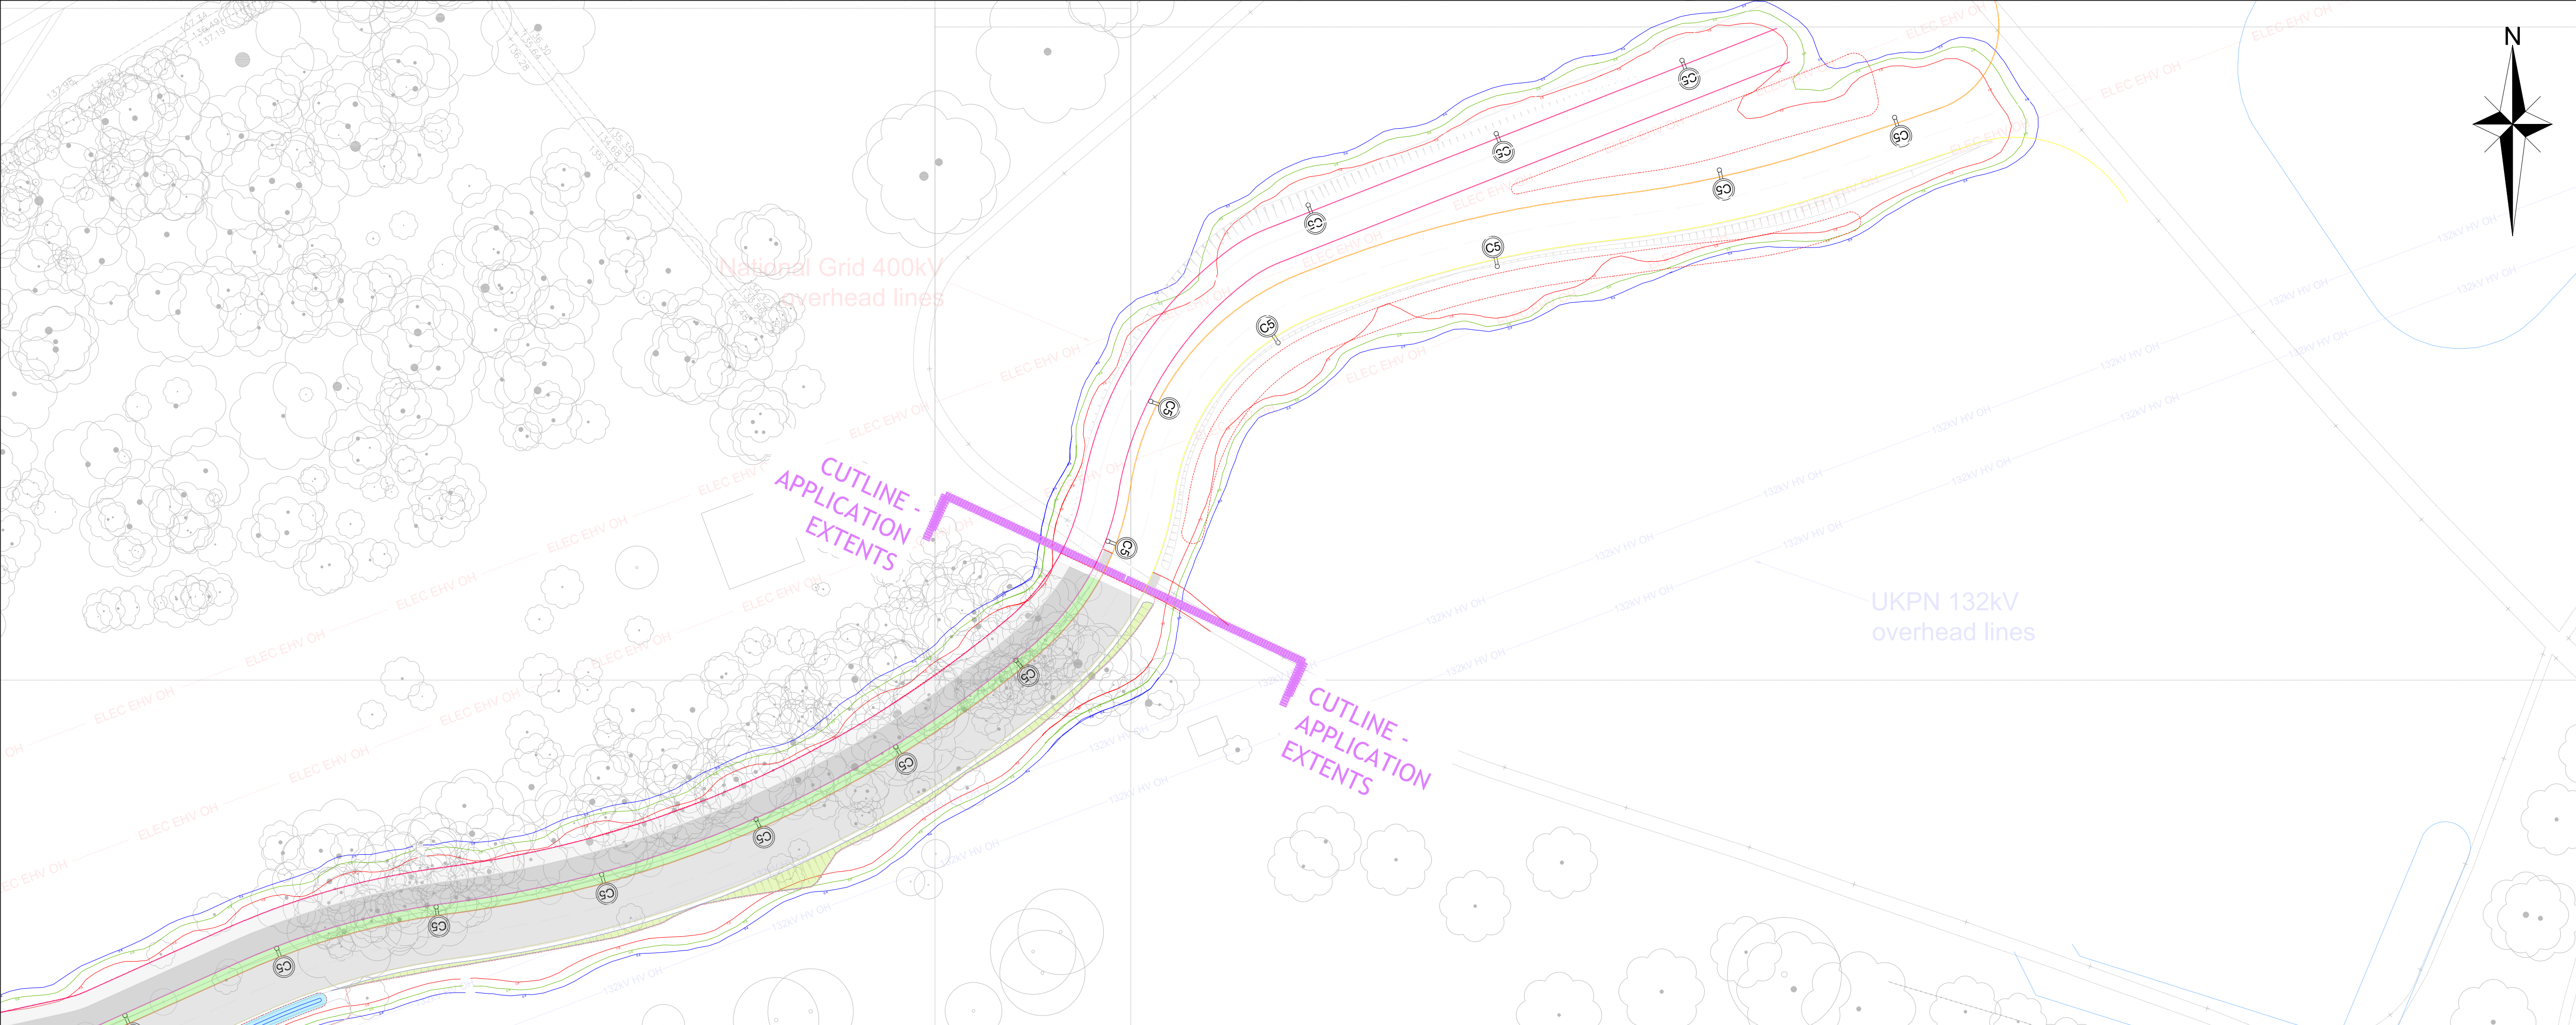

GENERAL NOTES:

1. THIS DRAWING IS FOR PLANNING PURPOSES ONLY AND NOT FOR CONSTRUCTION.

KEY - STREET LIGHTING EQUIPMENT:

- A8 8m BASE-HINGED COLUMN AND 3000K LED LUMINAIRE A TO HCC SPECIFICATION
- B8 8m BASE-HINGED COLUMN AND 3000K LED B TO HCC SPECIFICATION
- C4 4m MID-HINGED COLUMN AND KIRIUM PRO MINI (SHIELD) 16LED 2.28KLM 2700K LED LUMINAIRE
- C5 5m MID-HINGED COLUMN AND KIRIUM PRO MINI (SHIELD) 16LED 2.28KLM 2700K LED LUMINAIRE
- C4 4m MID-HINGED COLUMN AND KIRIUM PRO MINI (SHIELD) 16LED 2.28KLM 2700K LED LUMINAIRE
- P0 4m MID-HINGED COLUMN AND KIRIUM PRO MINI 4LED 1.02KLM 2700K LED LUMINAIRE
- D4 4m MID-HINGED COLUMN AND KIRIUM PRO MINI 4LED 1.02KLM 2700K LED LUMINAIRE
- P0 4m MID-HINGED COLUMN AND KIRIUM PRO MINI 4LED 1.02KLM 2700K LED LUMINAIRE

EXISTING LIGHTING COLUMN TO BE REMOVED

EXISTING COLUMN TO REMAIN

KEY - HORIZONTAL ILLUMINANCE:

- 0.40 LUX CONTOUR
- 0.60 LUX CONTOUR
- 1.00 LUX CONTOUR

REV	DRN	DES	DATE	DESCRIPTION
P01	JJ	JJ	03.07.2026	FIRST ISSUE

joseph lighting

www.josephlighting.co.uk

Client

PICTURE ESTATES LTD

Project

GREAT ASHBY
MAIN ACCESS

Title

PROPOSED LIGHTING LAYOUT
LUX PLOT
SHEET 3 OF 3

Scale	Drawn	Design	Created
1:500	JJ	JJ	08.04.2025

Drawing No.	Status	Revision
100730-JLD-ASH-DR-0003	FOR PLANNING	P01

Sheet Size
A1