


These details are confidential to illustrate the engineering services only for the purpose intended. Arrange to suit current architectural and structural details which may vary to some degree from these details. This drawing must be viewed and printed using Adobe Acrobat Version 9.0 or above when using as a PDF format.
Do not scale from this drawing in either paper or digital format. To check the drawing has been printed at the intended scale this bar should be 25mm long at A3, 50mm long at A1 and 75mm long at A0.

- Notes
- THIS DRAWING SHOULD BE READ IN CONJUNCTION WITH ALL OTHER CONTRACT DOCUMENTATION.
 -

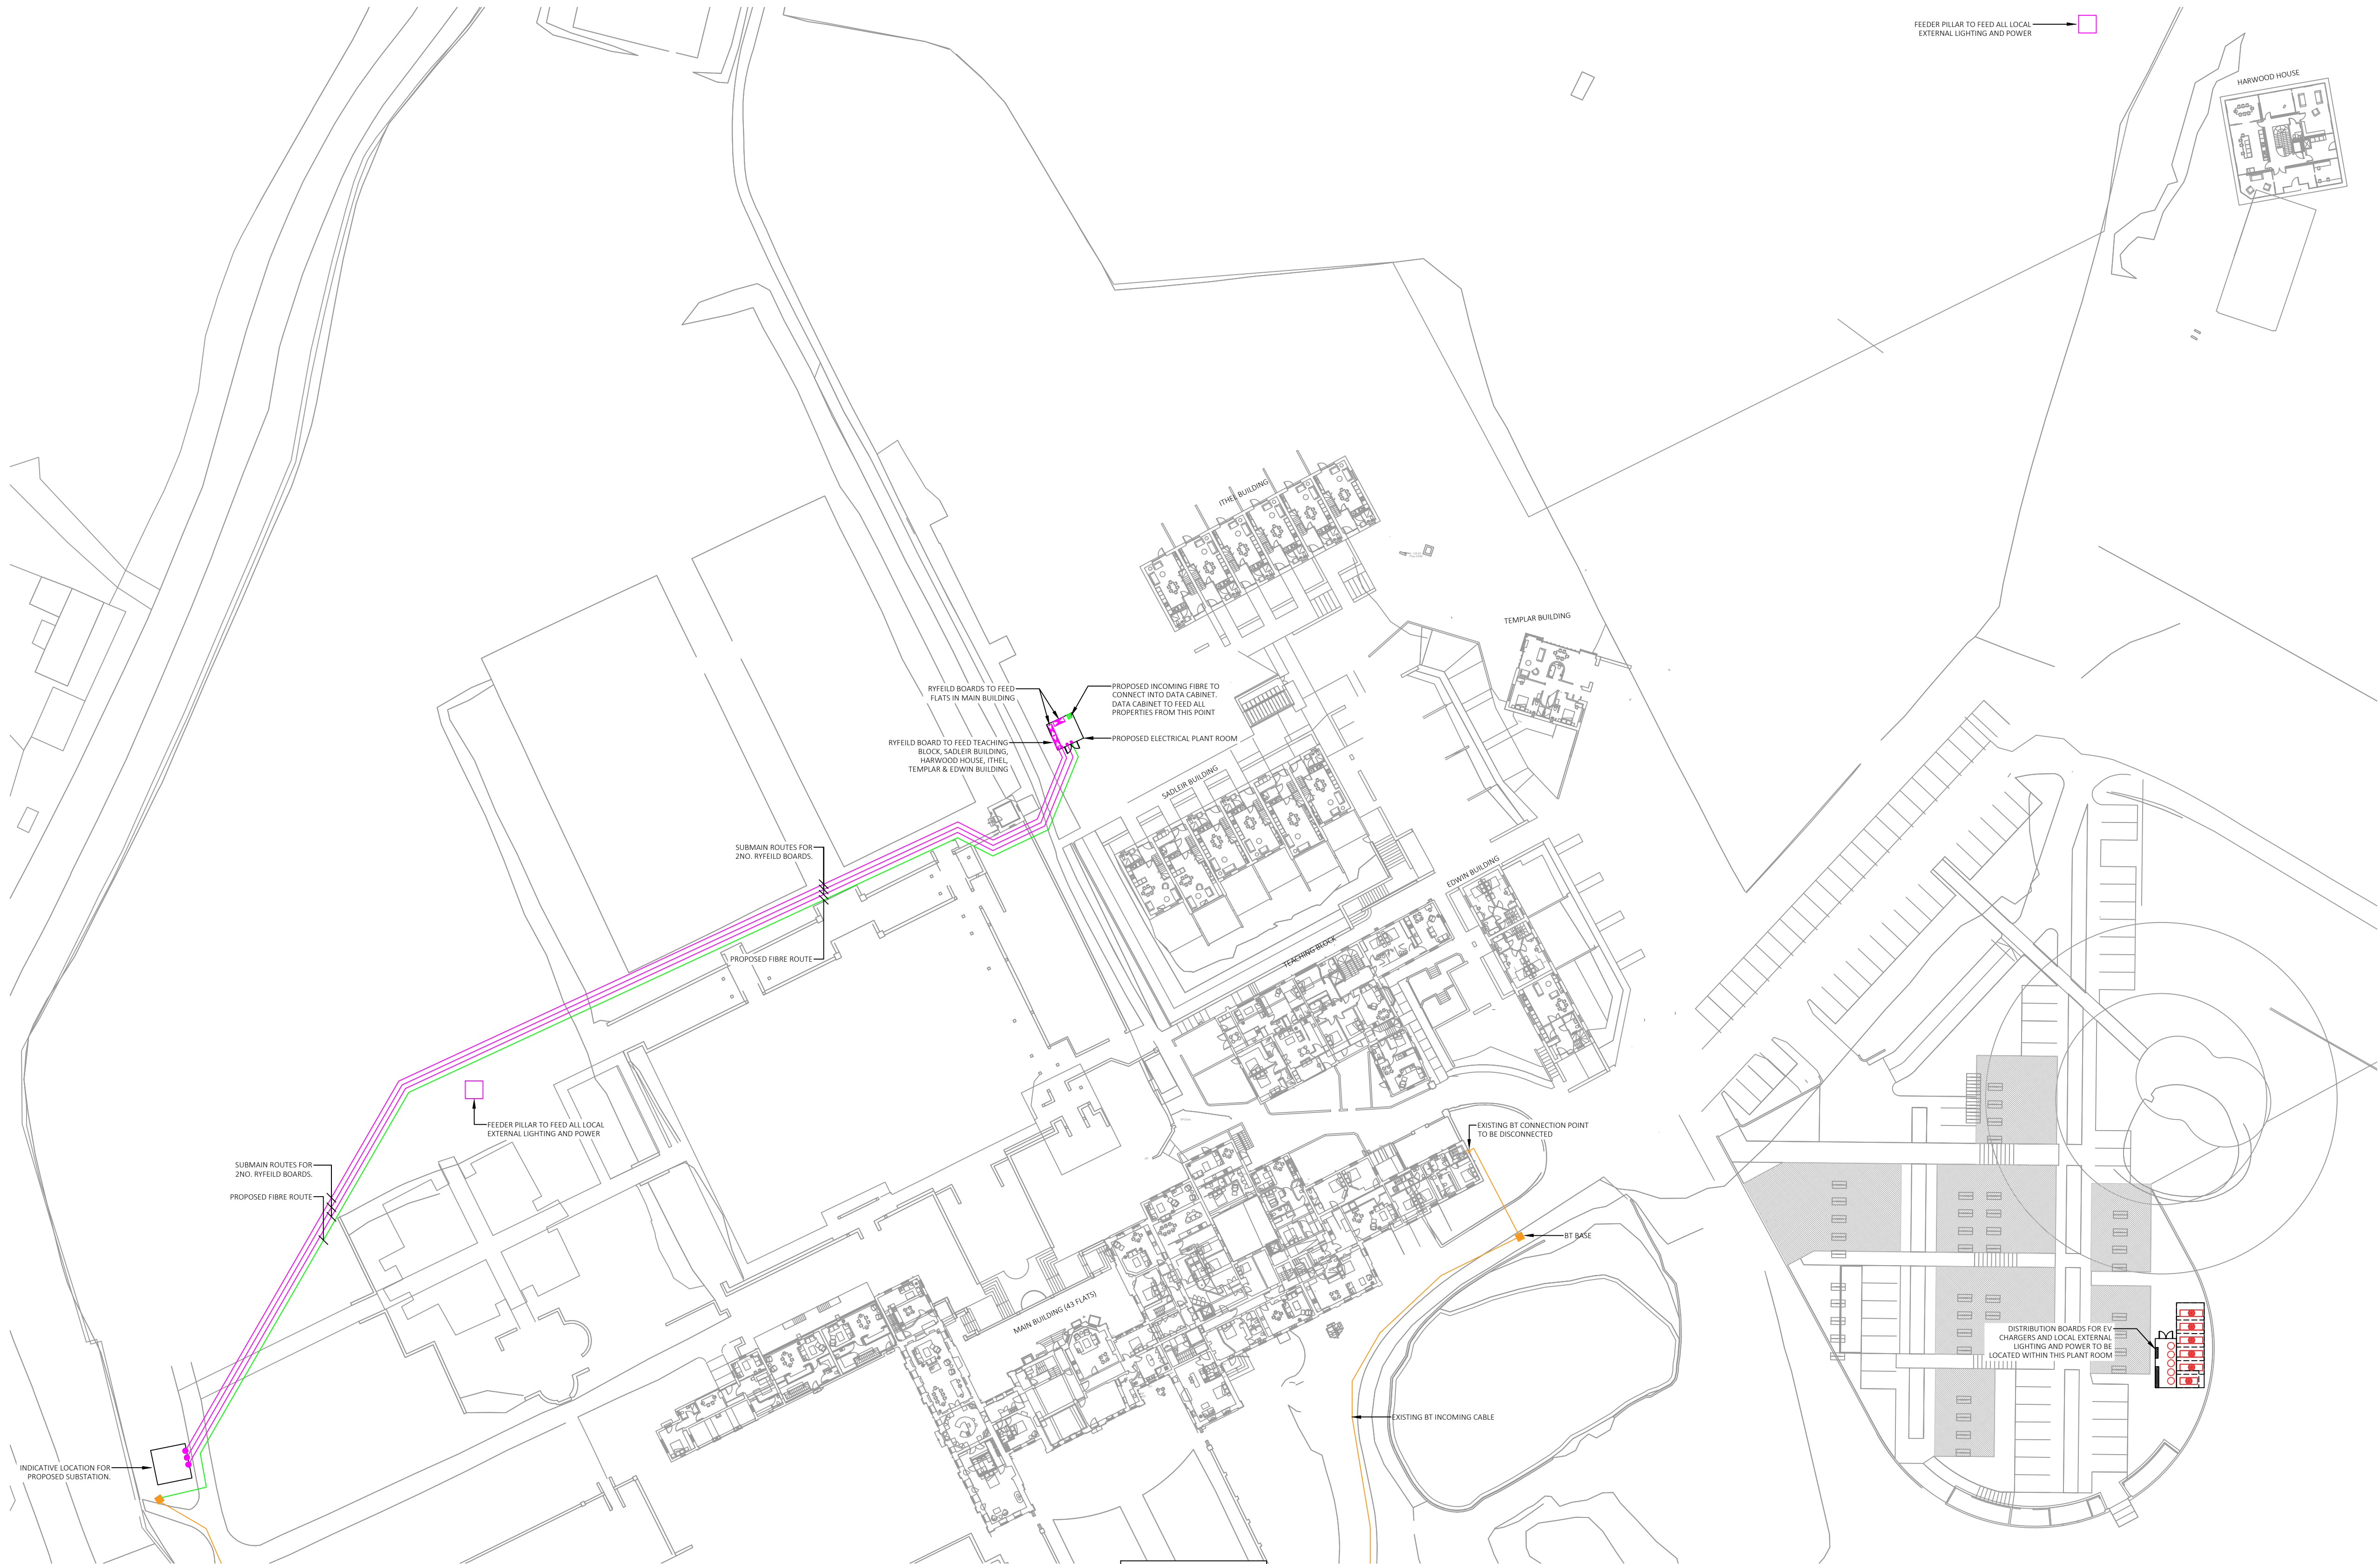

DRAWING CONTINUATION -
11951-CBG-XX-SP-DR-E-90002

PO2	PRELIMINARY ISSUE	MM	JCL	GMW	19.07.2024
PO1	PRELIMINARY ISSUE	MM	JCL	GMW	28.06.2024
REV	AMENDMENTS	DRAWN	CHECKED	APPROVED	DATE
CLIENT STUDIO CULLINAN AND BUCK ARCHITECTS LTD					
PROJECT TEMPLE DINSELY					
TITLE PROPOSED ELECTRICAL SITE PLAN - SHEET 1 OF 2					
DRAWING NUMBER 11951-CBG-XX-SP-DR-E-90001		SCALE 1:500@A1		 www.cbgs.com OXFORD LONDON T:01865 864500 T:020 7387 4175 ©CBG Consultants Ltd	
STATUS PRELIMINARY		REVISION P02			
		DO NOT SCALE			