


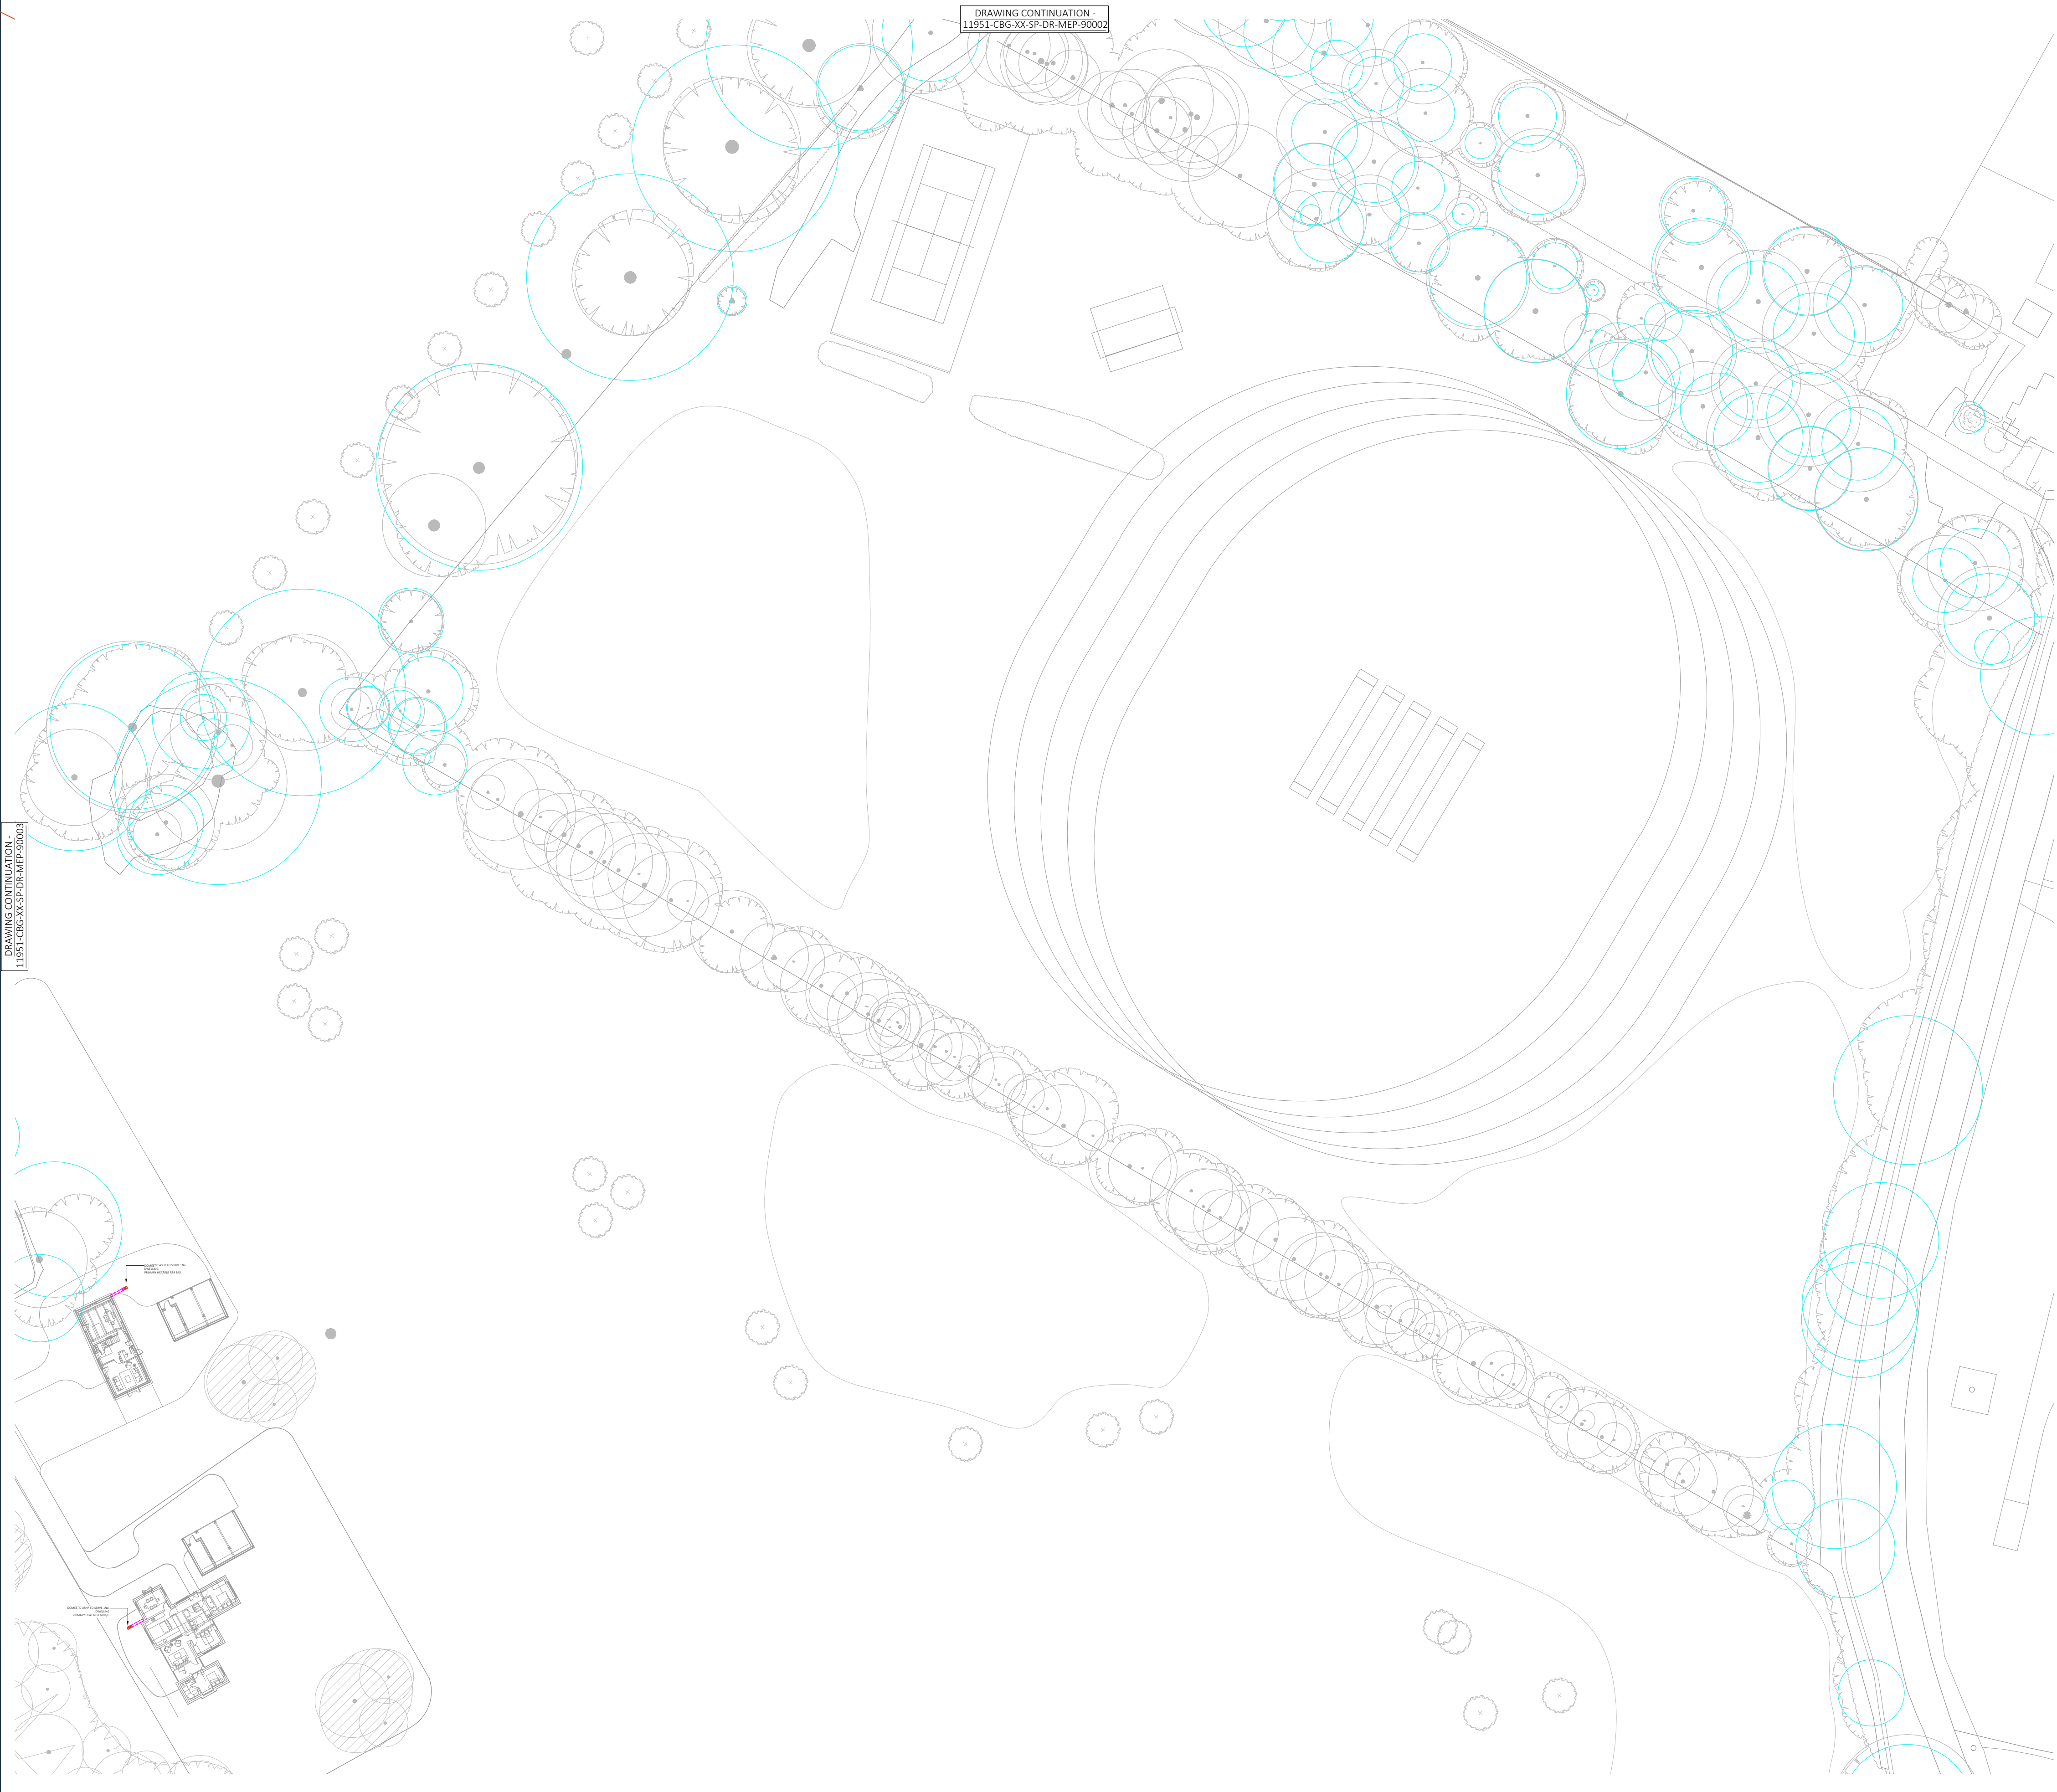

DRAWING CONTINUATION -
11951-CBG-XX-SP-DR-MEP-90002

DRAWING CONTINUATION -
11951-CBG-XX-SP-DR-MEP-90003

These details are confidential to illustrate the engineering services only for the purpose intended. Arrange to suit current architectural and structural details which may vary to some degree from these details. This drawing must be viewed and printed using Adobe Acrobat Version 9.0 or above when using as a PDF format.
Do not scale from this drawing in either paper or digital format. To check the drawing has been printed at the intended scale this bar should be 25mm long at A3, 50mm long at A1 and 75mm long at A0.

- Notes
1. THIS DRAWING SHOULD BE READ IN CONJUNCTION WITH ALL OTHER CONTRACT DOCUMENTATION.
 - 2.



KEY - SITE PLAN

LEGEND	
PRIMARY HEATING FLOW PIPEWORK	
PRIMARY HEATING RETURN PIPEWORK	
ASHP MAIN F&R PIPEWORK	
LOW LEVEL PIPEWORK	
CEILING VOID PIPEWORK	
BELOW GROUND PIPEWORK	
TYP - DOMESTIC ASHP	

PO2	PRELIMINARY ISSUE - ASHP PLANT MOVED INTO CAR PARK	RK	CT	GMW	19.07.2024
PO1	PRELIMINARY ISSUE	RK	CT	GMW	02.07.24
REV	AMENDMENTS	DRAWN	CHECKED	APPROVED	DATE
CLIENT STUDIO CULLINAN AND BUCK ARCHITECTS LTD					
PROJECT TEMPLE DINSLLEY					
TITLE PROPOSED SITE PLAN - SHEET 4 OF 4					
DRAWING NUMBER 11951-CBG-XX-SP-DR-MEP-90004		SCALE 1:500@A1			
STATUS PRELIMINARY		REVISION PO2			
		DO NOT SCALE			

www.cbgc.com
OXFORD
T:01865 864500

LONDON
T:020 7387 4175
©CBG Consultants Ltd