

PRELIMINARY ISSUE

Notes

- 1 This drawing is to be read in conjunction with the Drainage Layout.
- 2 All private drainage works to be constructed in accordance with the latest edition of the Building Regulations part H (Drainage & Waste Disposal) and to BSEN752.
- 3 Soakaway's to be constructed a minimum of 5.0m and deep borehole soakaway 10.0m from any proposed buildings or existing structures.
- 4 **IMPORTANT NOTE:**
The actual depth of the soakaway boreholes are to be determined following on site investigation works.

The level of the bentonite seal shall be advised by an appropriately qualified geotechnical engineer.

P1 Preliminary Issue for stage 4 23.01.25

Rev	Description	Date
-----	-------------	------

Status:

Stage 4

Scale :	NTS		
Date :	Aug 2023	Checked:	Approved:
Drawn :	IDL	BM	PT

Title :

Drainage Details
Sheet 3

Project :

Baldock Street, Royston


Drg. No:	Rev:	File Ref:	1177-07-DE
LSE-2904-04-DE-212	P1	Plot Ref:	LSE-2904-04-DE-212

Suite 44
Harborough Innovation Centre
Airfield Business Park, Leicester Road
Market Harborough, Leicestershire, LE16 7WB
Tel: 01858 411570
Email: info@infrades.co.uk URL: www.infrades.co.uk



INFRASTRUCTURE DESIGN LTD
EST 2000
working for

McCARTHY STONE
Life, well lived

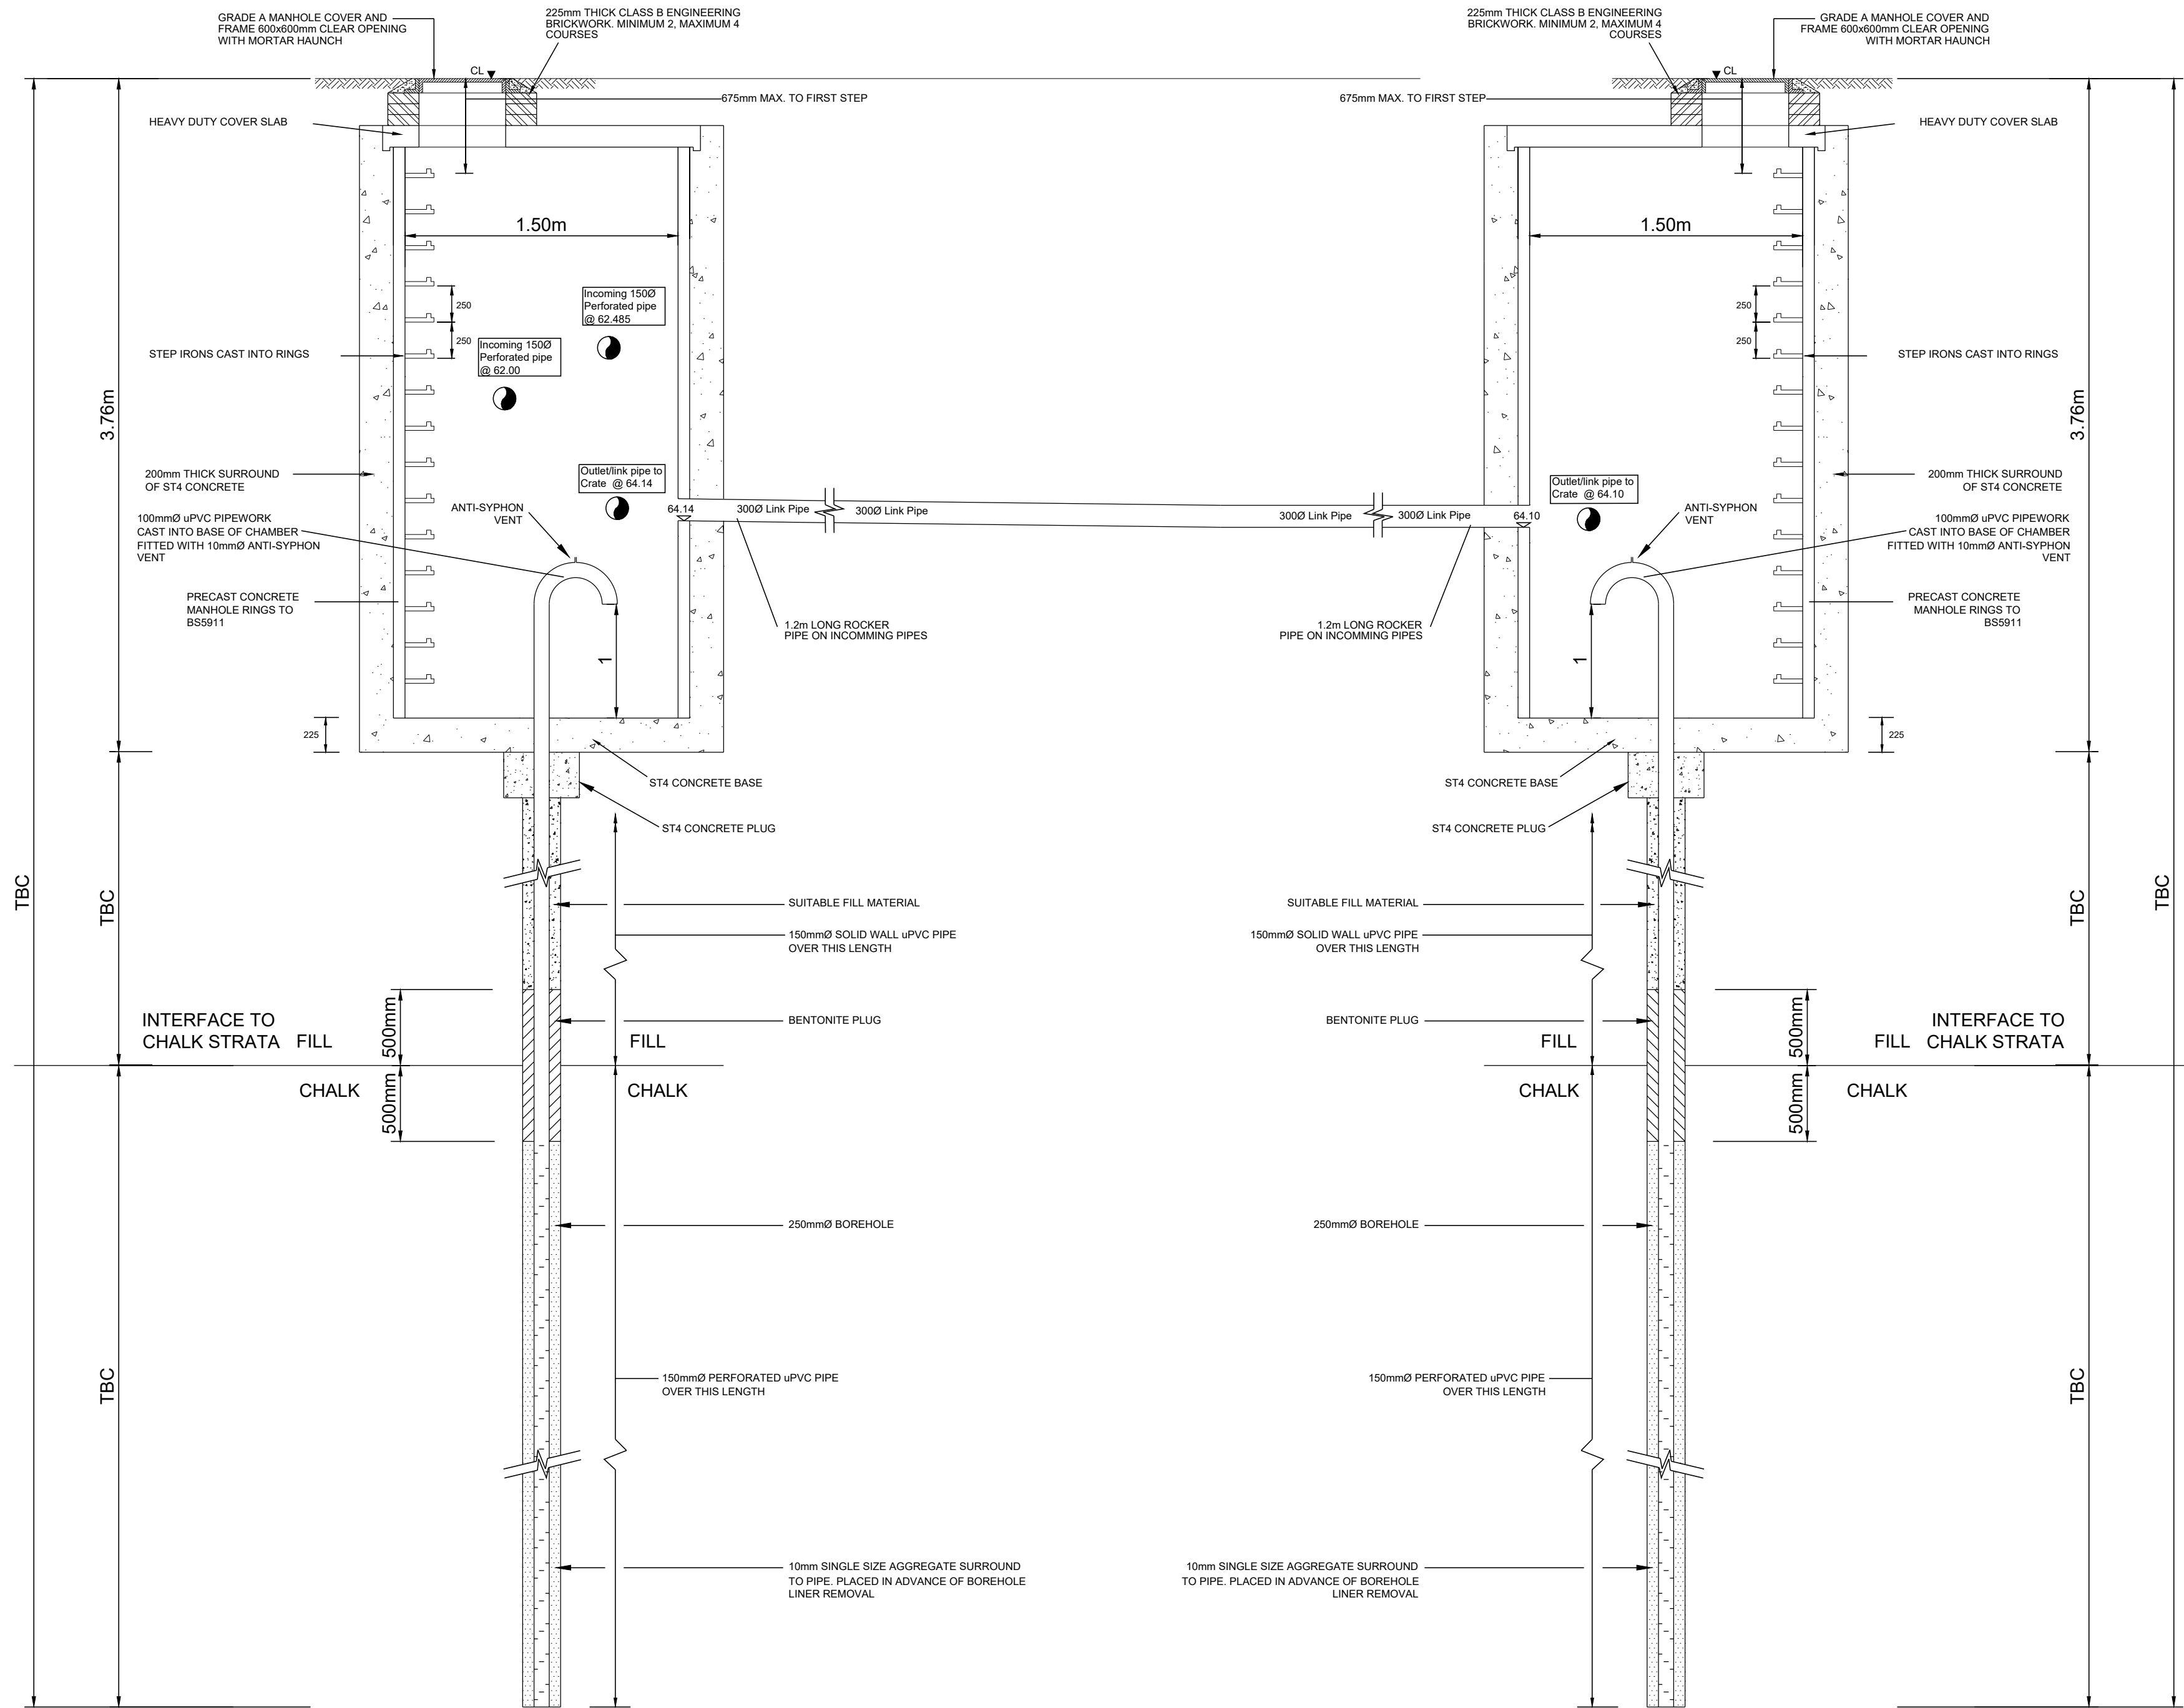

**BORE HOLE SOAKAWAY
S13**

**BORE HOLE SOAKAWAY
S14**