


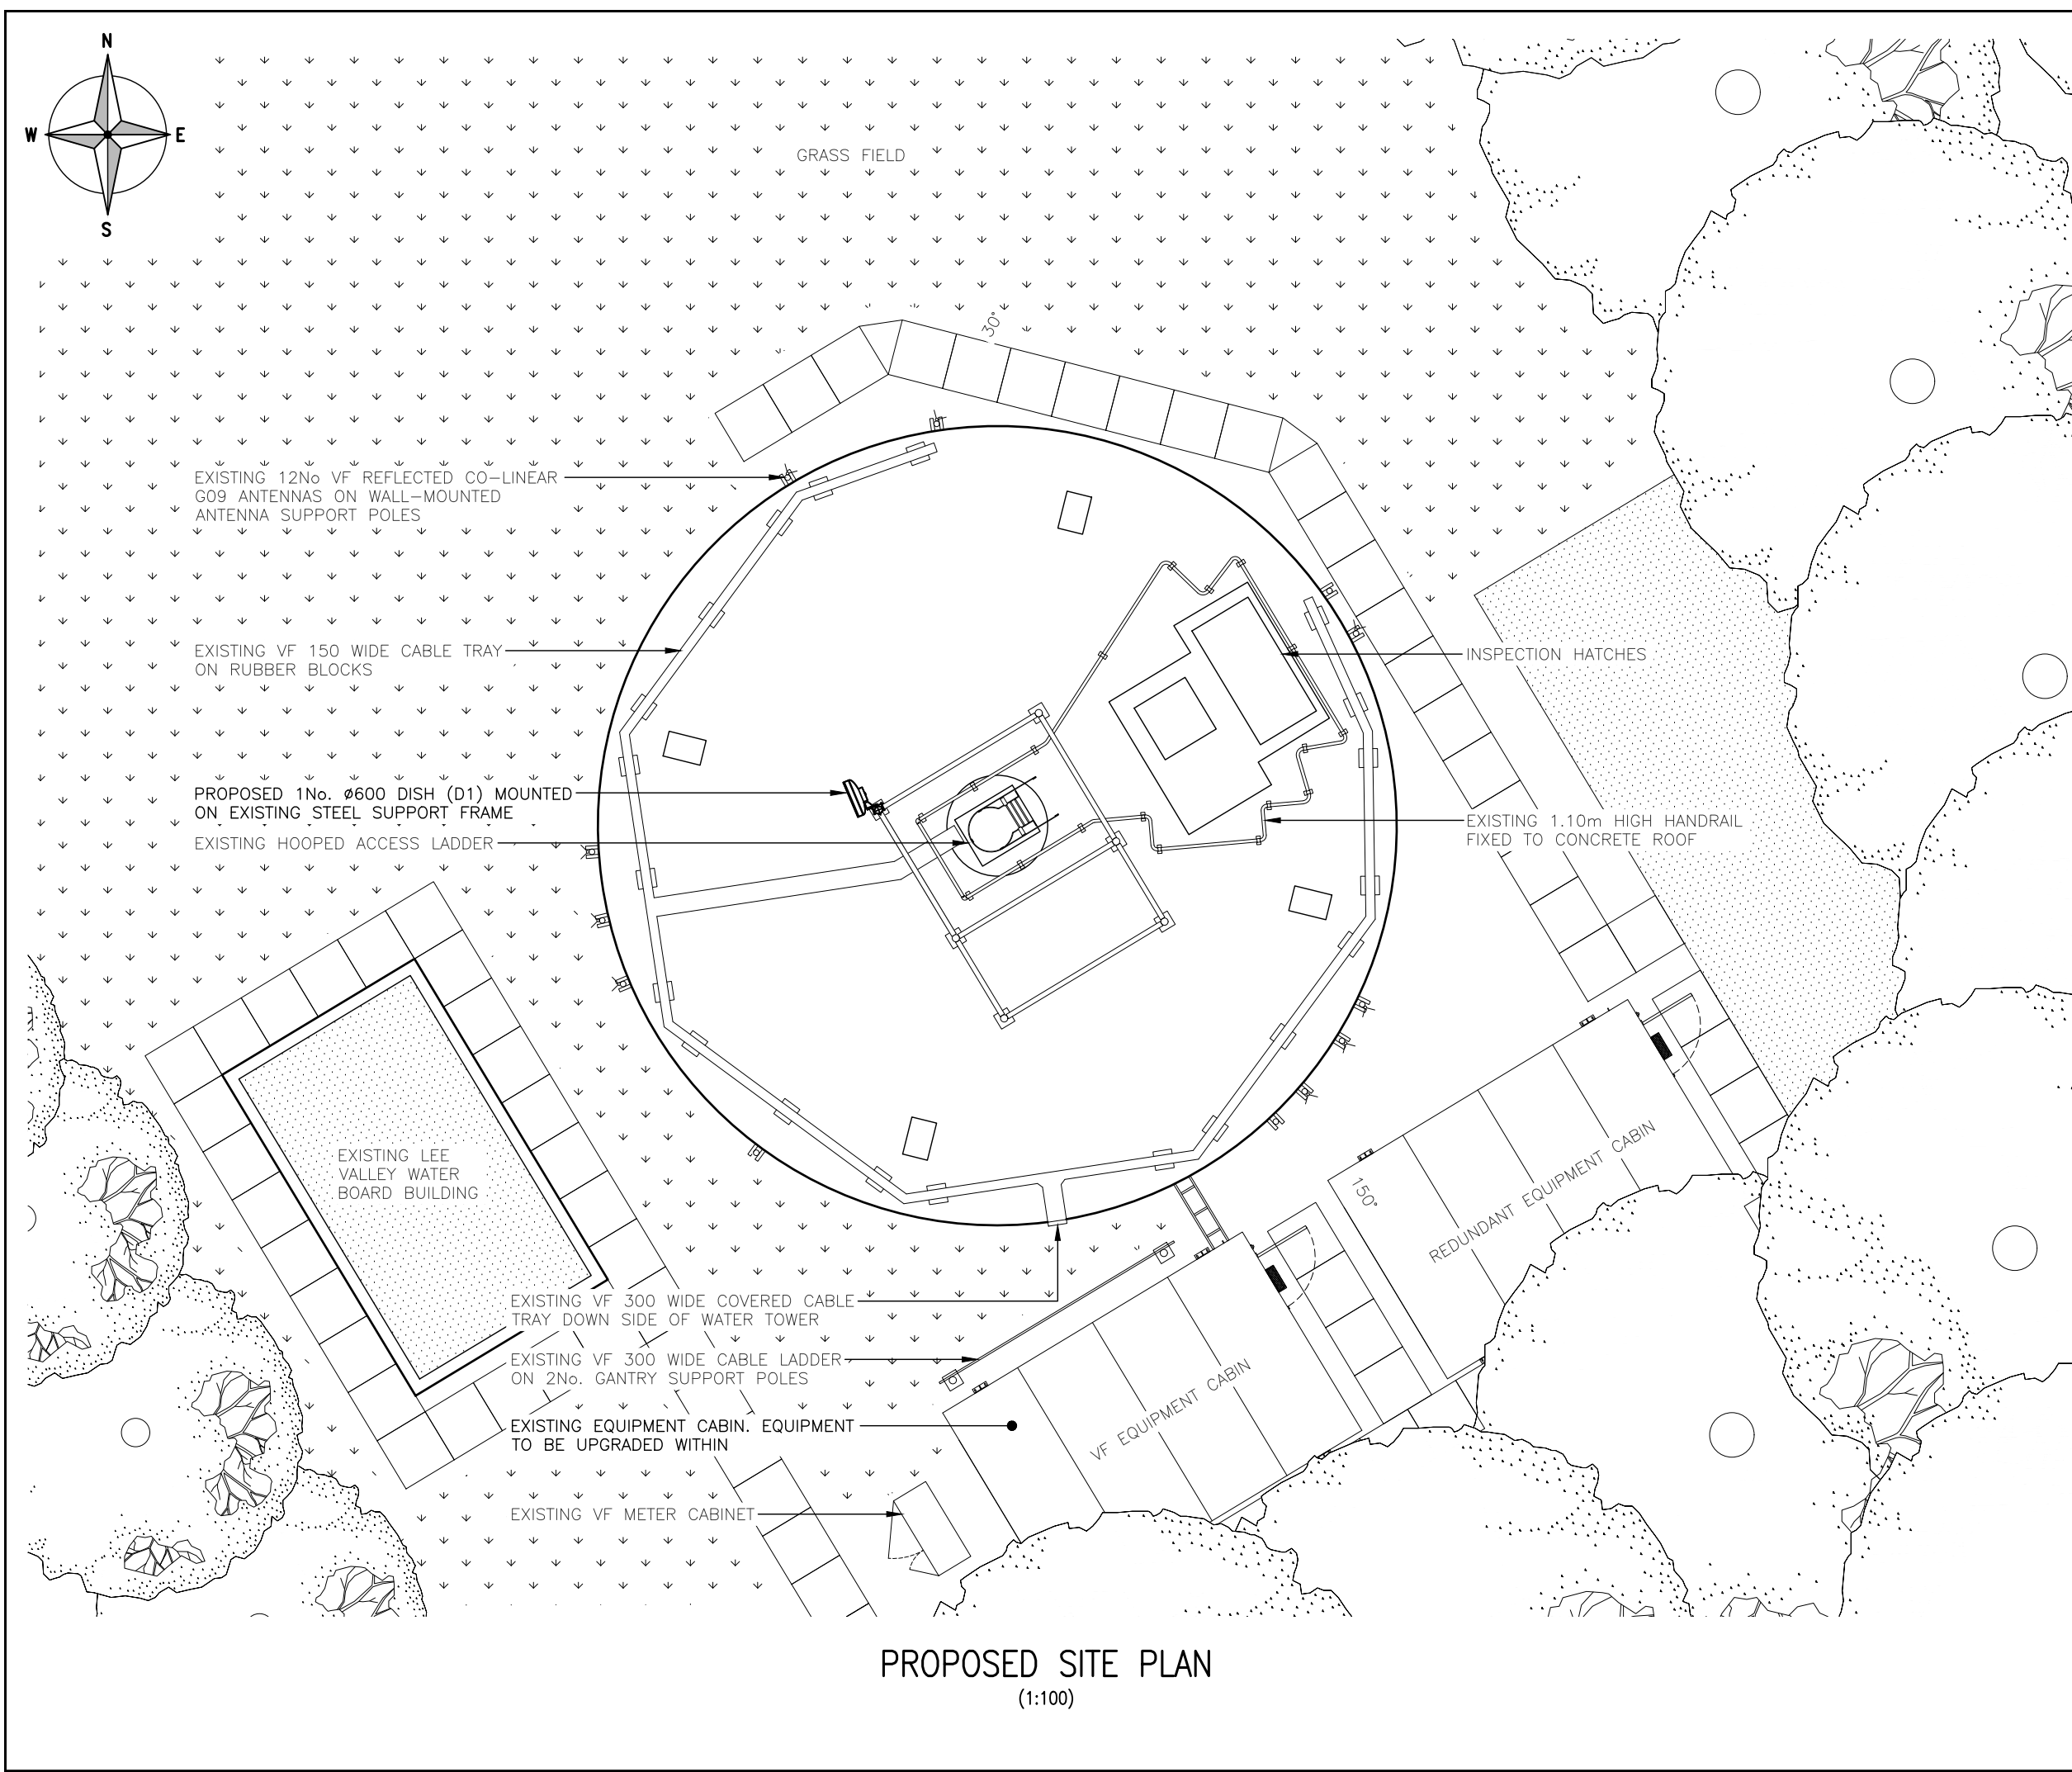

PROPOSED SITE PLAN
(1:100)

ALL DIMENSIONS ARE IN mm UNLESS NOTED OTHERWISE

N.G.R | E: 533210 N: 237230

NOTES:

A	Issued for Approval	GJ	MS	XXXXXX
REV	MODIFICATION	BY	CH	DATE

**Clarke Telecom**
Second Floor, Unit C
Northampton Road
Manchester M40 5BP
Tel: 0161 785 4500
Fax: 0161 785 4501
Web: www.clarke-telecom.com

 **cornerstone**
MICROWAVE ADDITION

Cell Name	Opt.
THERFIELD	—

Cell ID No		
CTIL	VM02	VF
107828_26	N/A	182

Site Address / Contact Details		
LEE VALLEY WATER BOARD THERFIELD HERTFORDSHIRE SG8 9TT		

Drawing Title: PROPOSED SITE PLAN				
Purpose of issue: PLANNING				Dwg Rev:
Drawing Number: 200				A
Surveyed By: MS		Original Sheet Size: A3		Pack Issue:
Drawn: GJ	Date: XXXXXX	Checked: MS	Date: XXXXXX	A