
 


SITE LOCATION

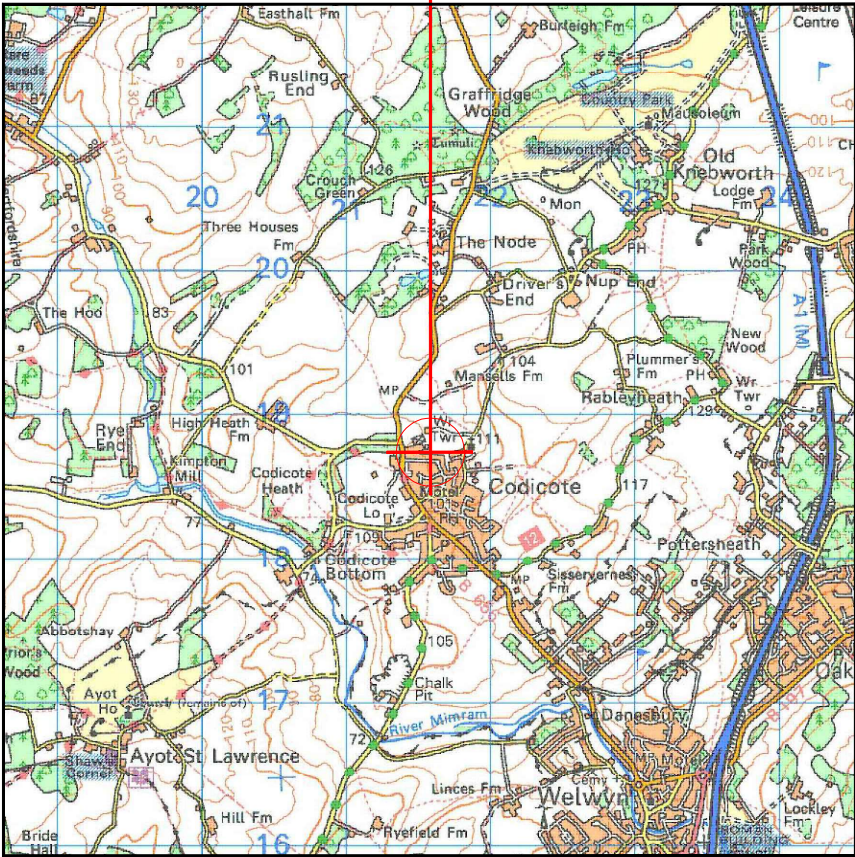

Reproduced by permission of Ordnance Survey on behalf of the Controller of His Majesty's Stationery Office All rights reserved. © Crown Copyright licence no. A152065A0001


SITE AREA PLAN



SITE PHOTOGRAPH



218700

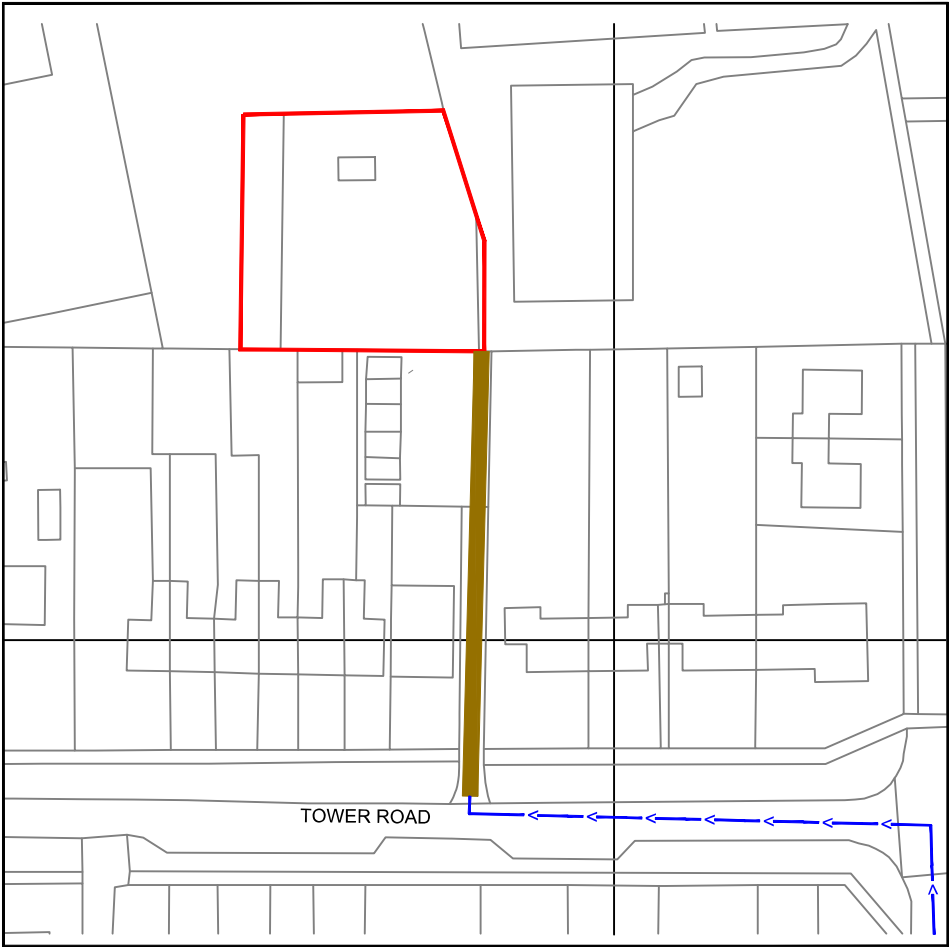


Reproduced by permission of Ordnance Survey on behalf of the Controller of His Majesty's Stationery Office All rights reserved. © Crown Copyright licence no. A152065A0001

NGR E: 521563 N: 218758

W3W: affair.grape.aspect

 SITE LOCATION PLAN



NOTES:

1. ALL DIMENSIONS IN MM UNLESS OTHERWISE NOTED.

DIRECTIONS TO SITE: EXIT A1(M) AT JUNCTION 7 TAKE THE A602 EXIT TO STEVENAGE. AT LANGLEY SIDINGS INTERCHANGE TAKE THE 3rd EXIT ONTO BROADHALL WAY / A602. AT THE ROUNDBABOUT TAKE THE 2nd EXIT AND STAY ON A602. 0.3mi TO THE NEXT ROUNDBABOUT TAKE THE 3rd EXIT ONTO MONKSWOOD WAY / A602. 0.3mi AT THE NEXT ROUNDBABOUT TAKE THE 1st EXIT ONTO LONDON ROAD / B197. TAKE THE NEXT RIGHT ONTO OLD KNEBWORTH LANE. FOLLOW OLD KNEBWORTH LANE FOT 1.5mi. TURN RIGHT ONTO DRIVERS END LANE FOR 0.7mi. THEN TURN LEFT ONTO B654, FOLLOW FOR 0.7mi. THEN LEFT ONTO TOWER ROAD. THEN TAKE A LEFT TO WATER TOWER SITE.

Demise:



Access Route To Site:



Access Route:



Master:	Project:	Purpose of Issue:	Issue:
M003	3UK 4G Symmetry	Detailed Design	B1
Date:	11.09.25	Revision / Upgrade Description:	
Drawn:	LS	Detail Design - First Issue	
Checked:	JS		
Approved:	GG		
Master:	Project:	Purpose of Issue:	Issue:
M002	3UK 4G Symmetry	Planning	B
Date:	04.06.25	Revision / Upgrade Description:	
Drawn:	LS	First Issue	
Checked:	JS		
Approved:	GG		
Master:	Project:	Purpose of Issue:	Issue:
M001	3UK 4G Symmetry	Planning	A
Date:	01.05.25	Revision / Upgrade Description:	
Drawn:	LS	First Issue	
Checked:	JS		
Approved:	GG		



Hutchison 3G UK Limited
Green Park, 450 Longwater Avenue
Reading, RG30 3UR
Tel: 01628 765 000
Fax: 01628 765 001

H3G Base Station Information line:
0845 6043000
Available 8am-8pm Monday to Friday

Design Consultant:



WHP Telecoms
Unit 1 Maple Park,
Low Fields Avenue, Leeds
LS12 6HH

Tel: 01133023550
e-mail: info@whptelecoms.com

Site Name:
CODICOTE WATER TOWER

Site ID:
1206014

Address:
TOWER ROAD
CODICOTE
HERTFORDSHIRE
SG4 8XH


Title:
002 SITE LOCATION PLAN

Project:
3UK 4G SYMMETRY

Purpose of Issue:
DETAILED DESIGN

EE Cell ID:	MBNL Cell ID:	H3G Cell ID:
16939	NHE068	SG0387

File name:
1206014_NHE068_16939_SG0387_H3G_4G_SYM_DD_B1

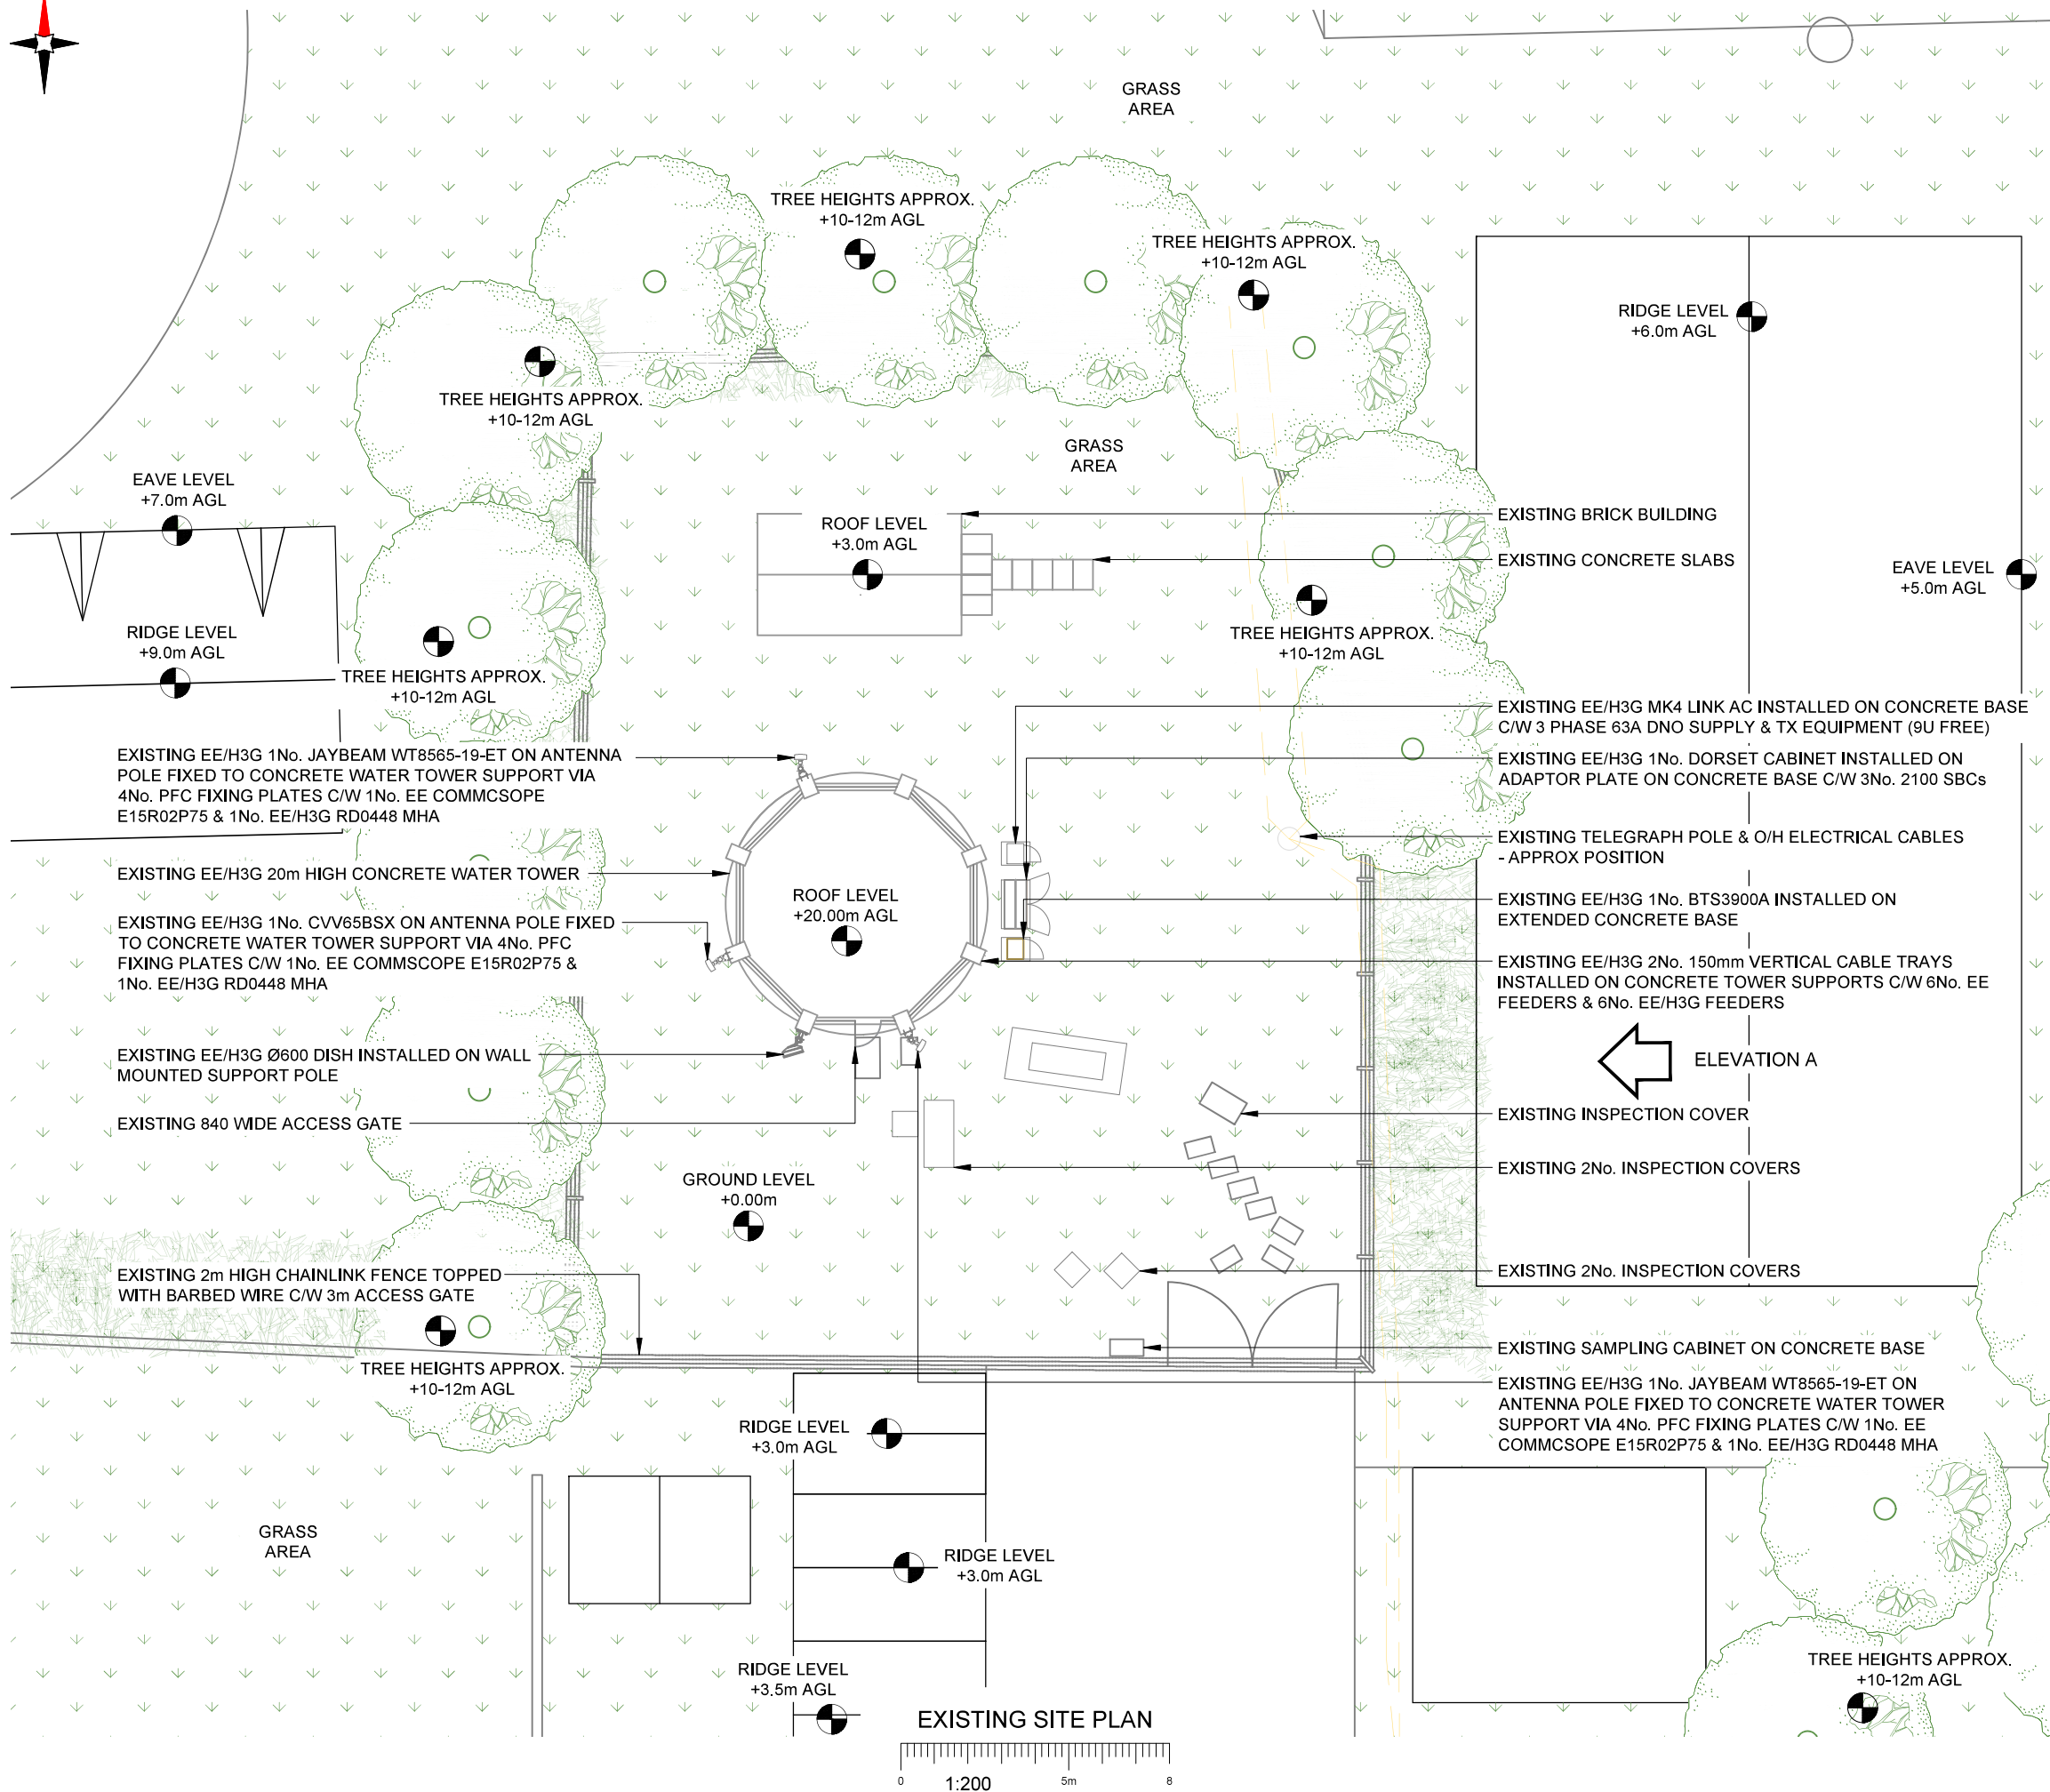

1. ALL DIMENSIONS IN MM UNLESS OTHERWISE NOTED.

Master:	Project:		Purpose of Issue:		Issue:
M003	3UK 4G Symmetry		Detailed Design		B1
Date:	11.09.25	Revision / Upgrade Description:			
Drawn:	LS	Detail Design - First Issue			
Checked:	JS				
Approved:	GG				
Master:	Project:		Purpose of Issue:		Issue:
M002	3UK 4G Symmetry		Planning		B
Date:	04.06.25	Revision / Upgrade Description:			
Drawn:	LS	First Issue			
Checked:	JS				
Approved:	GG				
Master:	Project:		Purpose of Issue:		Issue:
M001	3UK 4G Symmetry		Planning		A
Date:	01.05.25	Revision / Upgrade Description:			
Drawn:	LS	First Issue			
Checked:	JS				
Approved:	GG				



Hutchison 3G UK Limited
Green Park, 450 Longwater Avenue
Reading, RG30 3UR
Tel: 01628 765 000
Fax: 01628 765 001

H3G Base Station Information line:
0845 6043000
Available 8am-8pm Monday to Friday

Design Consultant:



WHP Telecoms
Unit 1 Maple Park,
Low Fields Avenue, Leeds
LS12 6HH

Tel: 01133023550
e-mail: info@whptelecoms.com

Site Name: CODICOTE WATER TOWER

Site ID: 1206014

Address:

TOWER ROAD
CODICOTE
HERTFORDSHIRE
SG4 8XH


Title: 100 EXISTING SITE PLAN

Project:	3UK 4G SYMMETRY
----------	-----------------

Purpose of Issue:	DETAILED DESIGN
-------------------	-----------------

EE Cell ID: 16939	MBNL Cell ID: NHE068	H3G Cell ID: SG0387
-----------------------------	--------------------------------	-------------------------------

File name:	1206014 NHE068 16939 SG0387 H3G 4G SYM DD B1
------------	--

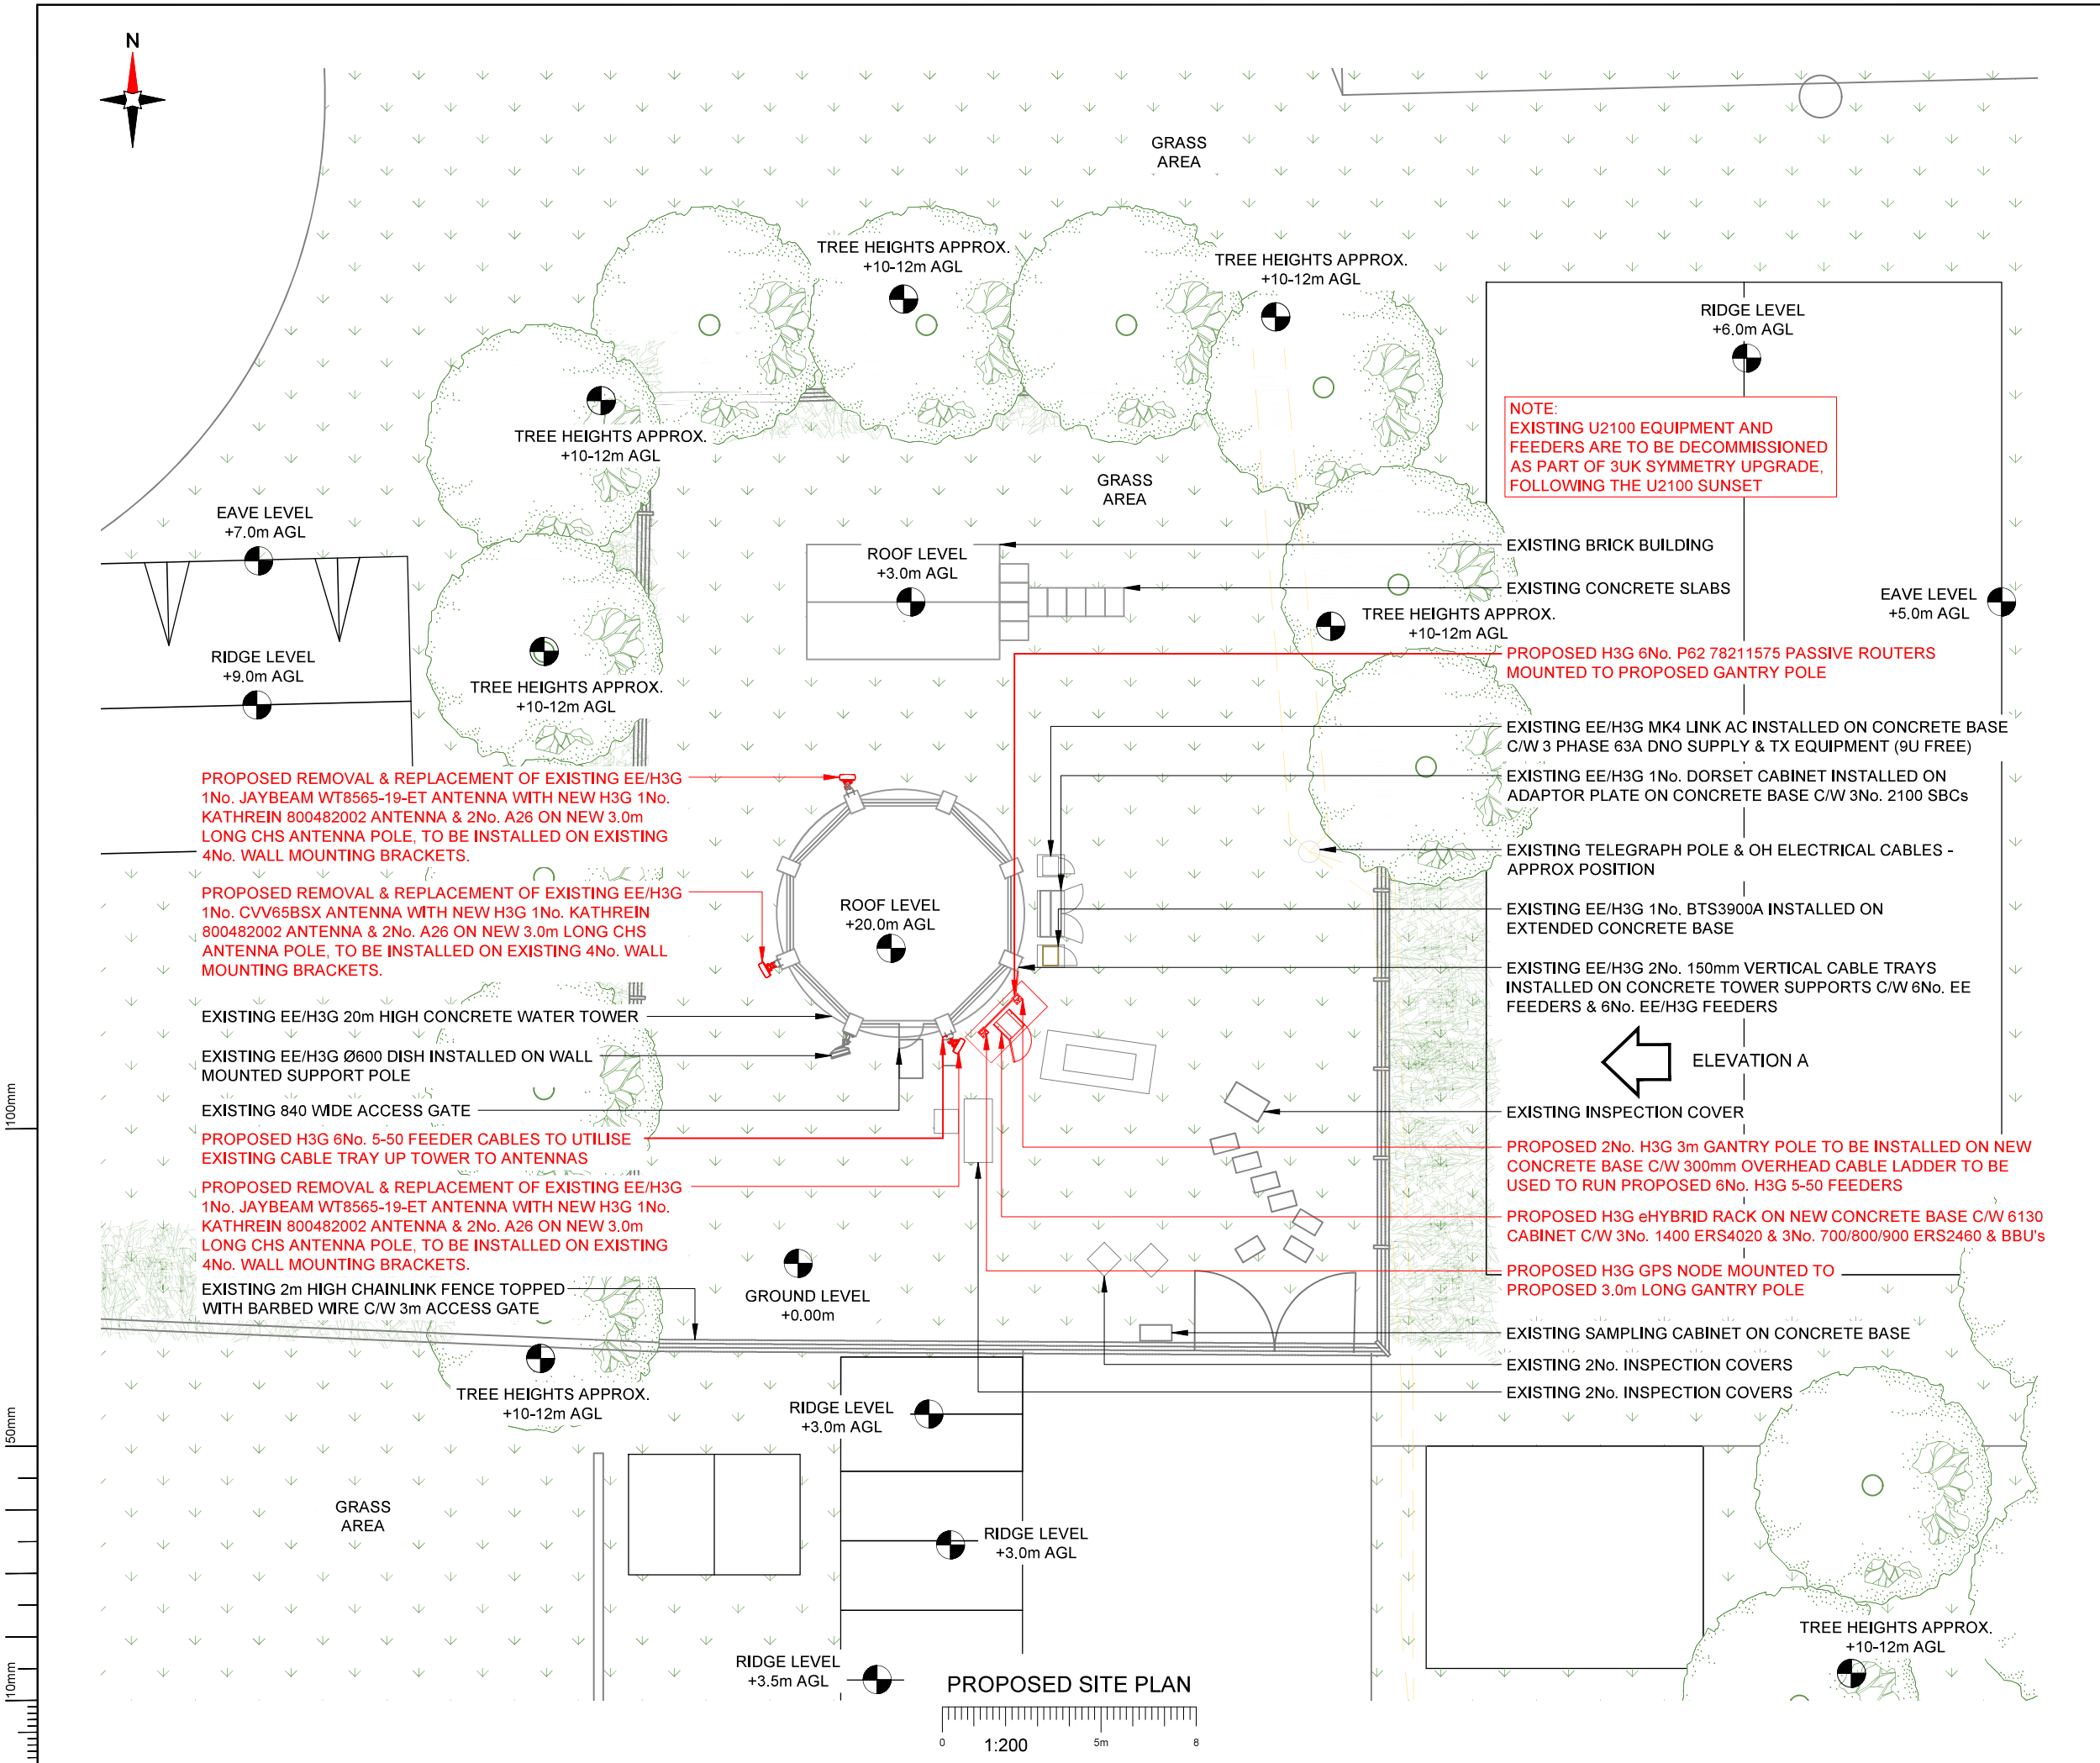

- NOTES:
- ALL DIMENSIONS IN MM UNLESS OTHERWISE NOTED.

Master:	Project:		Purpose of Issue:	Issue:
M003	3UK 4G Symmetry		Detailed Design	B1
Date:	11.09.25	Revision / Upgrade Description:		
Drawn:	LS	Detail Design - First Issue		
Checked:	JS			
Approved:	GG			
Master:	Project:		Purpose of Issue:	Issue:
M002	3UK 4G Symmetry		Planning	B
Date:	04.06.25	Revision / Upgrade Description:		
Drawn:	LS	First Issue		
Checked:	JS			
Approved:	GG			
Master:	Project:		Purpose of Issue:	Issue:
M001	3UK 4G Symmetry		Planning	A
Date:	01.05.25	Revision / Upgrade Description:		
Drawn:	LS	First Issue		
Checked:	JS			
Approved:	GG			



Hutchison 3G UK Limited
Green Park, 450 Longwater Avenue
Reading, RG30 3UR
Tel: 01628 765 000
Fax: 01628 765 001

H3G Base Station Information line:
0845 6043000
Available 8am-8pm Monday to Friday

Design Consultant:



WHP Telecoms
Unit 1 Maple Park,
Low Fields Avenue, Leeds
LS12 6HH

Tel: 01133023550
e-mail: info@whptelecoms.com

Site Name: CODICOTE WATER TOWER

Site ID: 1206014

Address: TOWER ROAD
CODICOTE
HERTFORDSHIRE
SG4 8XH


Title: 150 PROPOSED SITE PLAN

Project: 3UK 4G SYMMETRY


Purpose of Issue: DETAILED DESIGN

EE Cell ID:	MBNL Cell ID:	H3G Cell ID:
16939	NHE068	SG0387

File name: 1206014_NHE068_16939_SG0387_H3G_4G_SYM_DD_B1

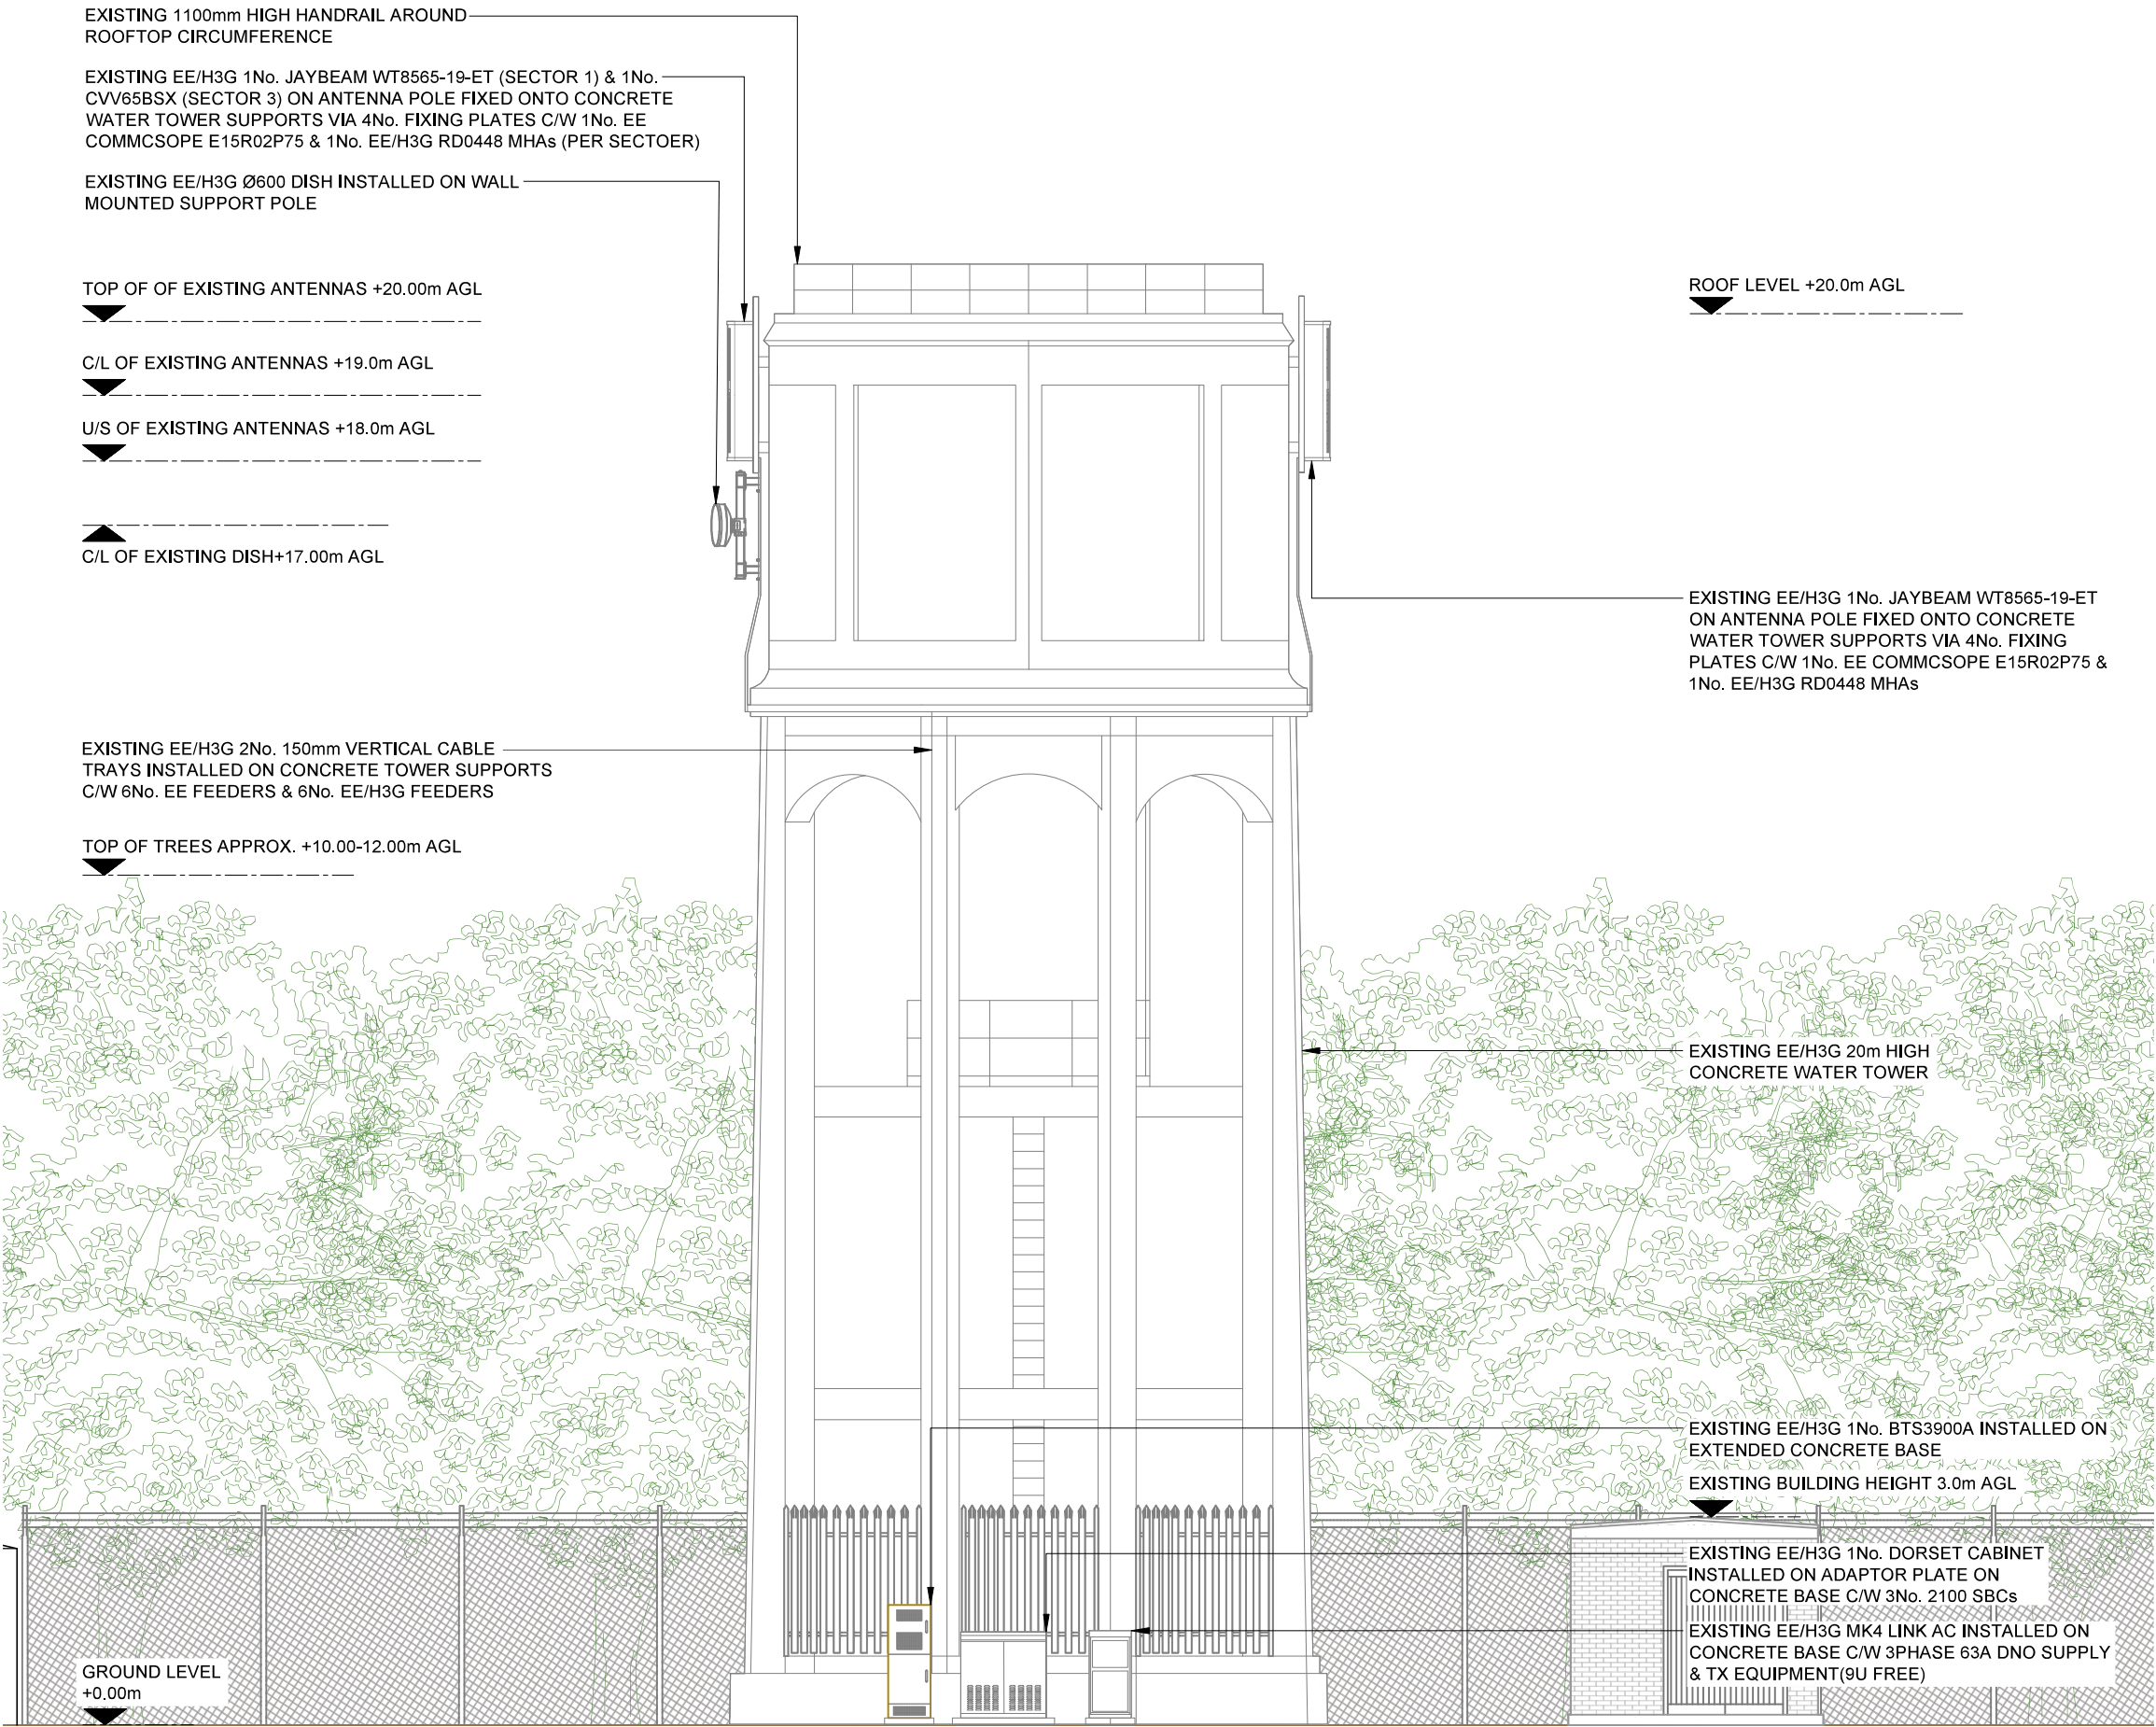

EXISTING SITE ELEVATION A

 

- NOTES:
- ALL DIMENSIONS IN MM UNLESS OTHERWISE NOTED.

Master:	Project:		Purpose of Issue:	Issue:
M003	3UK 4G Symmetry		Detailed Design	B1
Date:	11.09.25	Revision / Upgrade Description:		
Drawn:	LS	Detail Design - First Issue		
Checked:	JS			
Approved:	GG			
Master:	Project:		Purpose of Issue:	Issue:
M002	3UK 4G Symmetry		Planning	B
Date:	04.06.25	Revision / Upgrade Description:		
Drawn:	LS	First Issue		
Checked:	JS			
Approved:	GG			
Master:	Project:		Purpose of Issue:	Issue:
M001	3UK 4G Symmetry		Planning	A
Date:	01.05.25	Revision / Upgrade Description:		
Drawn:	LS	First Issue		
Checked:	JS			
Approved:	GG			



Hutchison 3G UK Limited
Green Park, 450 Longwater Avenue
Reading, RG30 3UR
Tel: 01628 765 000
Fax: 01628 765 001

H3G Base Station Information line:
0845 6043000
Available 8am-8pm Monday to Friday

Design Consultant:



WHP Telecoms
Unit 1 Maple Park,
Low Fields Avenue, Leeds
LS12 6HH

Tel: 01133023550
e-mail: info@whptelecoms.com

Site Name:
CODICOTE WATER TOWER

Site ID:
1206014

Address:
TOWER ROAD
CODICOTE
HERTFORDSHIRE
SG4 8XH


Title:
200 EXISTING SITE ELEVATION

Project:
3UK 4G SYMMETRY


Purpose of Issue:
DETAILED DESIGN

EE Cell ID: 16939	MBNL Cell ID: NHE068	H3G Cell ID: SG0387
----------------------	-------------------------	------------------------

File name:
1206014_NHE068_16939_SG0387_H3G_4G_SYM_DD_B1

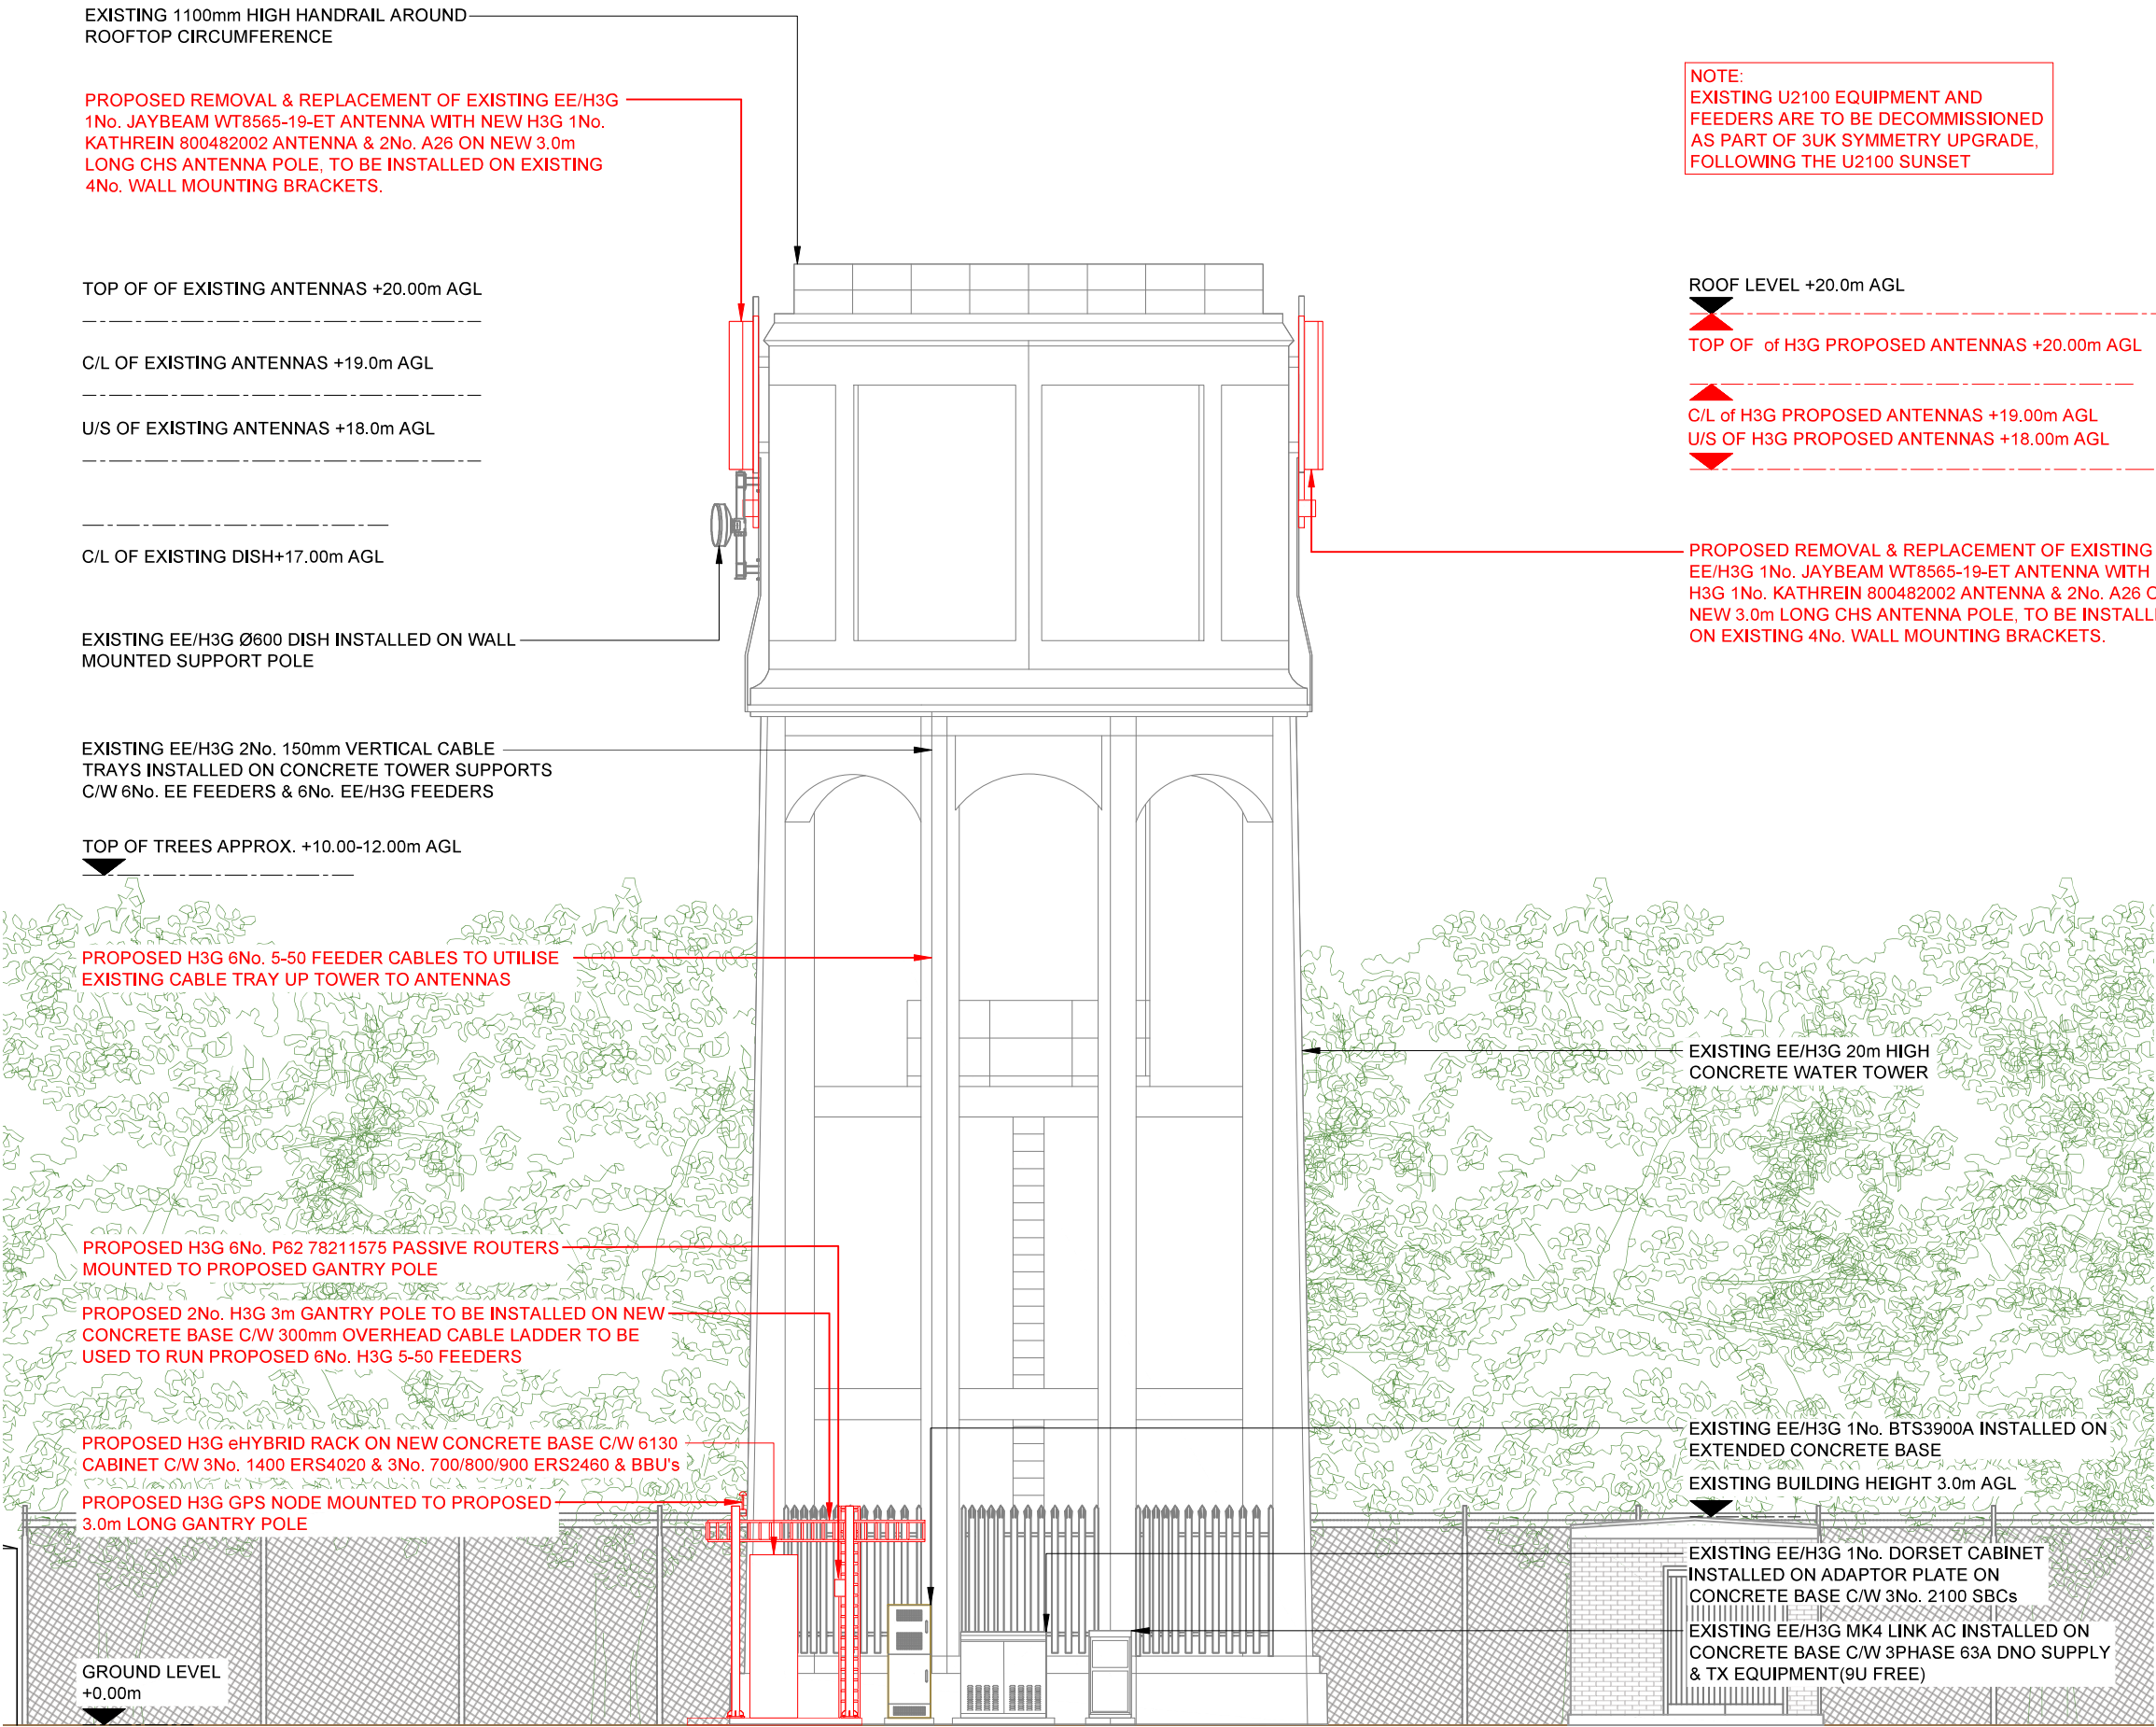

PROPOSED SITE ELEVATION

 

- NOTES:
- ALL DIMENSIONS IN MM UNLESS OTHERWISE NOTED.

Master:	Project:		Purpose of Issue:	Issue:
M003	3UK 4G Symmetry		Detailed Design	B1
Date:	11.09.25	Revision / Upgrade Description:		
Drawn:	LS	Detail Design - First Issue		
Checked:	JS			
Approved:	GG			
Master:	Project:		Purpose of Issue:	Issue:
M002	3UK 4G Symmetry		Planning	B
Date:	04.06.25	Revision / Upgrade Description:		
Drawn:	LS	First Issue		
Checked:	JS			
Approved:	GG			
Master:	Project:		Purpose of Issue:	Issue:
M001	3UK 4G Symmetry		Planning	A
Date:	01.05.25	Revision / Upgrade Description:		
Drawn:	LS	First Issue		
Checked:	JS			
Approved:	GG			



Hutchison 3G UK Limited
Green Park, 450 Longwater Avenue
Reading, RG30 3UR
Tel: 01628 765 000
Fax: 01628 765 001

H3G Base Station Information line:
0845 6043000
Available 8am-8pm Monday to Friday

Design Consultant:



WHP Telecoms
Unit 1 Maple Park,
Low Fields Avenue, Leeds
LS12 6HH

Tel: 01133023550
e-mail: info@whptelecoms.com

Site Name:
CODICOTE WATER TOWER

Site ID:
1206014

Address:
TOWER ROAD
CODICOTE
HERTFORDSHIRE
SG4 8XH

Title:
250 PROPOSED SITE ELEVATION

Project:
3UK 4G SYMMETRY

Purpose of Issue:
DETAILED DESIGN

EE Cell ID: 16939	MBNL Cell ID: NHE068	H3G Cell ID: SG0387
----------------------	-------------------------	------------------------

File name:
1206014_NHE068_16939_SG0387_H3G_4G_SYM_DD_B1