




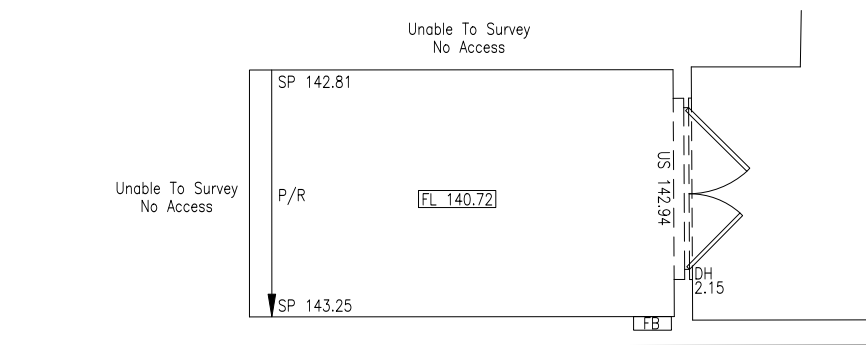


GROUND FLOOR PLAN

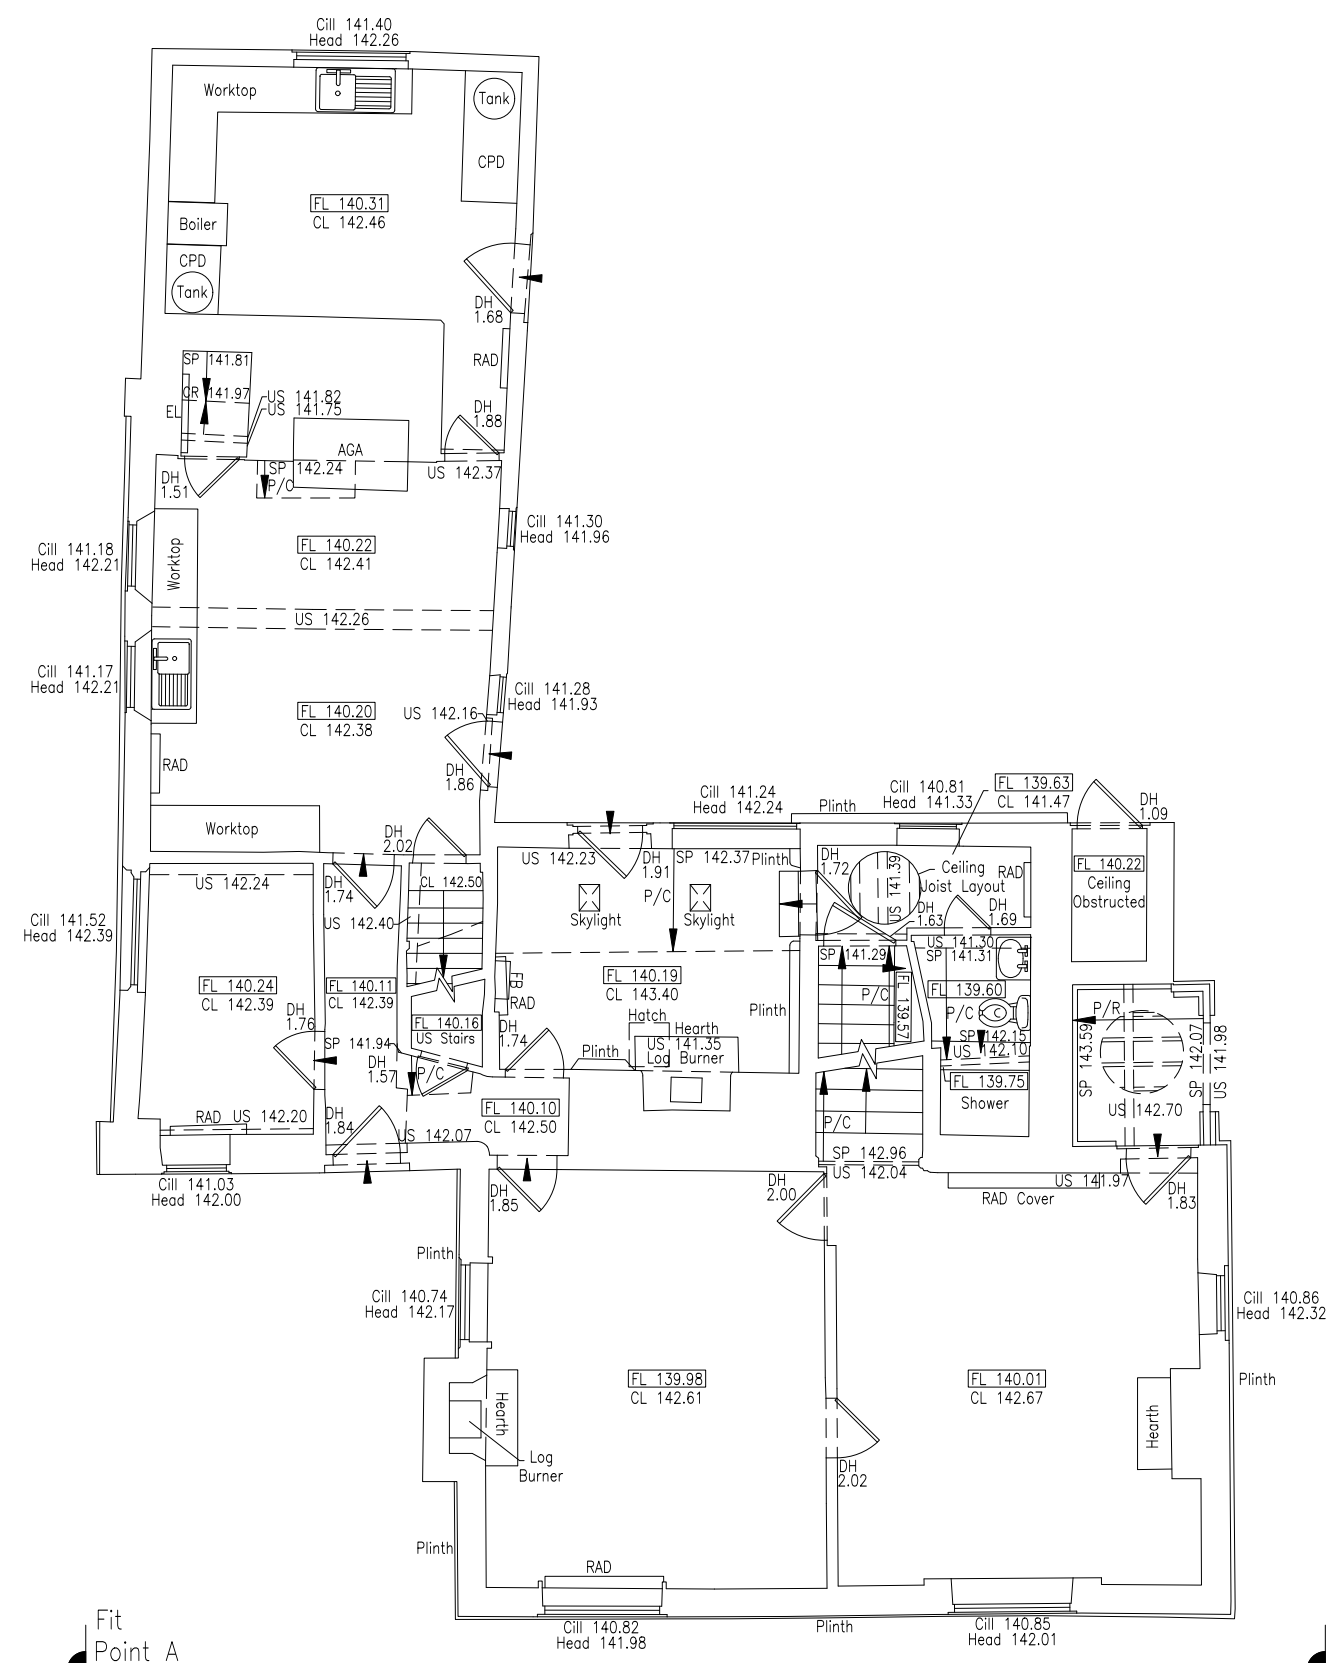


GROUND FLOOR PLAN

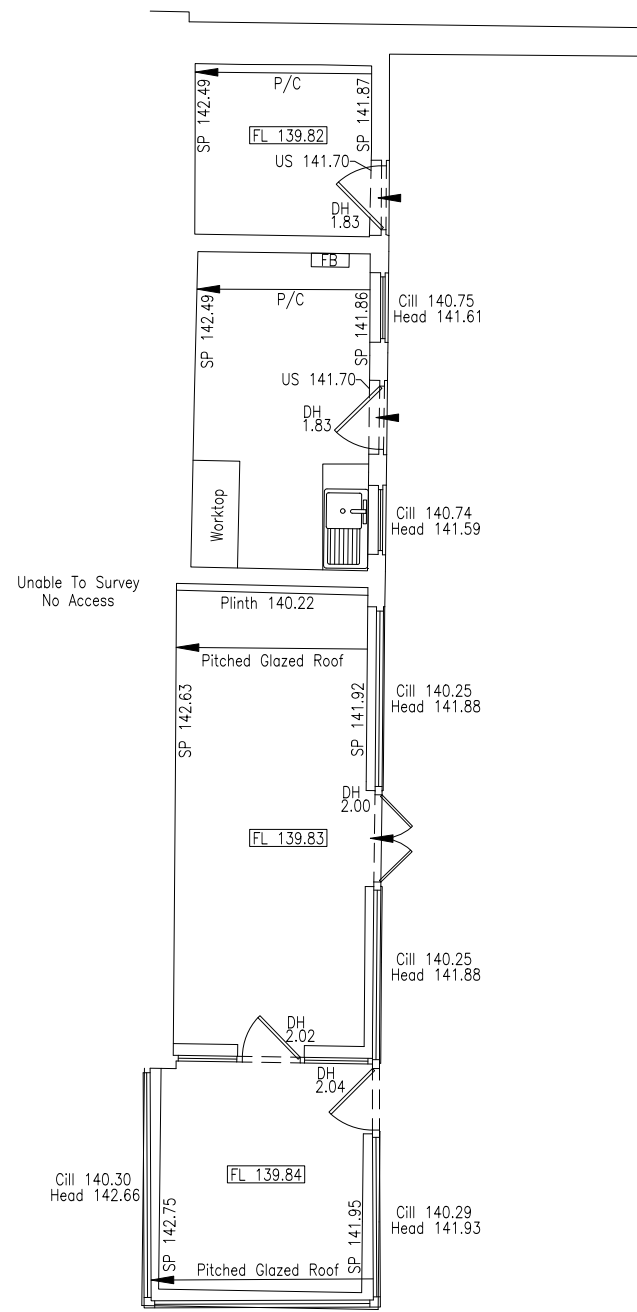


GROUND FLOOR PLAN

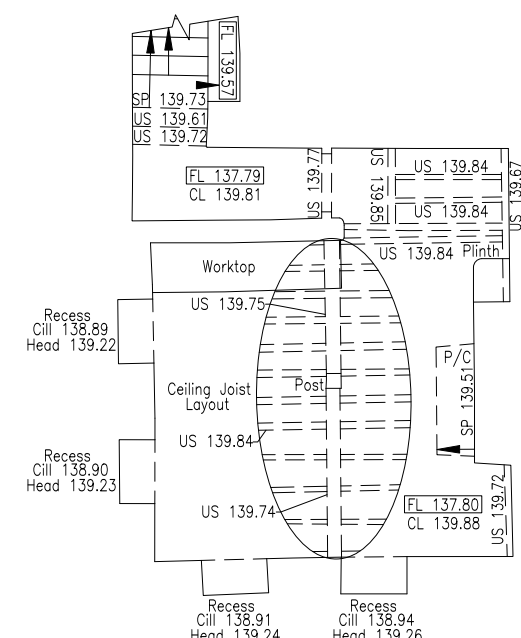

BASEMENT PLAN

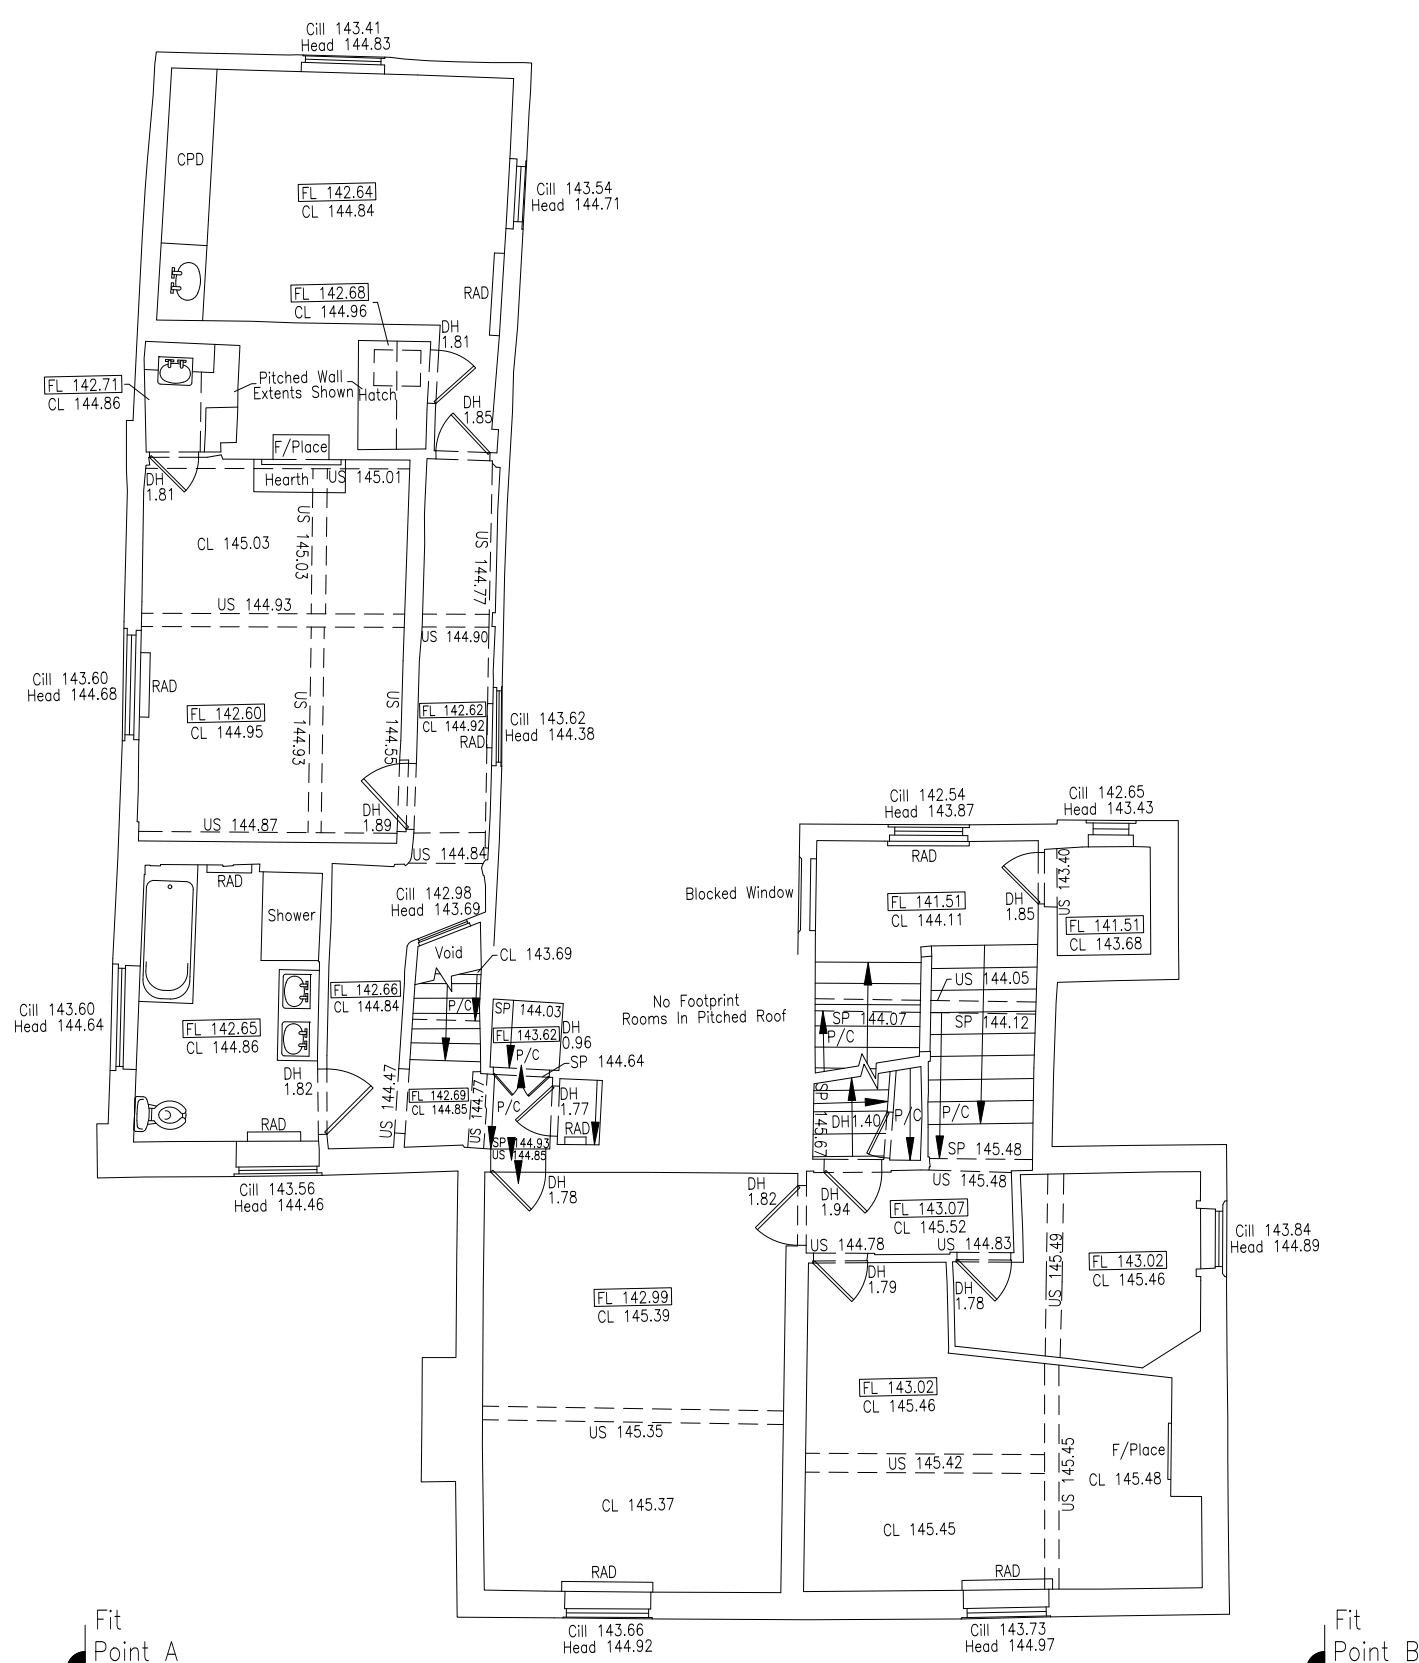


FIRST FLOOR PLAN

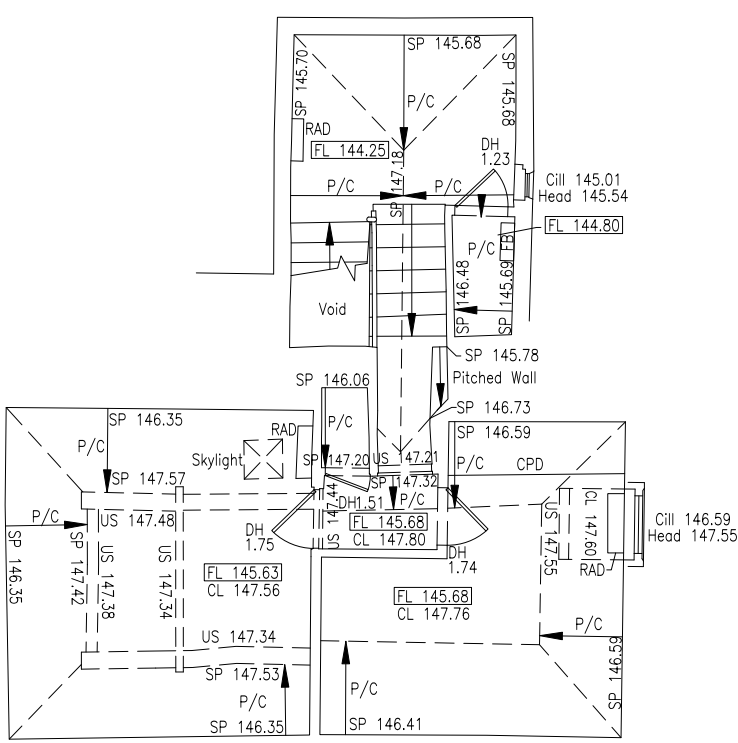

SECOND FLOOR PLAN

Legend:			
Abbreviated Features:	Symbols:		
AB Air Brick	LI Light	Radiator	AB
B Ballard	P D/F	Overflow Pipe	LI
C/B Close Boarded	P/C Pitched Ceiling	Light	LI
C-H C/H to Head	PS Pipe	Emergency Light	LI
C/L Chain Link	P/W Pitched Roof	Strip Light	LI
CL Ceiling Level	P/R Pitched Roof	Wall Mounted Light	LI
CPD Cupboard	R/R Roll & Wire	Mains Point	LI
CR Crown Point Level	RD Roller Door	Blank Plate	LI
DH Door Height	RE Rooding Eye	Light Switch	LI
Dr Drain	RWP Rooding Pipe	Pendant Switch	LI
FE Fire Exit	SD Sliding Doors	Isolator Switch	LI
F-C Floor to C/H	SQL Suspended Ceiling Level	Alarm Bell	LI
FL Floor Level	SP Spring Point Level	Snow Detector	LI
FW Four Water	SW Soil & Vent Pipe	Alarm Panel	LI
MH Manhole	SW Surface Water	Thermotat	LI
C Dully	US Underside	Modern	LI
IC Inspection Chamber	UTL Unable To Lift	Alarm Panel	LI
IL Invert Level	VP Vent Pipe	Thermotat	LI
I/R Iron Railings	VI Vent	Modern	LI
		Electric Box	LI
		Water Stop Tap	LI
		Overhead Features	LI

Plan Coordinate Control:-
N/A
Level Datum:-
All Levels relate to OSGB36 using GPS

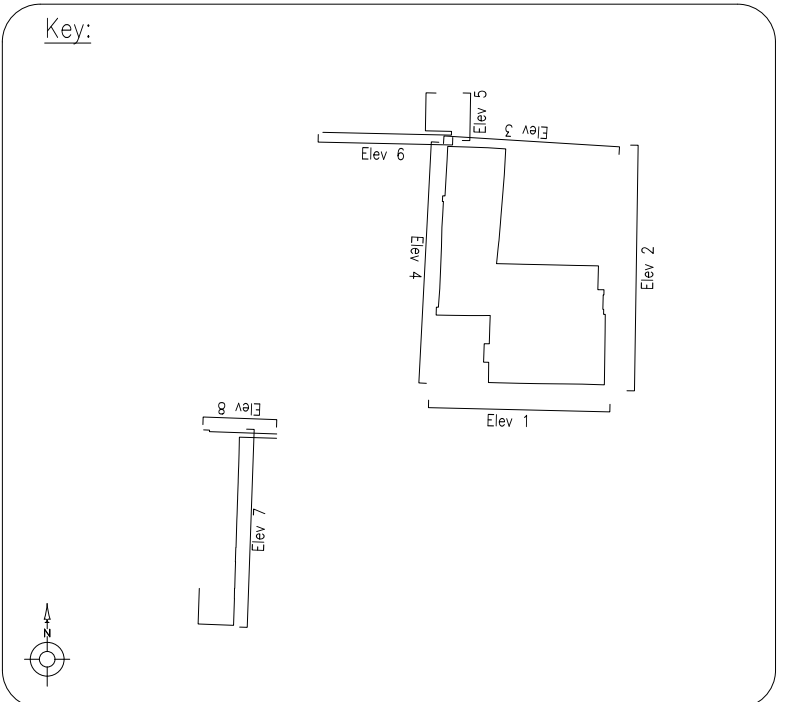

Notes:

REV NO REV NOTE DATE SIGNED



GLOBAL SURVEYS
3 Brookfield, Duncan Close,
Moulton Park, Northampton, NN3 6WL
Tel: 01604 491543
Email: info@globalsurveys.co.uk

Site: Manor Farm
Graveley
SG4 7BN
Client: Stuart Poonawala
Survey Title: Measured Building Survey
Basement, Ground, First
& Second Floor Plans

Date	June 2023	Scale	1/100 @ A1
Dwg No.	23137-MBS	Surveyor	GD
Sheet	1 of 3	Checked	KMG