



100mm

50mm

10mm

- NOTES:
- ALL DIMENSIONS IN MM UNLESS OTHERWISE NOTED.

Note: All existing feeder cables to be re-used. Subject to testing.

Master:	MBNL / EE / H3G:	Project:	Purpose of Issue:	Issue:
M001	MBNL	Vendor Swap	Detailed Design	A1
Date:	14/06/2024	Revision / Upgrade Description:		
Drawn:	YOD	Detailed Design		
Checked:	KS			
Approved:	DC			



Hatfield Business Park
Hatfield
Hertfordshire
AL10 9BW

Tel: 01707 315000
Fax: 01707 319001

Design & Principal Consultant:



UK Office:
UBC Building, 1310 Solihull Parkway,
Birmingham Business Park, B37 7YU

Tel: +44 (0)1908 377 766
Email: info@kti.ie

Site Name:
STOTFOLD ROAD (P91658)

Site ID:
751368

Address:
STOTFOLD ROAD
LETCWORTH GARDEN CITY
HERTFORDSHIRE
SG6 4JS


Title:
150 PROPOSED SITE PLAN

Project:
VENDOR SWAP

Purpose of Issue:
DETAILED DESIGN

EE Cell ID:	MBNL Cell ID:	3UK Cell ID:
71063	NHE014	SG0139

Master Drawing No:	Issue:
751368_NHE014_71063_SG0139_M001	A1

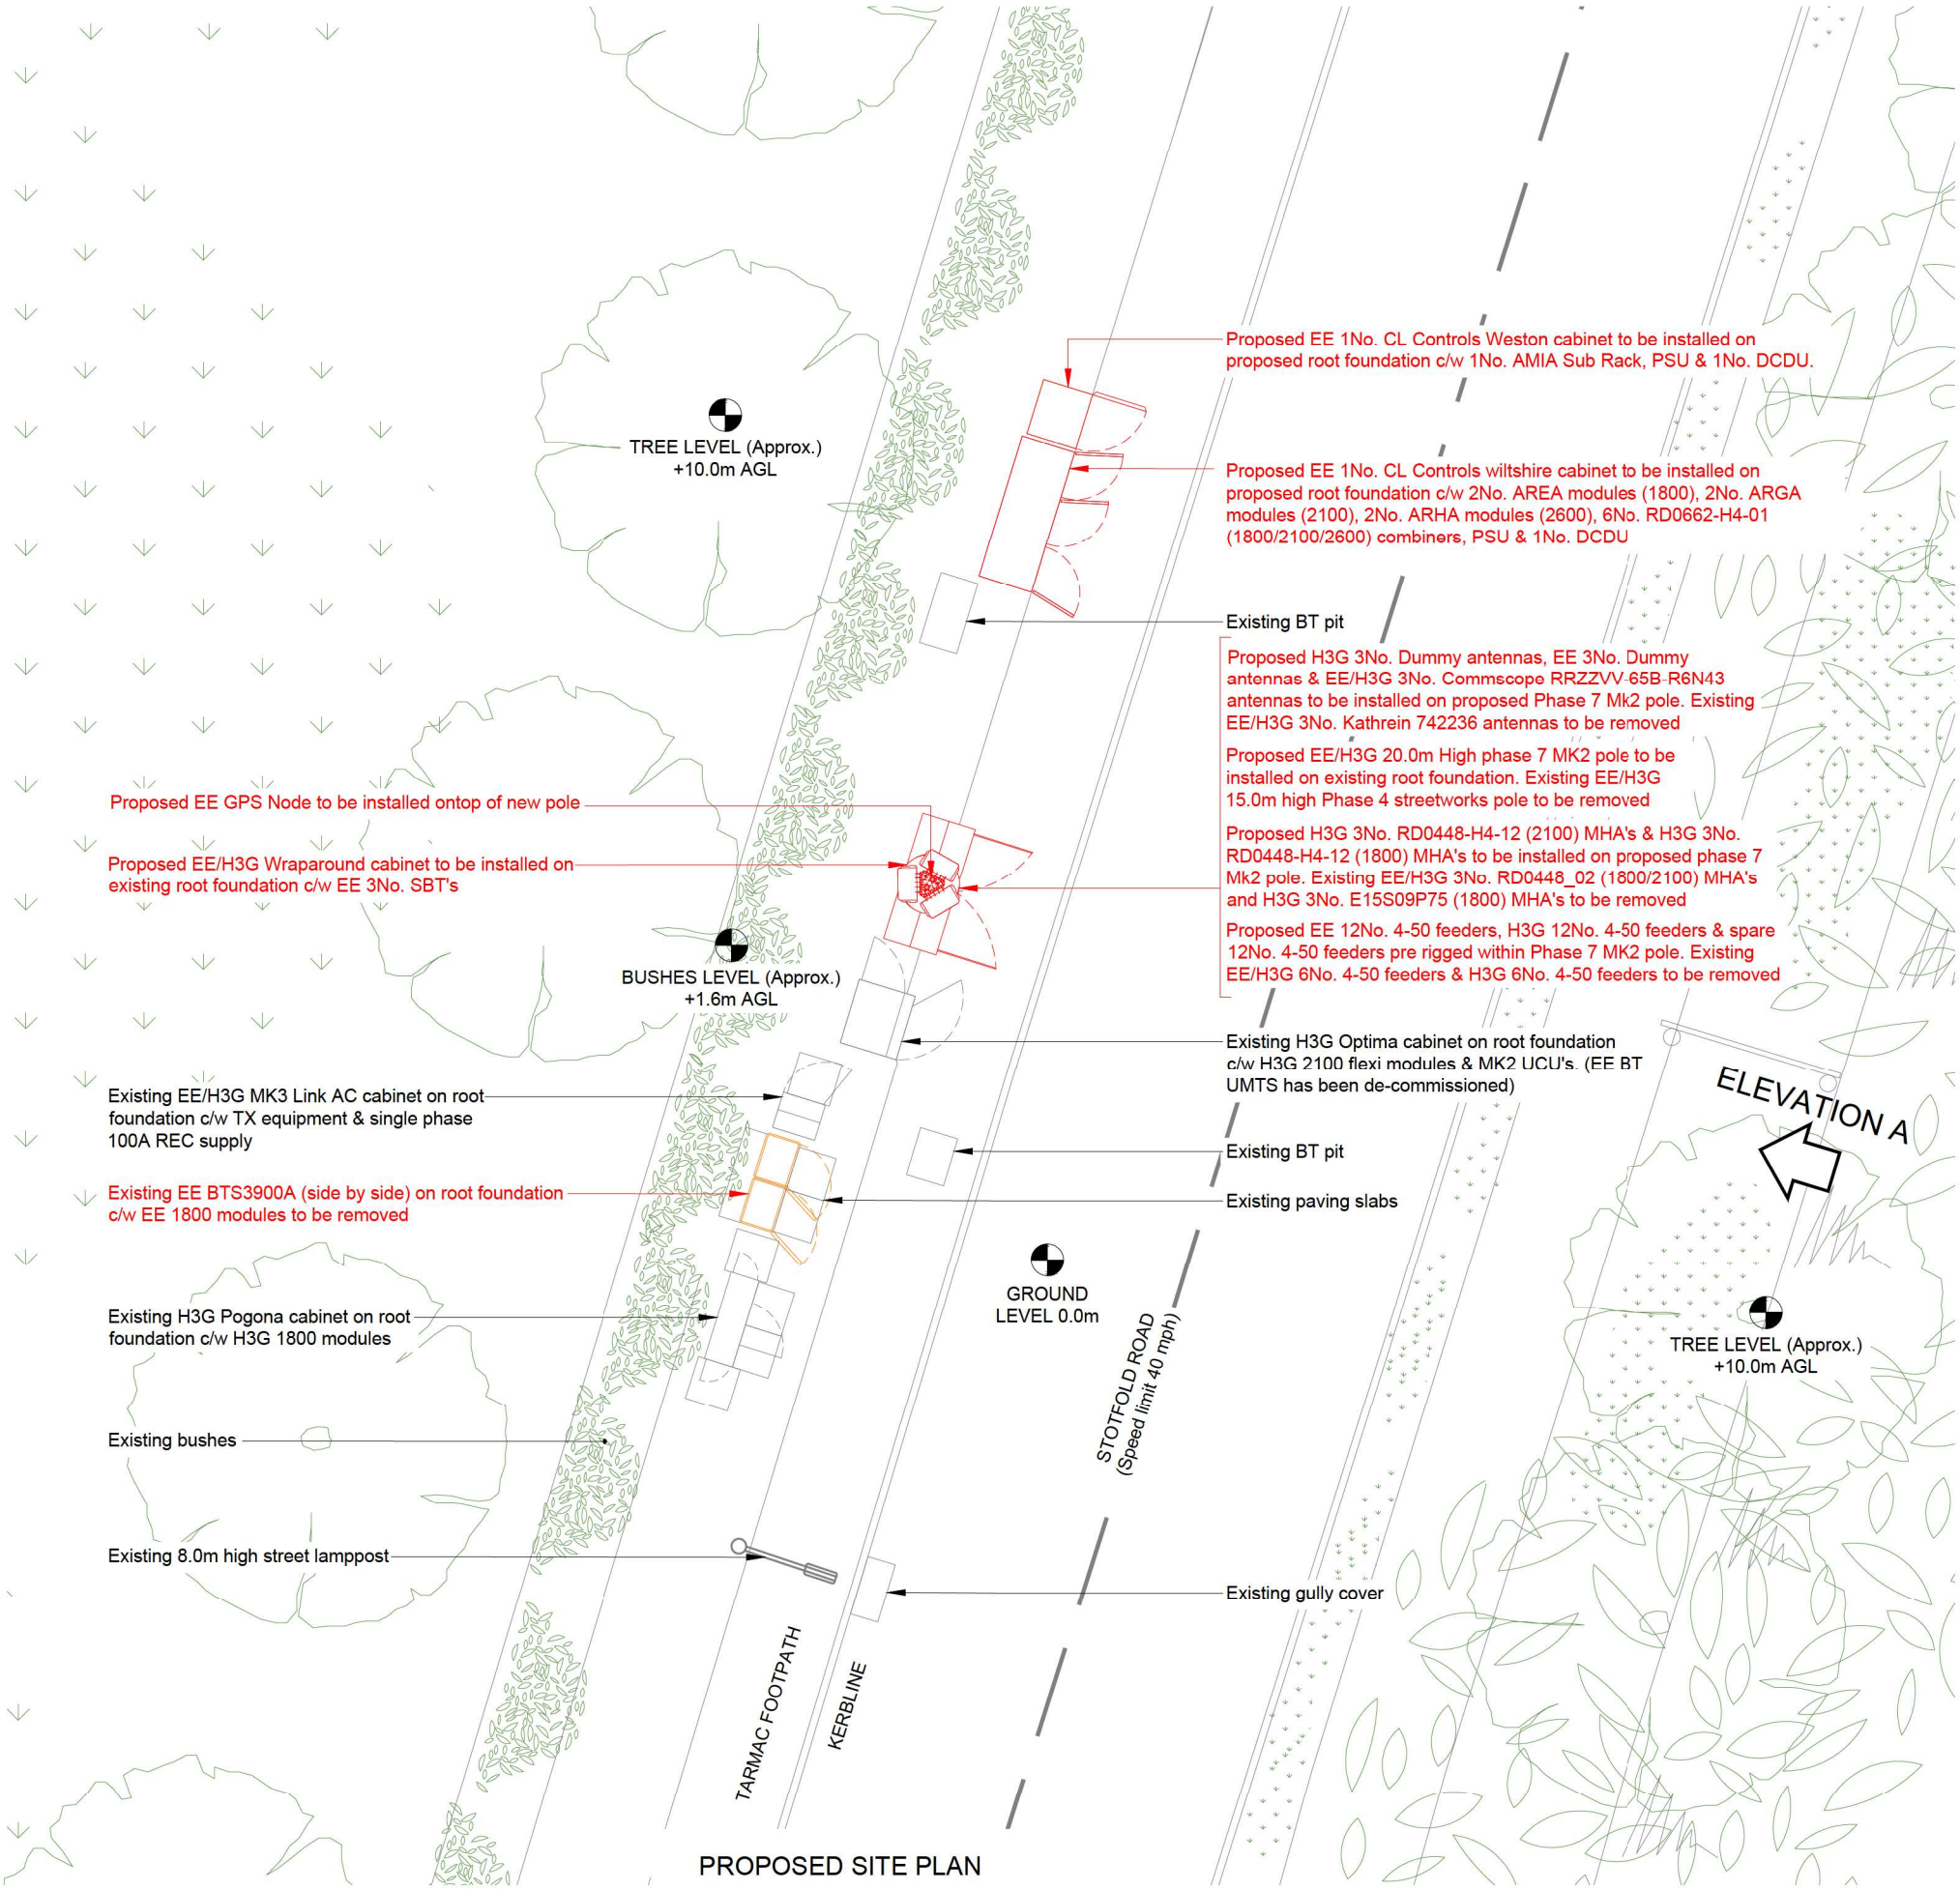

PROPOSED SITE PLAN

