

PROPOSED BTEE 3No. COMMSCOPE RRZVV-65B-R6N43 ANTENNAS AT 31.00m MEAN BEARINGS 40°, 120° & 270° E.T.N. I.D. No's. TBC TO BE INSTALLED ON PROPOSED SUPPORT POLES FIXED TO YOKE BRACKETS

PROPOSED BTEE 3No. NOKIA AEQQ ANTENNAS AT 32.91m MEAN BEARINGS 40°, 120° & 270° E.T.N. I.D. No's. TBC TO BE INSTALLED ON PROPOSED SUPPORT POLE FIXED TO YOKE BRACKETS

H3G 3No. COMMSCOPE CV65BSX-2X2 ANTENNAS AT 31.2m MEAN BEARINGS 0°, 120° & 240° E.T.N. I.D. No's. EQU900201006, EQU900201007 & EQU900201008

BTEE 3No. DUAL POLAR ANTENNAS AT 31.0m MEAN BEARINGS 40°, 120° & 240° E.T.N. I.D. No's. EQU900171278, EQU900171279 & EQU900171280 TO BE REMOVED

PROPOSED BTEE 3No. NOKIA AHEGG (1800/2100) RRH's I.D. No's. TBC TO BE INSTALLED ON PROPOSED SUPPORT POLES FIXED TO TOWER LEG USING NEW OFFSET BRACKETS

PROPOSED BTEE 3No. NOKIA AHPMDB (700/800) RRH's I.D. No's. TBC TO BE INSTALLED ON PROPOSED SUPPORT POLES FIXED TO TOWER LEG USING NEW OFFSET BRACKETS

PROPOSED BTEE 3No. NOKIA ARHA (2600) RFW's I.D. No's. TBC TO BE INSTALLED ON PROPOSED SUPPORT POLES FIXED TO TOWER LEG USING NEW OFFSET BRACKETS

H3G 3No. TMA2053F03 (1800/2100) MHA's I.D. No's. TBC ON SUPPORT POLES

H3G 3No. (800) MHA's I.D. No's. TBC ON SUPPORT POLES


BTEE 3No. E15S09P75 (1800) MHA's I.D. No's. EQU900495132, EQU900495133 & EQU900495134 TO BE REMOVED

PROPOSED BTEE 3No. COMMSCOPE MK2 BOB's I.D. No's. TBC TO BE INSTALLED ON PROPOSED SUPPORT POLES FIXED TO TOWER LEG USING NEW OFFSET BRACKETS

H3G & BTEE 1No. 0.3m DISH AT 29.6m BEARING 135.59° E.T.N. I.D. No. EQU900245609

H3G & BTEE 1No. 0.3m DISH AT 28.5m BEARING 232.49° E.T.N. I.D. No. EQU900263809

H3G & BTEE 1No. 0.3m DISH AT 27.0m BEARING 83.0° E.T.N. I.D. No. EQU900245484

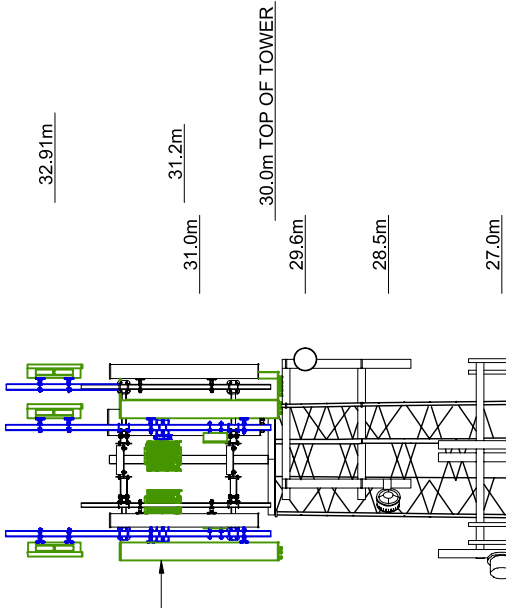

- H3G & BTEE 1No. EQUIPMENT CABIN ON CONCRETE BASE TO BE REFRESHED FOR PROPOSED UPGRADE
- PROPOSED BTEE 1No. AIRI CABINET C/W AMIA BBU TO BE INSTALLED WITHIN EQUIPMENT CABIN
- BTEE 1No. BTS3900L CABINET TO BE REMOVED
- PROPOSED BTEE 3No. COMMSCOPE MK2 BOB's TO BE INSTALLED ON PROPOSED VERTICAL CABLE LADDER WITHIN EQUIPMENT CABIN
- H3G & BTEE 1No. CRABTREE WALL MOUNTED AC DISTRIBUTION BOARD TO BE UPGRADED WITH ICD 11775 PAN ASSEMBLY KIT
- H3G & BTEE 1No. ELTEK PSU CABINET C/W 3No. 2kW RECTIFIERS TO BE REUSED FOR UPGRADE. ADDITIONAL 5No. 2kW RECTIFIERS REQUIRED (8No. 2kW RECTIFIERS IN TOTAL)

 
PROPOSED BTEE 1No. UHF GPS NODE AT 3.0m MEAN I.D. No. TBC TO BE INSTALLED ON GANTRY POLE

BTEE 1No. CABINET 5 (REDUNDANT) ON CONCRETE BASE

H3G & BTEE METER CABINET 3 ON CONCRETE BASE C/W THREE PHASE 100A REC SUPPLY

BTEE 1No. CABINET 6 (REDUNDANT) ON CONCRETE BASE

1.8m HIGH CHAINLINK FENCE WITH 3No. STRANDS OF BARBED WIRE



SOUTH ELEVATION

FEINT DETAILS INDICATE LOCATIONS RESERVED FOR OTHER PROPOSALS WHICH MAY BE THE SUBJECT OF SEPARATE APPLICATIONS

THIS DESIGN COMPLIES WITH CELLNEX ICNIRP STANDARD UK-DE_PRO-0020 v7

NOTE:
PRO X5 COMPLETED ON 11/09/2024 AND DEEMS THAT THE SITE ACHIEVES ICNIRP COMPLIANCE

PROJECT No.		COL.MOD.UK.0003737			
CELL No.		SVG011			
BTEE ID.		90336			
10.A	COL.MOD.UK.0003737 PLANNING			GBC	
10	COM-0014261 PROJECT REMOVAL	26/02/24	MCD	MCD	
9	243476 PLANNING DRAWING	08/12/21	BEA	BEA	
8	214299 DECOM	30/05/19	BB	MF	
7	177732 AS BUILT	22/03/17	WHP	JW	
ISS	REVISION	DATE	DRN	APP	



CELLNEX UK
R+, 4TH FLOOR, 2 BLA GRAVE STREET, READING, RG1 1AZ
Tel. 020 4526 8553

SITE No 1490336
WATTON SUB STATION
WATTON ROAD
KNEBWORTH
STEVENAGE
HERTFORDSHIRE
SG3 6AG

NGR TL 25679 20500
OS GRID 525679 220500

TITLE
ELEVATION
PROPOSED
H3G & BTEE LTD

SCALE 1:100

DRAWN	IM	19/08/11
APPROVED	MCD	26/02/24

DRG No.	Sheet 1 of 1	Rev
1490336-02-160-MD010	10.A	

©2020 Cellnex
All rights reserved. No part of this publication may be reproduced, stored in a retrieval system or transmitted in any form or by any means (Electronic, Mechanical, Photocopying, Recording or otherwise), without the prior written consent of the Company.

NOTES