


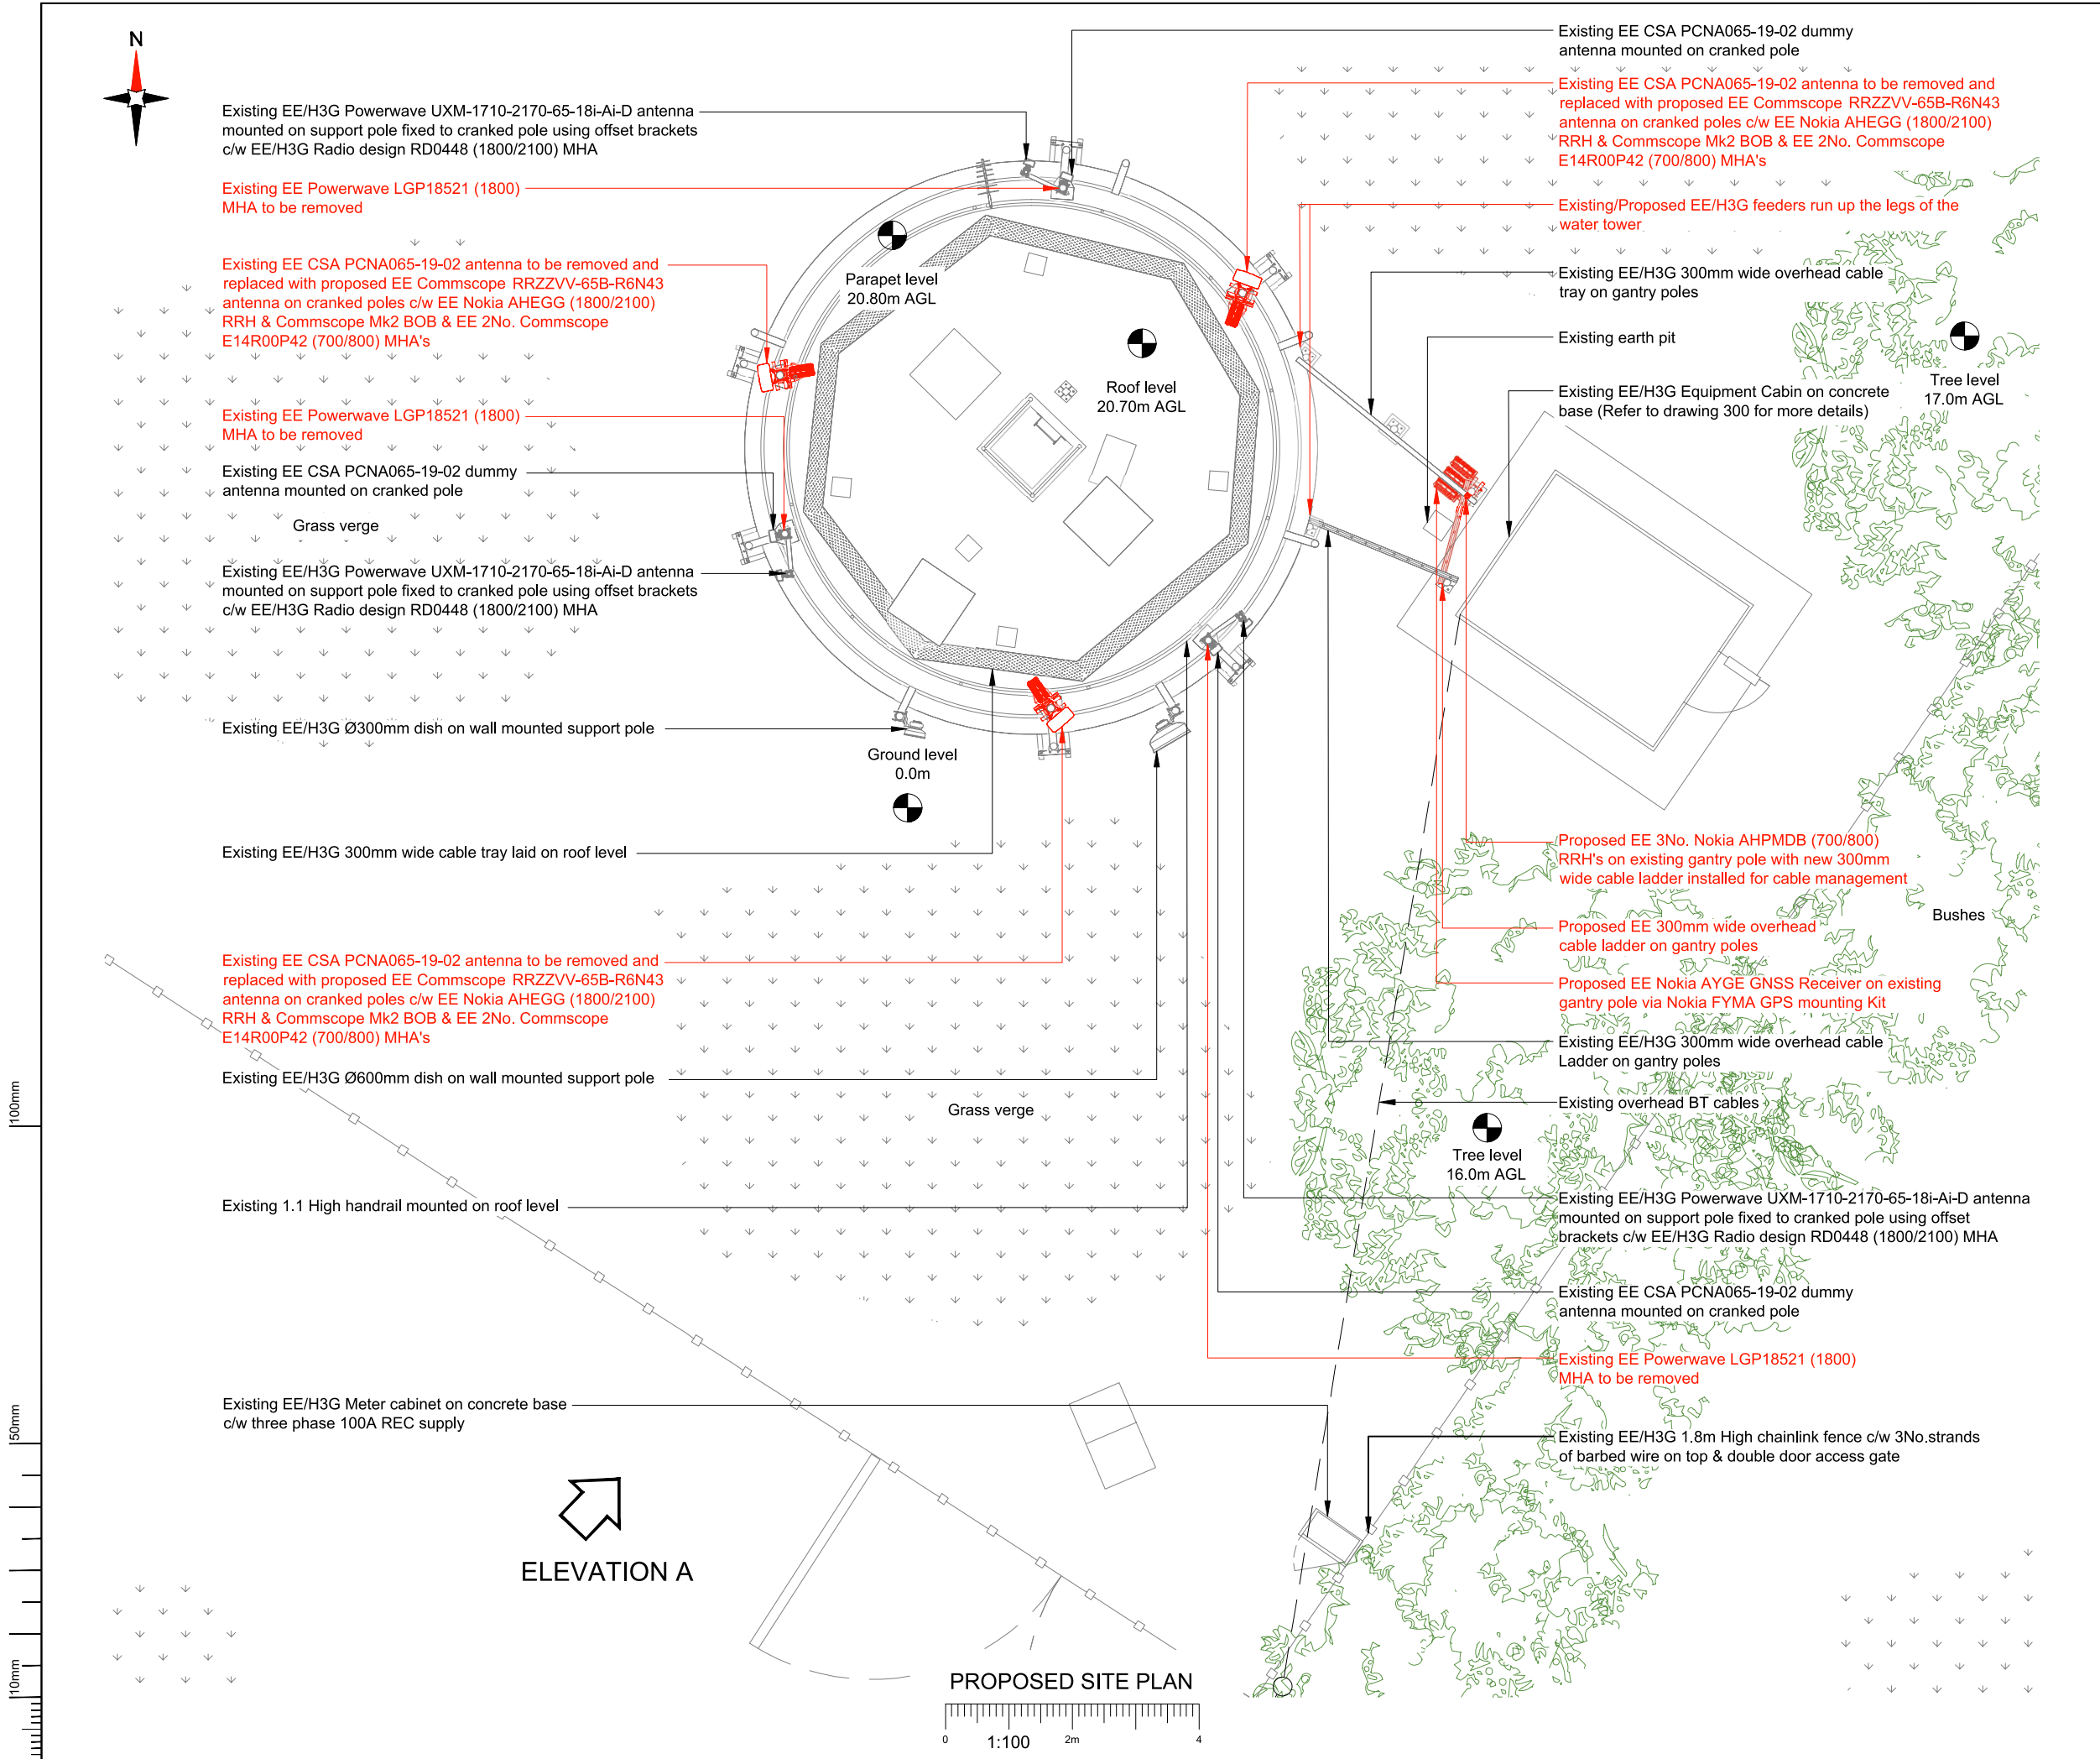

NOTES:

1. ALL DIMENSIONS IN MM UNLESS OTHERWISE NOTED.

Note:
Proposed feeders / cables to follow existing cable management, subject to some repositioning of existing feeders / studs

Note:
Existing EE 3No. 1800 feeders to be re-routed & re-used for LB to antenna B1, subject to testing

Master:	MBNL / EE / H3G:	Project:	Purpose of Issue:	Issue:
M001	EE	Vendor Swap	General Arrangement	A
Date:	10/12/2024	Revision / Upgrade Description:		
Drawn:	R.Raja	First Issue		
Checked:	M.Ashworth			
Approved:	L.Napolitano			



EE Limited
1 Braham Street
London
United Kingdom
E1 8EE



Site Name:
RABLEY HEATH WATER TOWER

Site ID:
500685

Address:
RABLEY HEATH
WELWYN GARDEN CITY
HERTFORDSHIRE
AL6 9UG

Title:
150 PROPOSED SITE PLAN

Project:
VENDOR SWAP

Purpose of Issue:
GENERAL ARRANGEMENT

EE Cell ID:	MBNL Cell ID:	3UK Cell ID:
68095	WEH012	AL0065

Master Drawing No:	Issue:
500685_WEH012_68095_AL0065_M001	A