


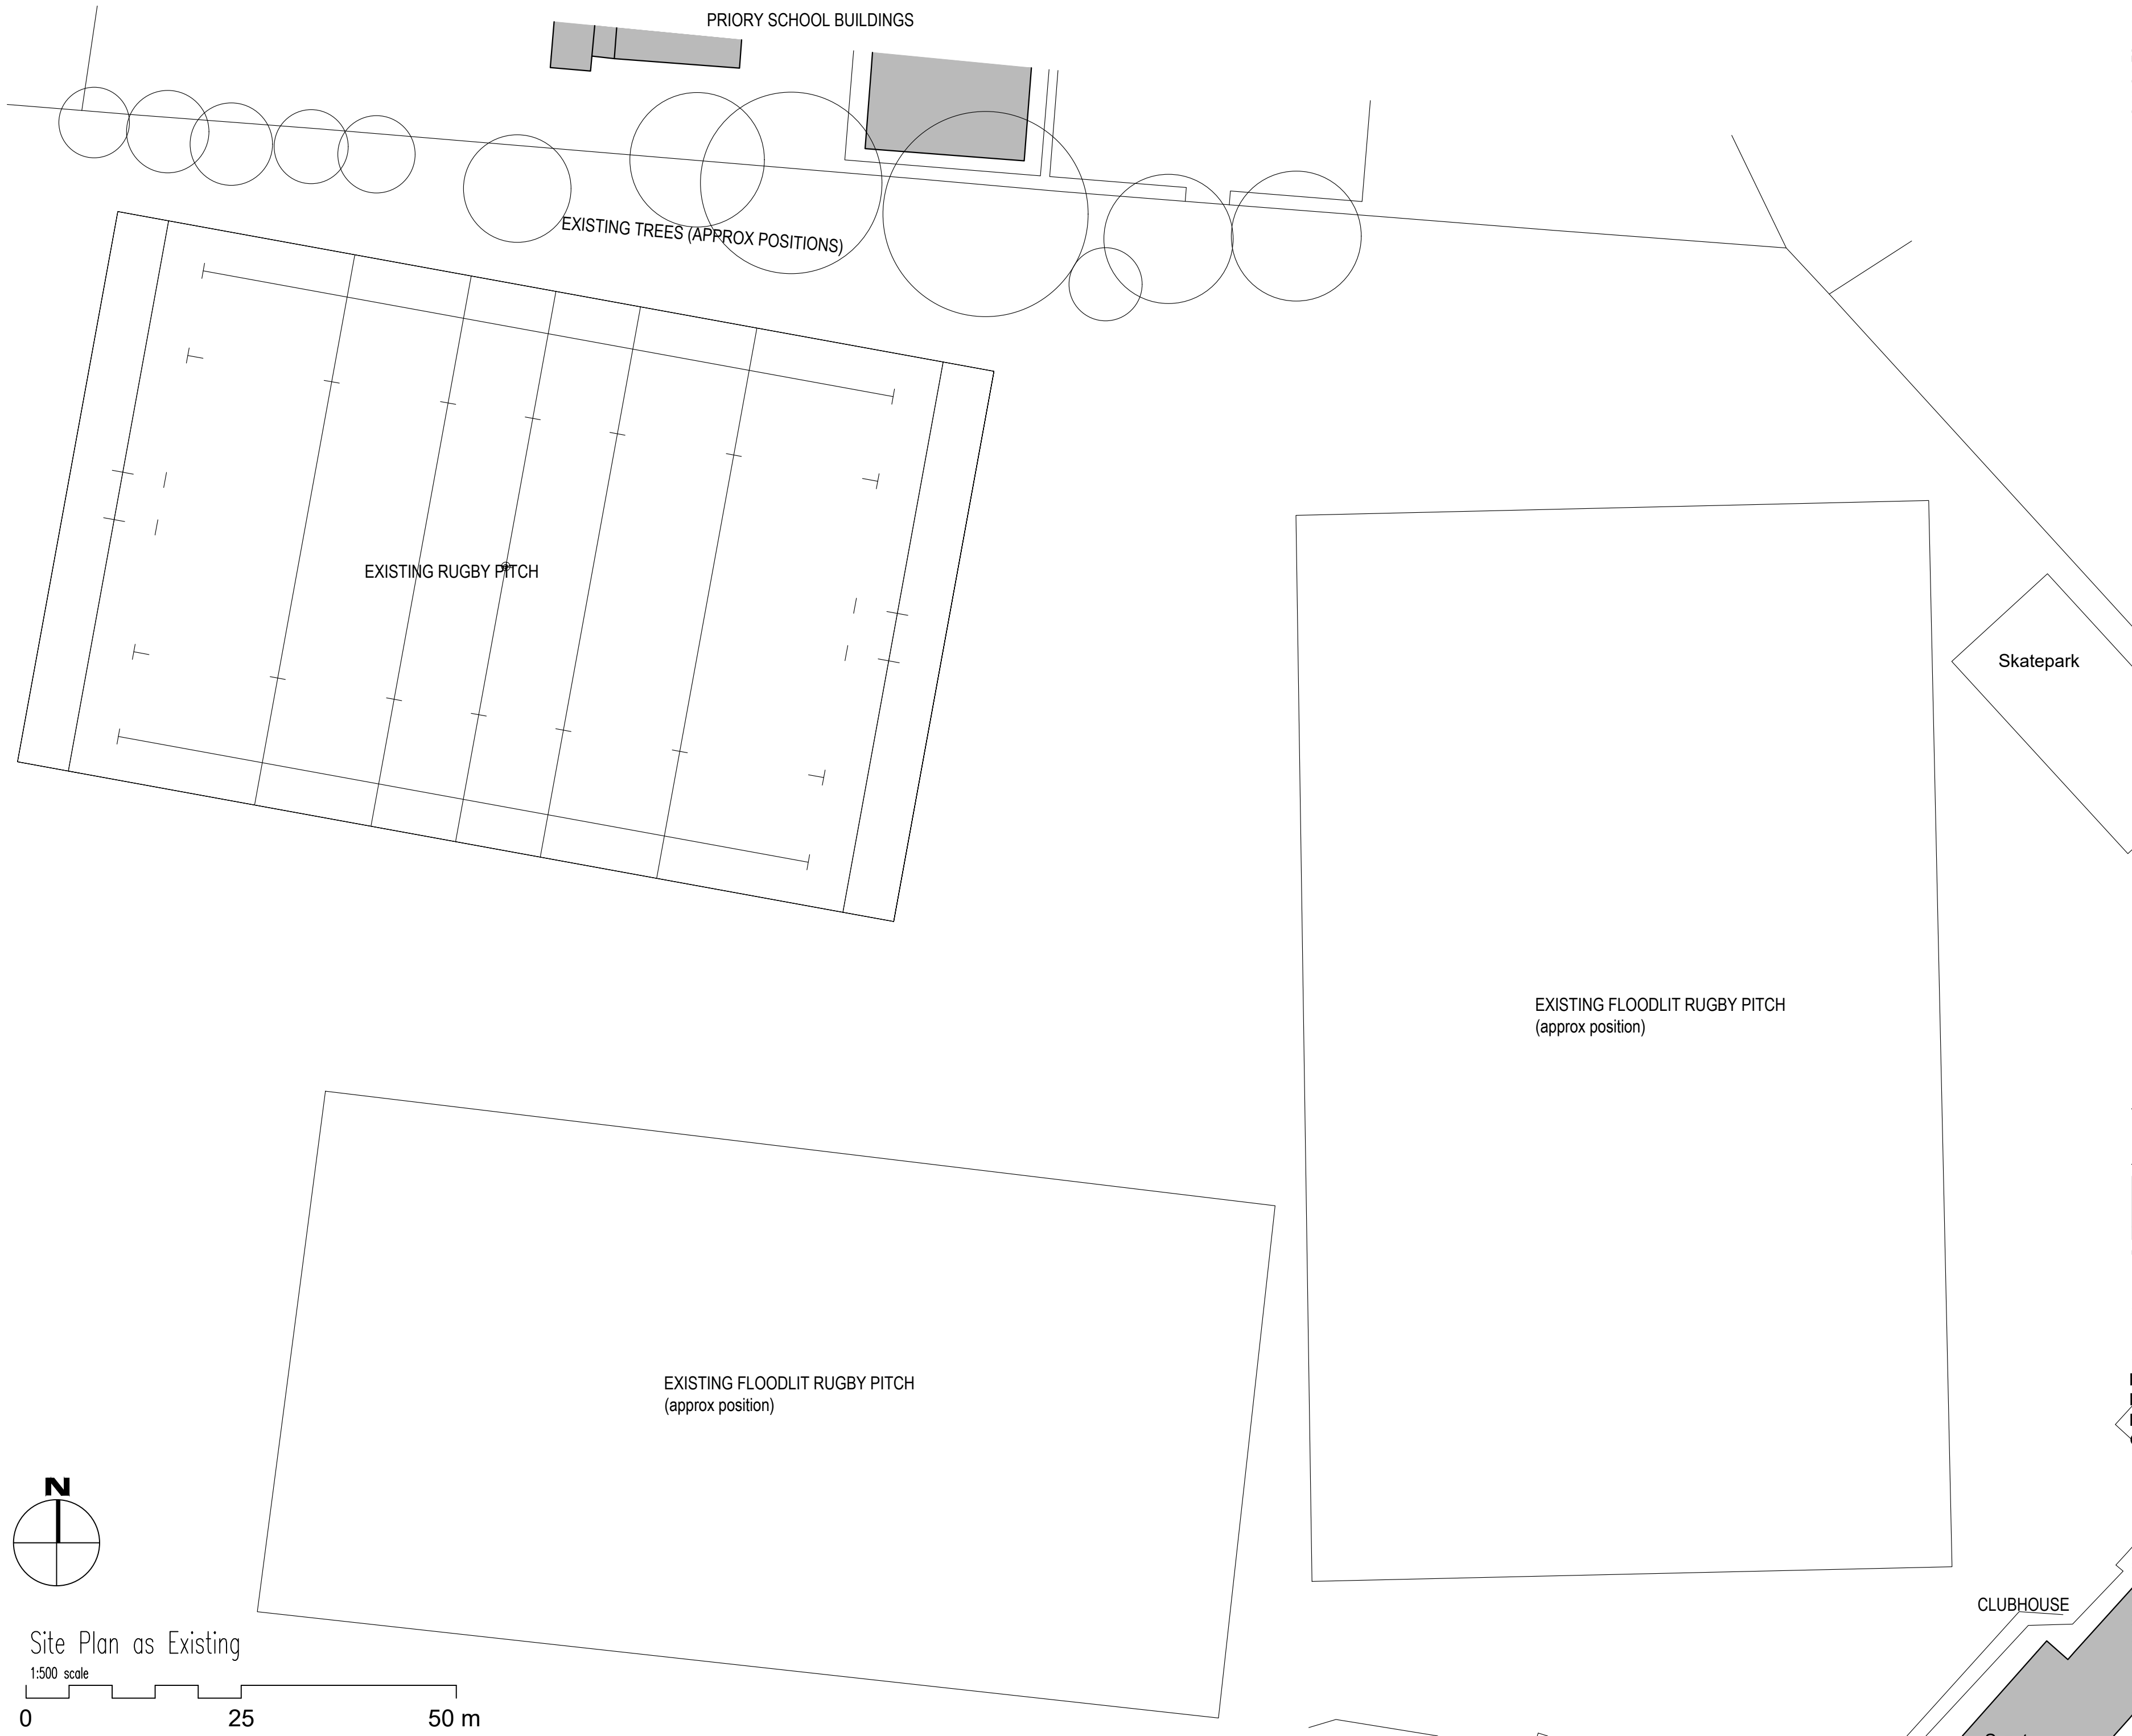

ANY QUERIES REGARDING DIMENSIONS TO BE TAKEN UP WITH PENTANGLE DESIGN GROUP.

ALL DIMENSIONS OF EXISTING BUILDINGS TO BE VERIFIED ON SITE.

THIS DRAWING IS THE COPYRIGHT OF PENTANGLE DESIGN GROUP AND SHALL NOT BE IN ANY WAY USED OR REPRODUCED WITHOUT THEIR PRIOR WRITTEN CONSENT.

NOTES

PLANNING

PENTANGLE

D E S I G N G R O U P

SUITE 1, 21 BANCROFT HITCHIN HERTS SG5 1JW

TEL(01462) 431133 E:PDG@PENTANGLEDESIGN.CO.UK

JOB TITLE

Proposed Floodlighting
Hitchin Rugby Club
King George V Playing Fields
Old Hale Way, Hitchin

DRAWING TITLE

Existing Site Plan

Site Plan as Existing

1:500 scale

0

25

50 m

CLUBHOUSE

SCALE	1:500	DRAWING NUMBER	02	REVISION	A
DATE	July '26				
Sheet	A2				
JOB NUMBER	4008				

ARCHITECTS & INTERIOR DESIGNERS