


ANY QUERIES REGARDING DIMENSIONS TO BE TAKEN UP WITH
PENTANGLE DESIGN GROUP.
ALL DIMENSIONS OF EXISTING BUILDINGS TO BE VERIFIED ON SITE.
THIS DRAWING IS THE COPYRIGHT OF PENTANGLE DESIGN GROUP
AND SHALL NOT BE IN ANY WAY USED OR REPRODUCED WITHOUT
THEIR PRIOR WRITTEN CONSENT.

NOTES

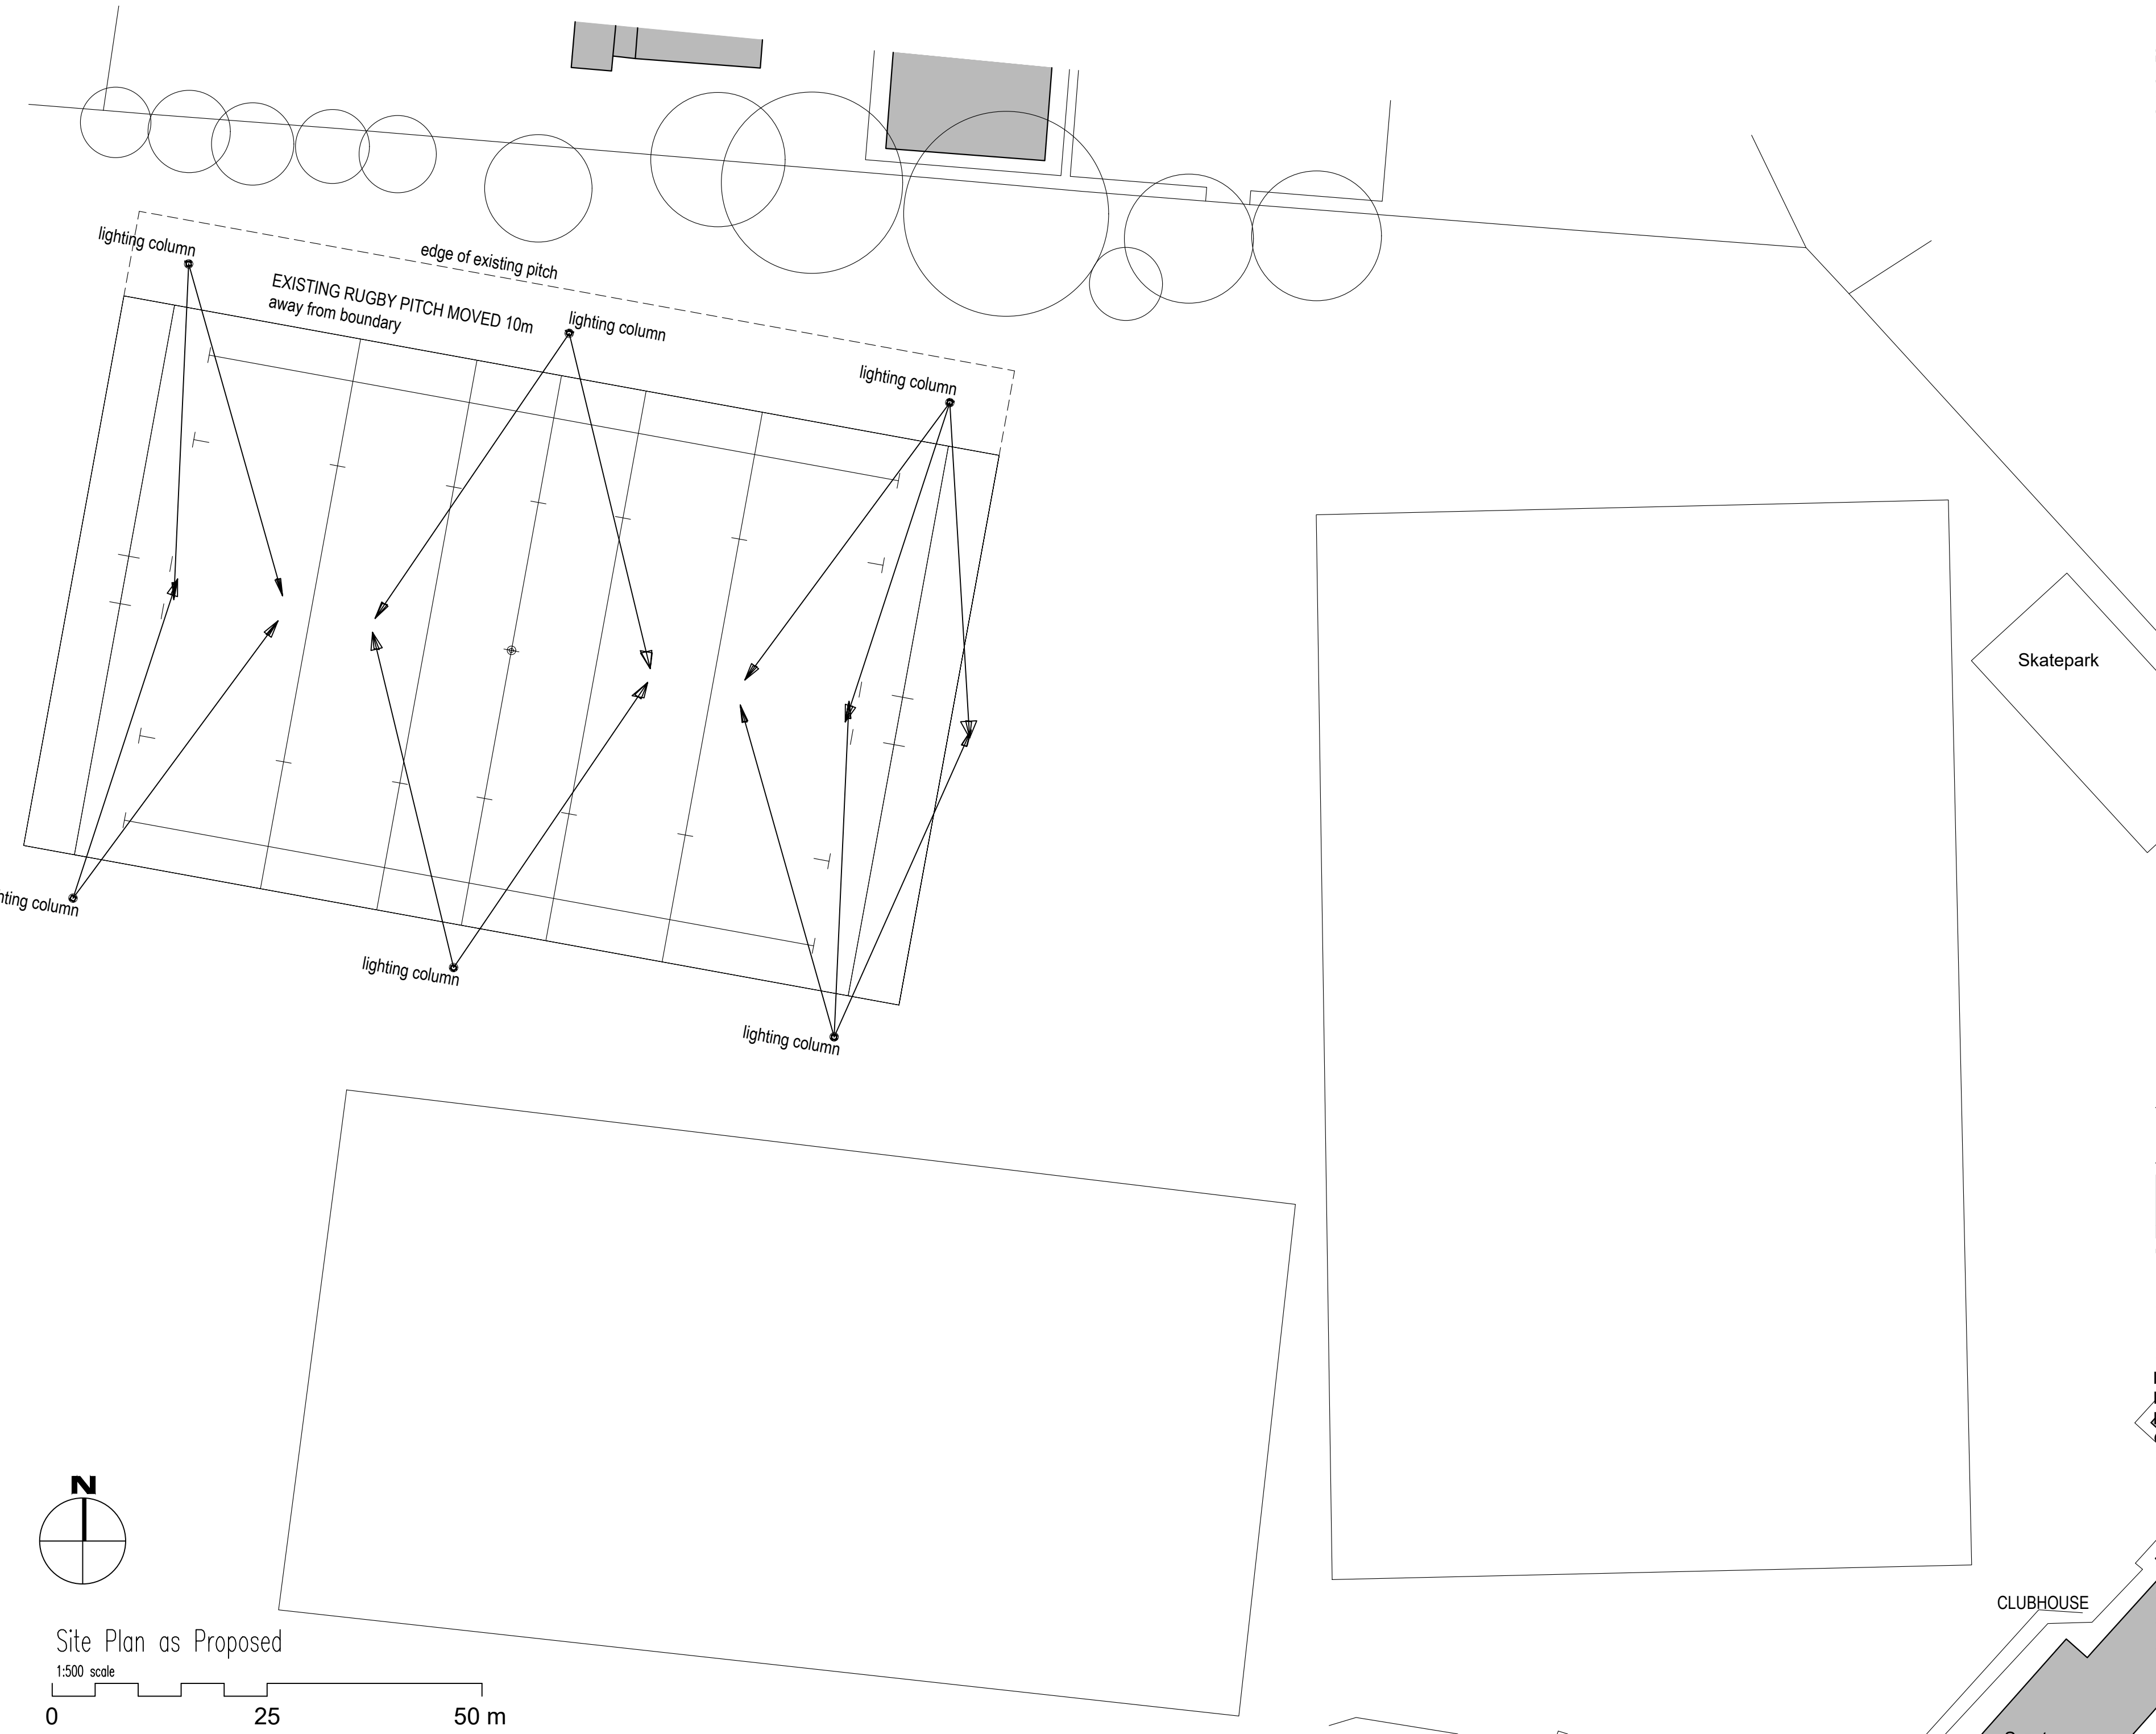

PLANNING
PENTANGLE

D E S I G N G R O U P

SUITE 1, 21 BANCROFT HITCHIN HERTS SG5 1JW
TEL:01462) 431133 E:PDG@PENTANGLEDESIGN.CO.UK

JOB TITLE
Proposed Floodlighting
Hitchin Rugby Club
King George V Playing Fields
Old Hale Way, Hitchin
DRAWING TITLE
Proposed Site Plan

SCALE	DRAWING NUMBER	REVISION
1:500		
DATE	July '26	
Sheet	A2	
JOB NUMBER	4008	

ARCHITECTS & INTERIOR DESIGNERS