


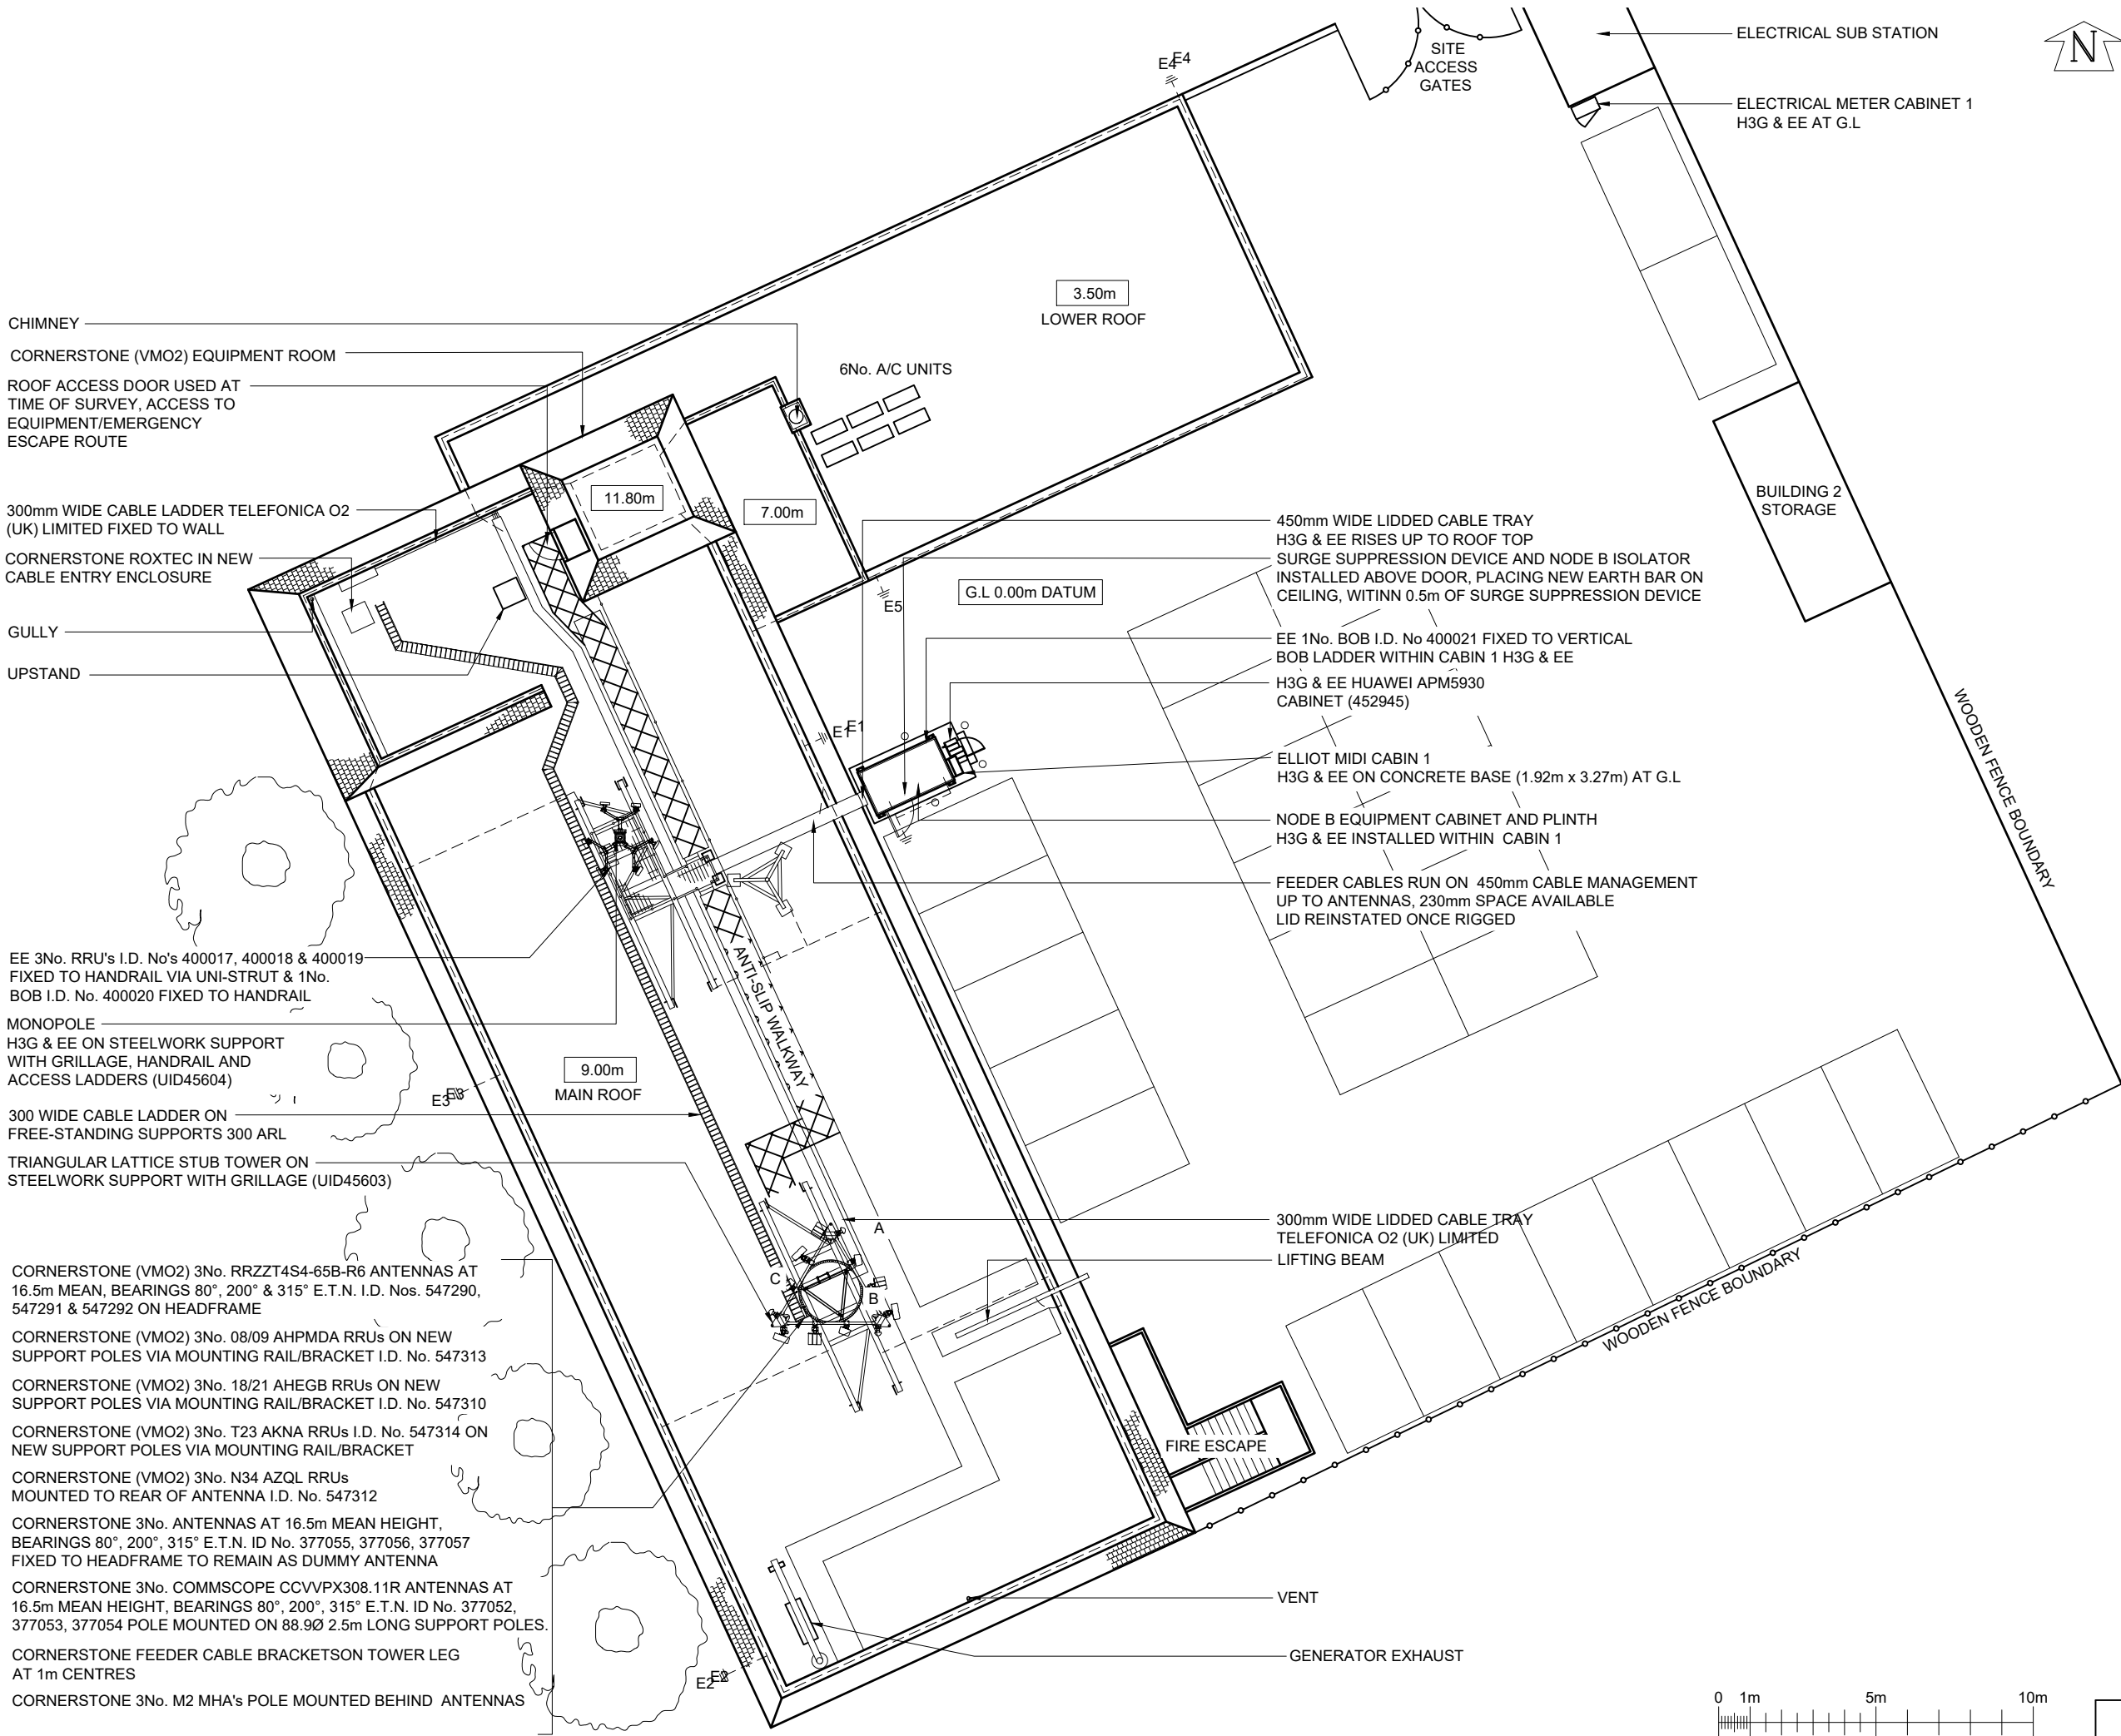

©2020 Cellnex
All rights reserved. No part of this publication may be reproduced, stored in a retrieval system or transmitted in any form or by any means (Electronic, Mechanical, Photocopying, Recording or otherwise), without the prior written consent of the Company.

NOTES

UNDERGROUND SERVICES
UNDERGROUND SERVICES ARE INDICATIVE ONLY. POSITIONS SHOULD BE CONFIRMED ON SITE PRIOR TO ANY DEVELOPMENT

DRAINAGE
DUCTS
FEEDERS
FENCE PLAN
GAS
LIGHTNING PROTECTION - EARTHING

POWER
SERVICES UNKNOWN
TELECOMS
WATER

ACCESS ARRANGEMENTS

KEYS:-

ARQVA GATE KEY
B KEY
C KEY
LEGGE KEY

SURVEY REQUIRED TO CONFIRM ACCESS KEYS FOR REMAINING ROOMS AND SITE ENTRANCE

BT SKYLINE No. **SG0037**

30	COL.MOD.UK.0003691 PLANNING ISSUE	14/08/25	HFC	HFC
29	COL.MOD.UK.0001495 PLANNING AMEND	04/02/25	GBC	GBC
28	COL.MOD.UK.0001495 PLANNING AMEND	27/11/24	GBC	GBC
27	COL.MOD.UK.0001495 PLANNING AMEND	28/10/24	GBC	GBC
26	COL.MOD.UK.0001495 PLANNING	08/12/23	GBC	GBC
ISS	REVISION	DATE	DRN	APP

cellnex
driving telecom connectivity

CELLNEX UK
R+, 4TH FLOOR, 2 BLA GRAVE STREET, READING, RG1 1AZ
Tel. 020 4526 8553

SITE No **UK-HT-001289**
LETCHWORTH ATE_SUB TEC
NEVELLS ROAD
LETCHWORTH
HERTFORDSHIRE
SG6 4TS

NGR **TL 21600 32800**

OS GRID

TITLE
SITE PLAN
EXISTING

SCALE **1:200**

DRAWN	IM	01/06/11
APPROVED	HFC	14/08/25

DRG No.	Sheet 1 of 1	Rev
UKHT001289-00-000-MD030		30